

NEW CAMPGROUND - REBID


MISSOURI STATE FAIRGROUNDS

SEDALIA, MISSOURI

OWNER: STATE OF MISSOURI
MIKE KEHOE,
GOVERNOR

MISSOURI DEPARTMENT OF
AGRICULTURE
MISSOURI STATE FAIRGROUNDS

PROJECT MANAGEMENT: OFFICE OF ADMINISTRATION
DIVISION OF FACILITIES MANAGEMENT,
DESIGN AND CONSTRUCTION

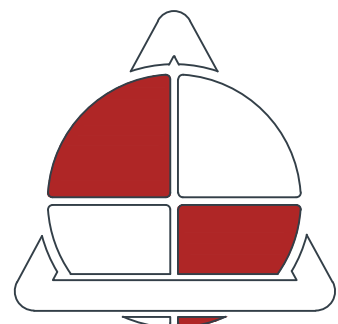

ALLSTATE
CONSULTANTS

3312 LEMONE INDUSTRIAL BLVD.
COLUMBIA, MO 65201
(573) 875-8799
allstateconsultants.net

MISSOURI STATE CERTIFICATE
OF AUTHORITY #2007004004
REUSE OF THIS DRAWING IN ANY MANNER IS STRICTLY
PROHIBITED WITHOUT THE WRITTEN APPROVAL OF
ALLSTATE CONSULTANTS LLC




DESIGNER: ALLSTATE CONSULTANTS LLC

PROJECT NUMBER: F2307-01

SITE NUMBER: 1501

FACILITY ASSET NUMBERS: 3511501153

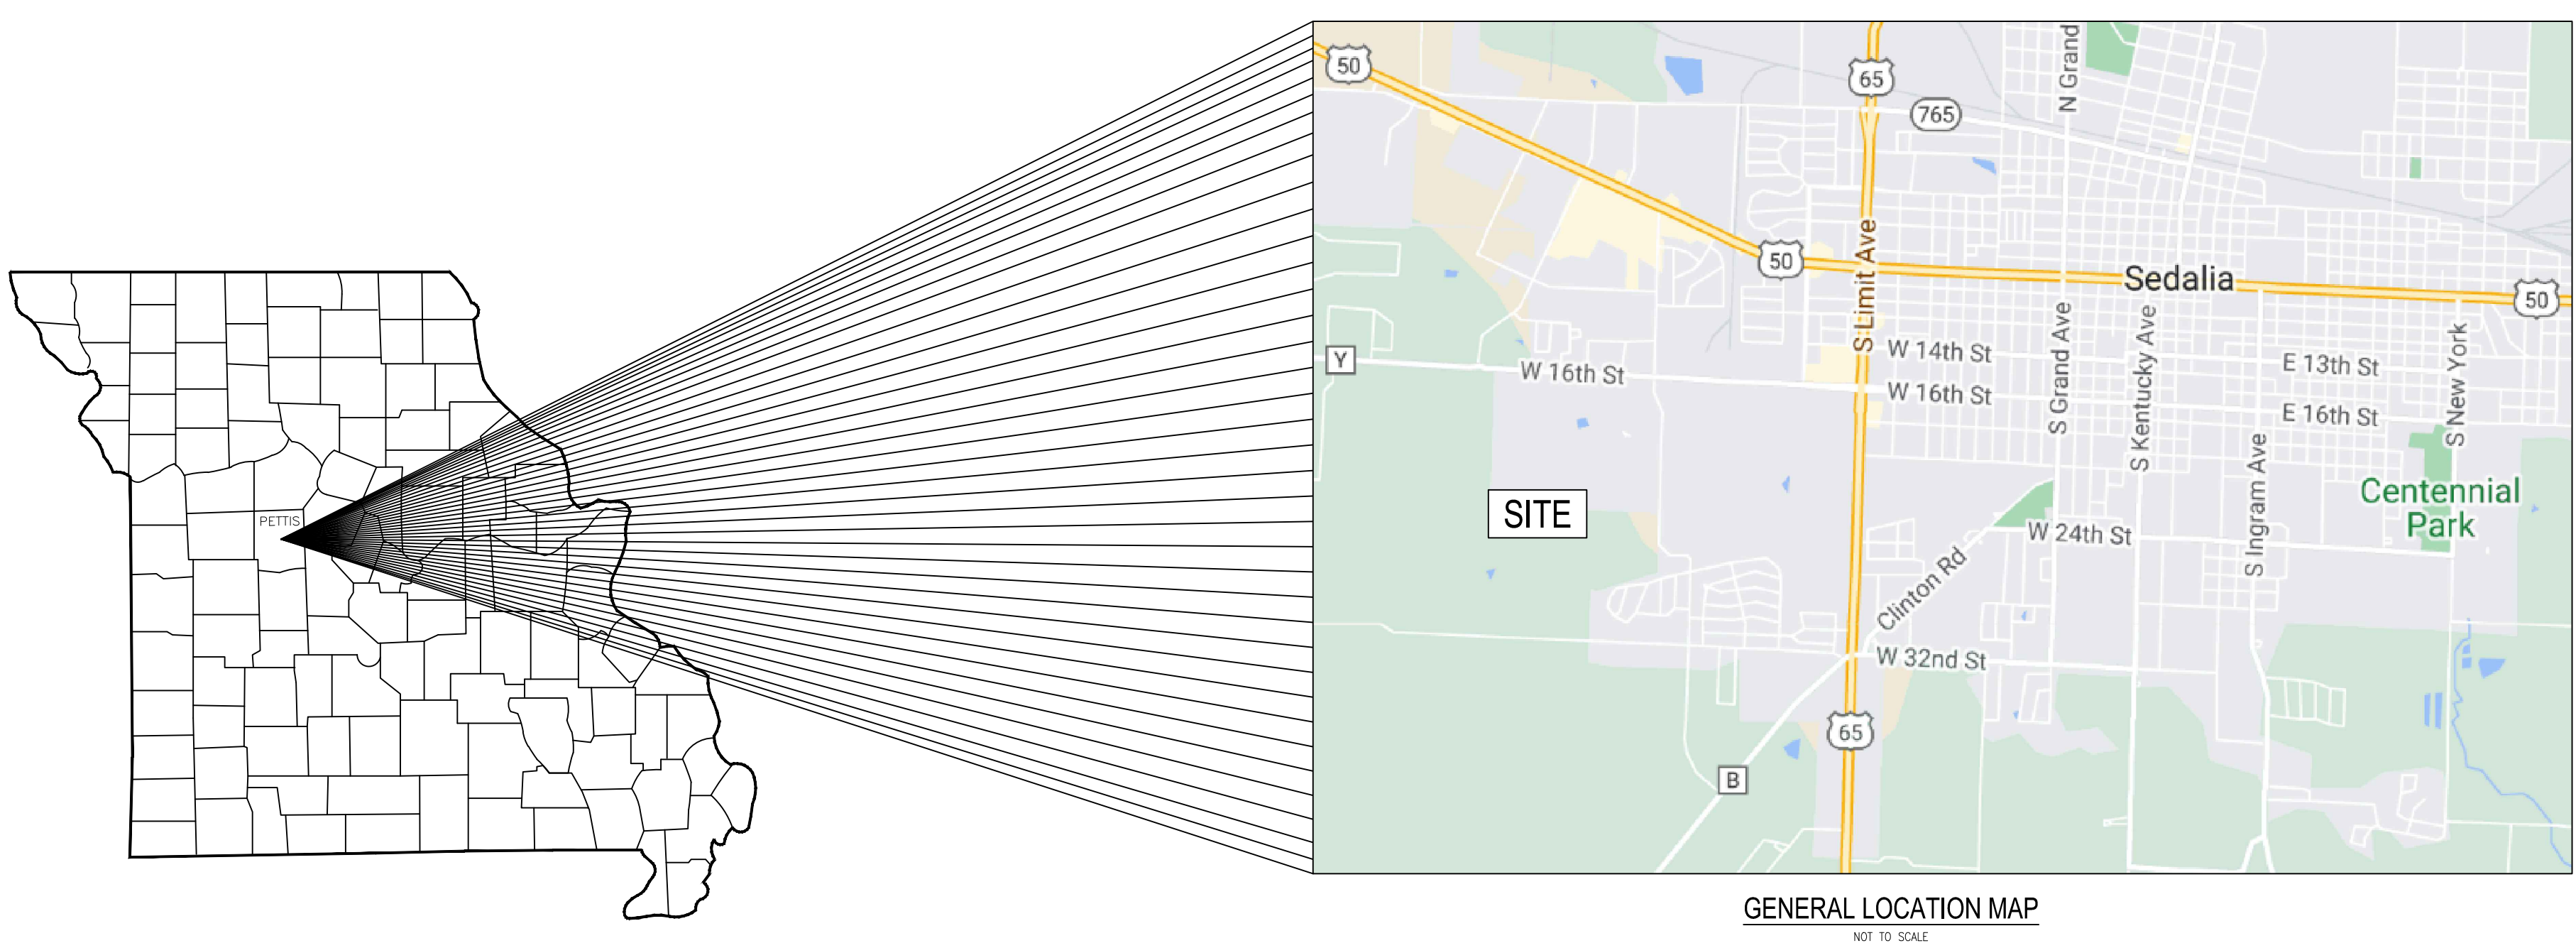

INDEX OF SHEETS

COVER SHEET	C-001
OVERALL LAYOUT	C-002
OVERALL PHASING	C-003
STREET & GRADING	
STREET & GRADING PLAN	C-101 - C-102
STREET PROFILES	C-103 - C-106
DETAILS	C-107 - C-108
SANITARY SEWER	
SANITARY SEWER PLAN	C-201 - C-204
SANITARY SEWER PROFILES	C-205 - C-212
SANITARY DETAILS	C-213 - C-215
WATERLINE	
WATERLINE PLAN	C-301 - C-302
WATERLINE DETAILS	C-303 - C-305
ELECTRIC	
SCHEDULES & SPECIFICATIONS	ME1
CAMP SITE ELECTRIC PLAN	E1 - E2
ELECTRIC RISER DIAGRAMS	E3 - E8
ELECTRIC PANEL	E9 - E11

UTILITY NOTE

MISSOURI ONE CALL SYSTEM, INC. WAS USED TO LOCATE EXISTING UTILITIES. (1-800-344-7483). THE LOCATIONS OF UNDERGROUND UTILITIES SHOWN ARE BASED UPON ABOVE GROUND STRUCTURES AND MARKINGS PROVIDED BY OTHERS. LOCATIONS OF UNDERGROUND UTILITIES/STRUCTURES MAY VARY FROM THE LOCATIONS SHOWN AND ADDITIONAL BURIED UTILITIES/STRUCTURES MAY BE ENCOUNTERED. NO EXCAVATIONS WERE MADE DURING THE PROGRESS OF THIS SURVEY TO LOCATE BURIED UTILITIES/STRUCTURES. BEFORE EXCAVATIONS ARE BEGUN, THE OFFICES OF THE UTILITY PROVIDERS SHALL BE CONTACTED FOR VERIFICATION OF UTILITY TYPE AND FIELD VERIFICATION.


UTILITY CONTACTS

WATER
CHRIS DAVIES, PE
PUBLIC WORKS DIRECTOR
CITY OF SEDALIA
200 SOUTH OSAGE AVE.
SEDALIA, MO 65301
660-827-3000

SANITARY SEWER
CHRIS DAVIES, PE
PUBLIC WORKS DIRECTOR
CITY OF SEDALIA
200 SOUTH OSAGE AVE.
SEDALIA, MO 65301
660-827-3000



STATE OF MISSOURI
MIKE KEHOE,
GOVERNOR

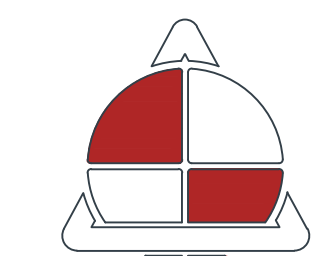

ALLSTATE
CONSULTANTS

allstateconsultants.net

3312 LEMONE INDUSTRIAL BLVD.
COLUMBIA, MO 65201
(573) 875-8799

P.O. BOX 156, 30601 HIGHWAY 5
MARCELINE, MO 64658
(660) 376-2941

410 SE THIRD ST., SUITE 103C
LEE'S SUMMIT, MO 64063
(816) 895-2310

MISSOURI STATE CERTIFICATE
OF AUTHORITY #2007004004
REUSE OF THIS DRAWING IN ANY MANNER IS
STRICTLY PROHIBITED WITHOUT THE WRITTEN
APPROVAL OF
ALLSTATE CONSULTANTS LLC

OFFICE OF ADMINISTRATION
DIVISION OF FACILITIES
MANAGEMENT,
DESIGN AND CONSTRUCTION

MISSOURI
STATE FAIRGROUNDS

NEW CAMPGROUND
CONSTRUCTION PLANS

MISSOURI
STATE FAIRGROUNDS
2503 W 16th STREET
SEDALIA, MO

PROJECT # F2307-01
SITE # 1501
ASSET # 3511501153

REVISION: _____
DATE: _____
REVISION: _____
DATE: _____
REVISION: _____
DATE: _____
ISSUE DATE: 11/11/2025

CAD DWG FILE: 23117.02-COVER.dwg
DRAWN BY: DEP
CHECKED BY: CWS
DESIGNED BY: BPH


SHEET TITLE:

COVER

SHEET NUMBER:


C-001

1 OF 43
11/11/2025

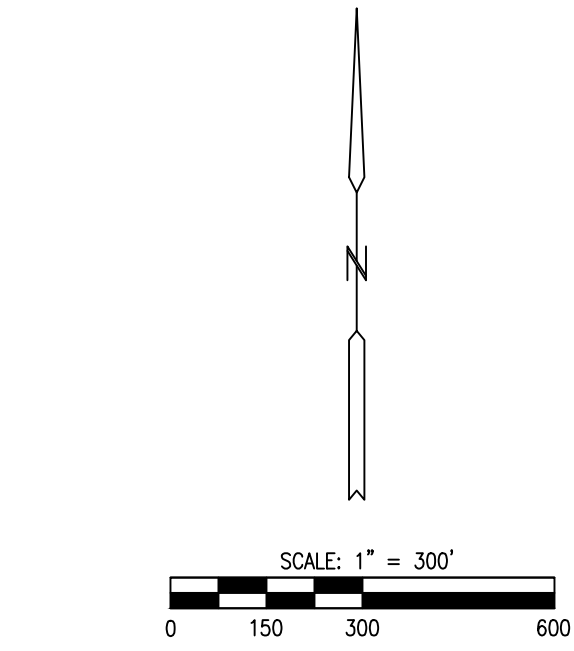


CONVENTIONAL SYMBOLS

- IRON PIPE (UNLESS NOTED OTHERWISE)
- EXIST. CENTERLINE
- EXIST. GRAVEL
- EXIST. PAVEMENT
- FM EXIST. FORCE MAIN
- S EXIST. SANITARY SEWER
- W EXIST. WATERLINE
- G EXIST. GAS LINE
- OE EXIST. OVERHEAD ELECTRIC
- UE EXIST. UNDERGROUND ELECTRIC
- FO EXIST. FIBER OPTIC
- T EXIST. TELEPHONE
- SS EXIST. STORM SEWER
- X EXIST. FENCE
- EXIST. TREE LINE
- EXIST. ADJACENT LOT LINE
- FLOWLINE
- EXISTING CONCRETE
- X PROPOSED FENCE
- FM PROPOSED FORCE MAIN
- SAN PROPOSED SANITARY SEWER PROPOSED
- W 3 PROPOSED 3" WATERLINE
- W 6 PROPOSED 6" WATERLINE
- W 8 PROPOSED 8" WATERLINE
- PROPOSED STORM SEWER
- E — E PROPOSED UNDERGROUND - PRIMARY
- ES — ES — ES PROPOSED UNDERGROUND - SECONDARY
- PROPOSED PAVEMENT
- 700 PROPOSED TREE LINE
- 700 EXIST. CONTOURS
- PROPOSED CONTOURS
- PROPOSED PAVEMENT
- PROPOSED SIDEWALK
- PROPOSED DIVERSION BERM
- PROPOSED SILT FENCE
- PROPOSED EASEMENT
- TCE TEMPORARY CONSTRUCTION EASEMENT
- EXIST. SANITARY MANHOLE
- EXIST. SANITARY CLEAN OUT
- EXIST. WATER METER
- EXIST. WATER VALVE
- EXIST. PRESSURE REDUCING EXIST.
- VALVE FIRE HYDRANT
- EXIST. POWER POLE
- EXIST. GATE POST
- EXIST. GUY WIRE ANCHOR
- EXIST. GAS VALVE
- EXIST. GAS METER
- EXIST. ELECTRIC METER
- EXIST. ELECTRIC PEDESTAL
- EXIST. RV ELECTRIC PEDESTAL
- EXIST. ELECTRIC TRANSFORMER
- EXIST. SIGN
- BENCHMARK
- DRILL HOLE
- △ RIGHT-OF-WAY MARKER
- EXIST. CONIFEROUS TREE
- EXIST. DECIDUOUS TREE
- EXIST. TELEPHONE PEDESTAL
- EXIST. TELEPHONE MARKER
- DITCH CHECK
- PROPOSED SANITARY MANHOLE
- PROPOSED CLEANOUT
- PROPOSED TRANSFORMER
- PROPOSED ELECTRIC PEDESTAL
- PROPOSED RV ELECTRIC PEDESTAL
- PROPOSED FIRE HYDRANT
- PROPOSED SPIGOT
- PROPOSED AIR RELEASE VALVE

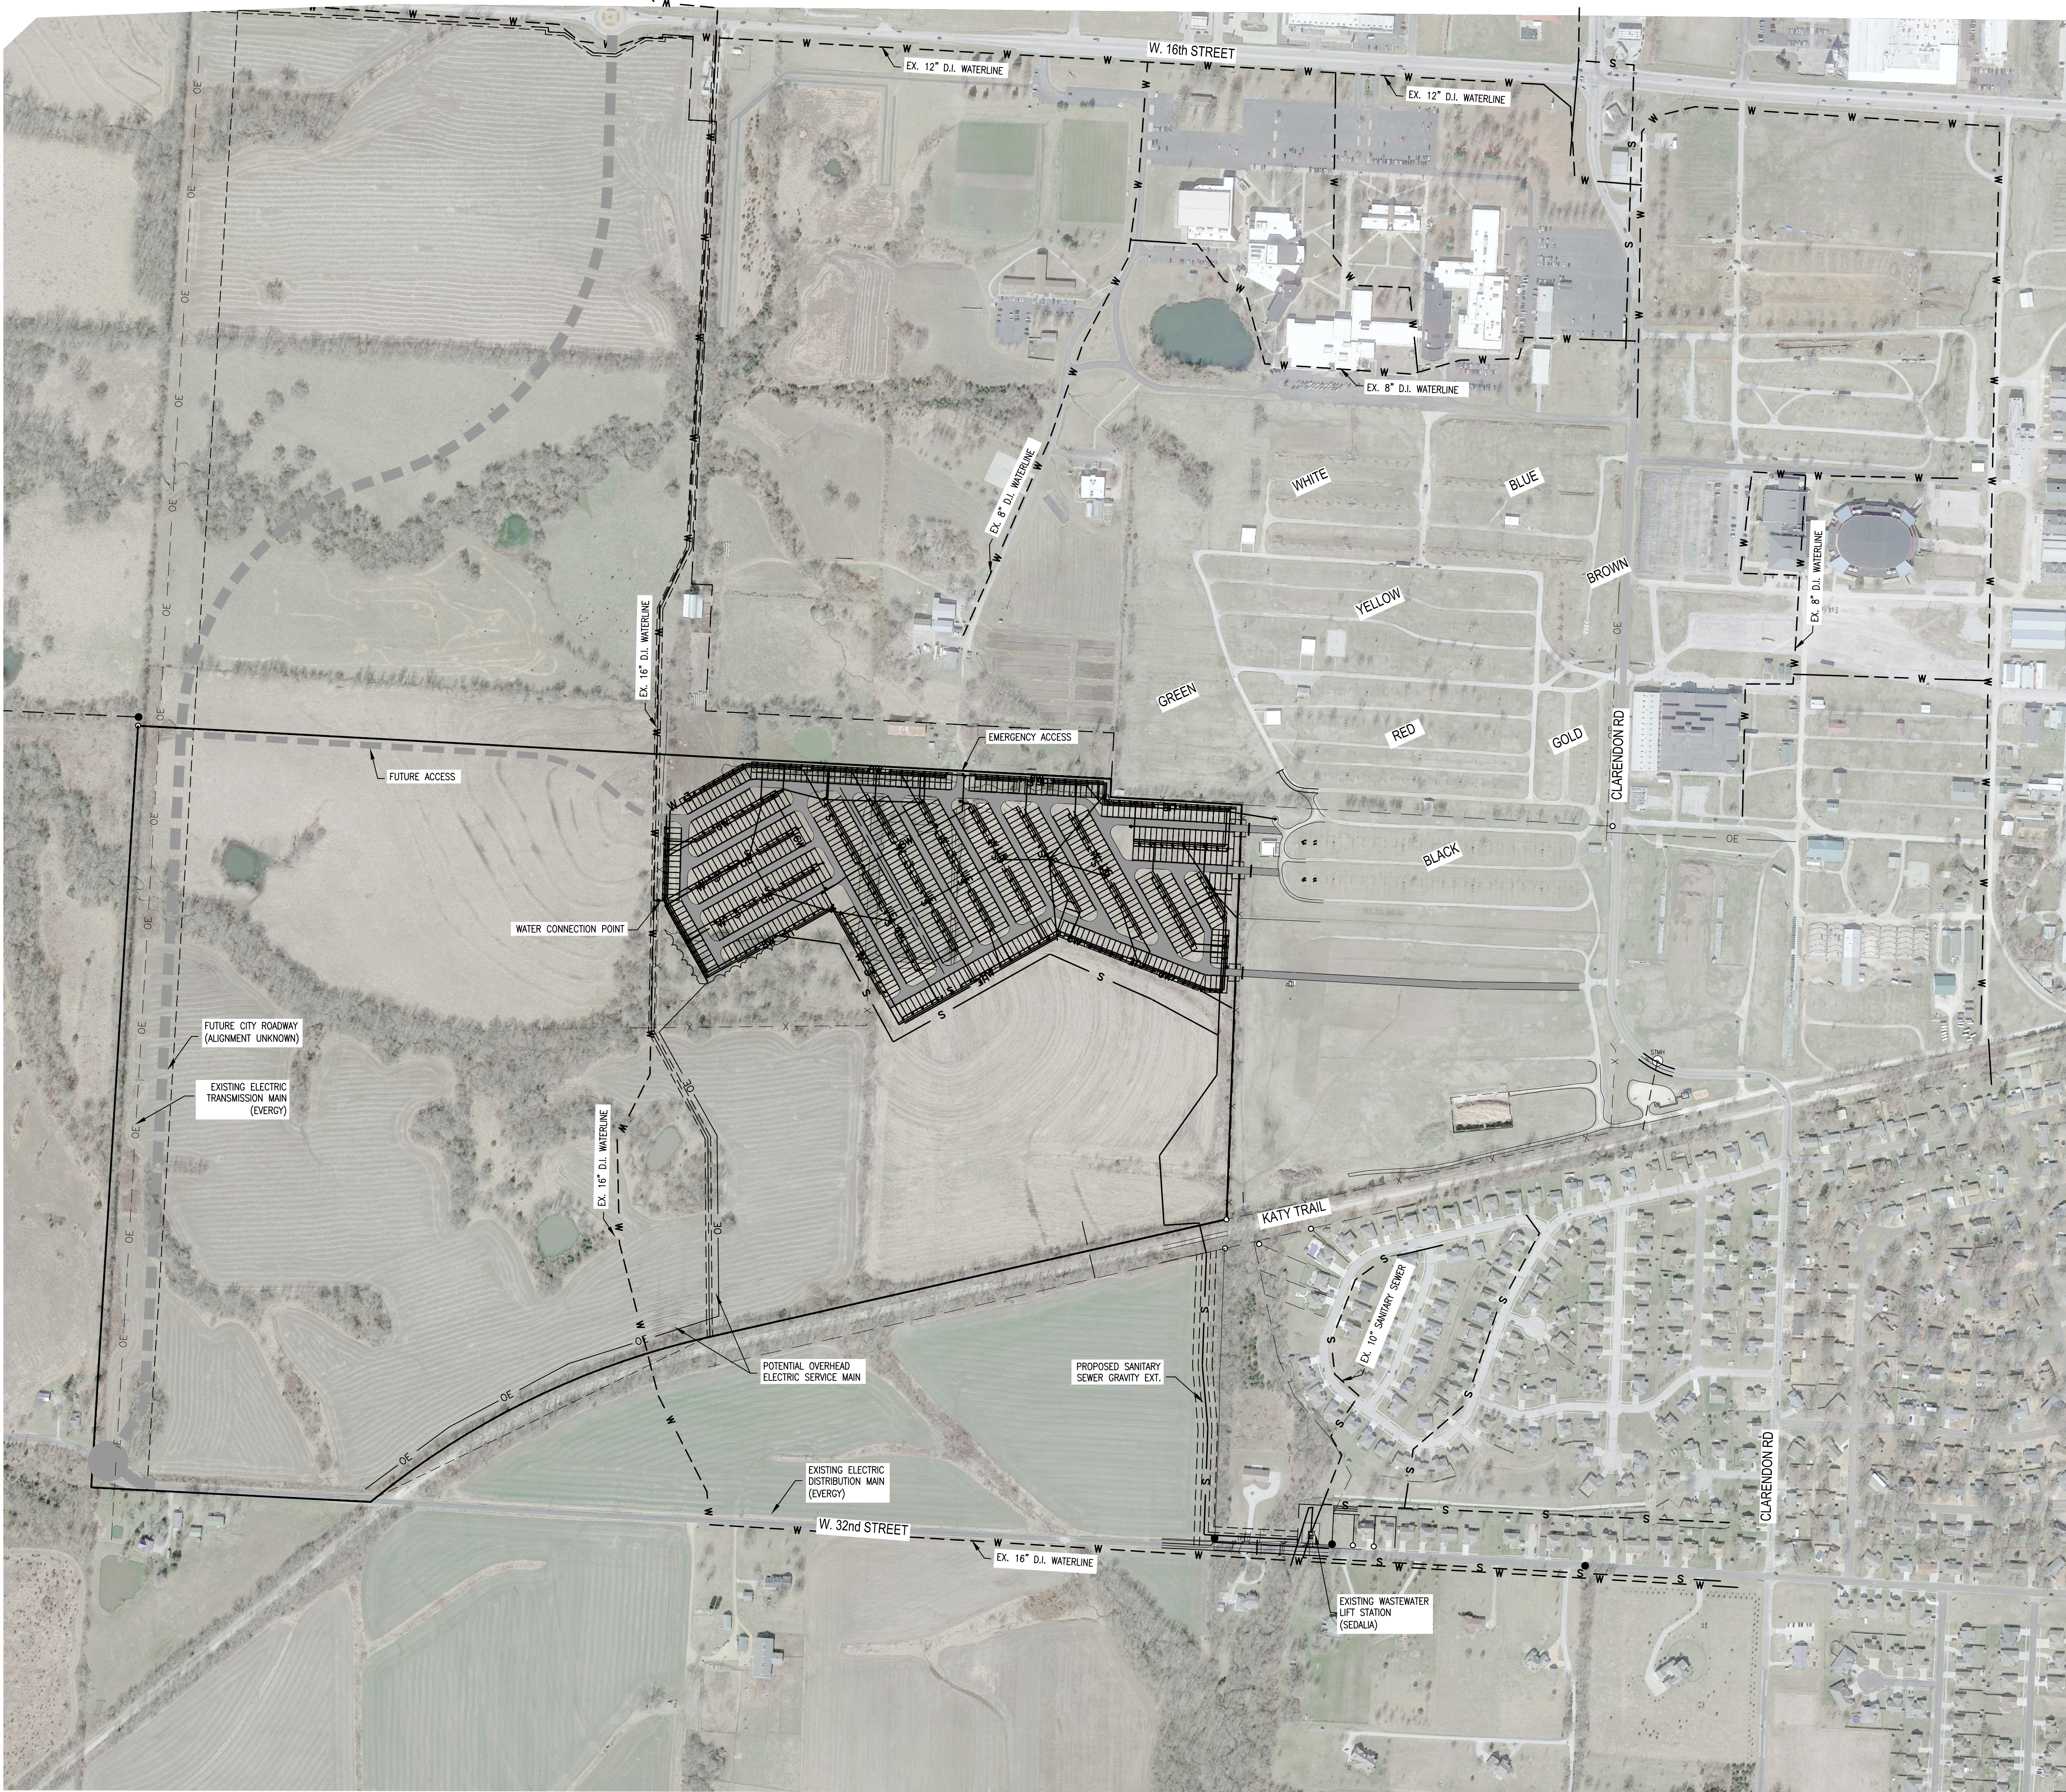

STATE OF MISSOURI
MIKE KEHOE,
GOVERNOR

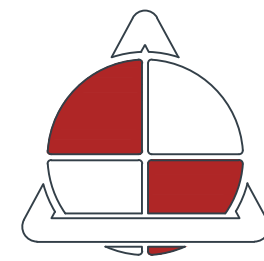

ALLSTATE
CONSULTANTS
allstateconsultants.net
3312 LEMONE INDUSTRIAL BLVD.
COLUMBIA, MO 65201
(573) 875-8799
P.O. BOX 156, 30601 HIGHWAY 5
MARCELINE, MO 64658
(660) 376-2941
410 SE THIRD ST., SUITE 103C
LEE'S SUMMIT, MO 64063
(816) 895-2310

MISSOURI STATE CERTIFICATE
OF AUTHORITY #2007004004
REUSE OF THIS DRAWING IN ANY MANNER IS
STRICTLY PROHIBITED WITHOUT THE WRITTEN
APPROVAL OF
ALLSTATE CONSULTANTS LLC

OFFICE OF ADMINISTRATION
DIVISION OF FACILITIES
MANAGEMENT,
DESIGN AND CONSTRUCTION

MISSOURI
STATE FAIRGROUNDS

NEW CAMPGROUND
CONSTRUCTION PLANS

MISSOURI
STATE FAIRGROUNDS
2503 W 16th STREET
SEDALIA, MO



PROJECT # F2307-01
SITE # 1501
ASSET # 3511501153

REVISION: _____
DATE: _____
REVISION: _____
DATE: _____
REVISION: _____
DATE: _____
ISSUE DATE: 11/11/2025

CAD DWG FILE: 23117.02-SHEETSBASE
DRAWN BY: DEP
CHECKED BY: CWS
DESIGNED BY: BPH

SHEET TITLE:
OVERALL LAYOUT

SHEET NUMBER:
C-002

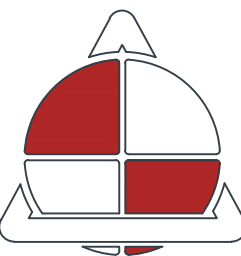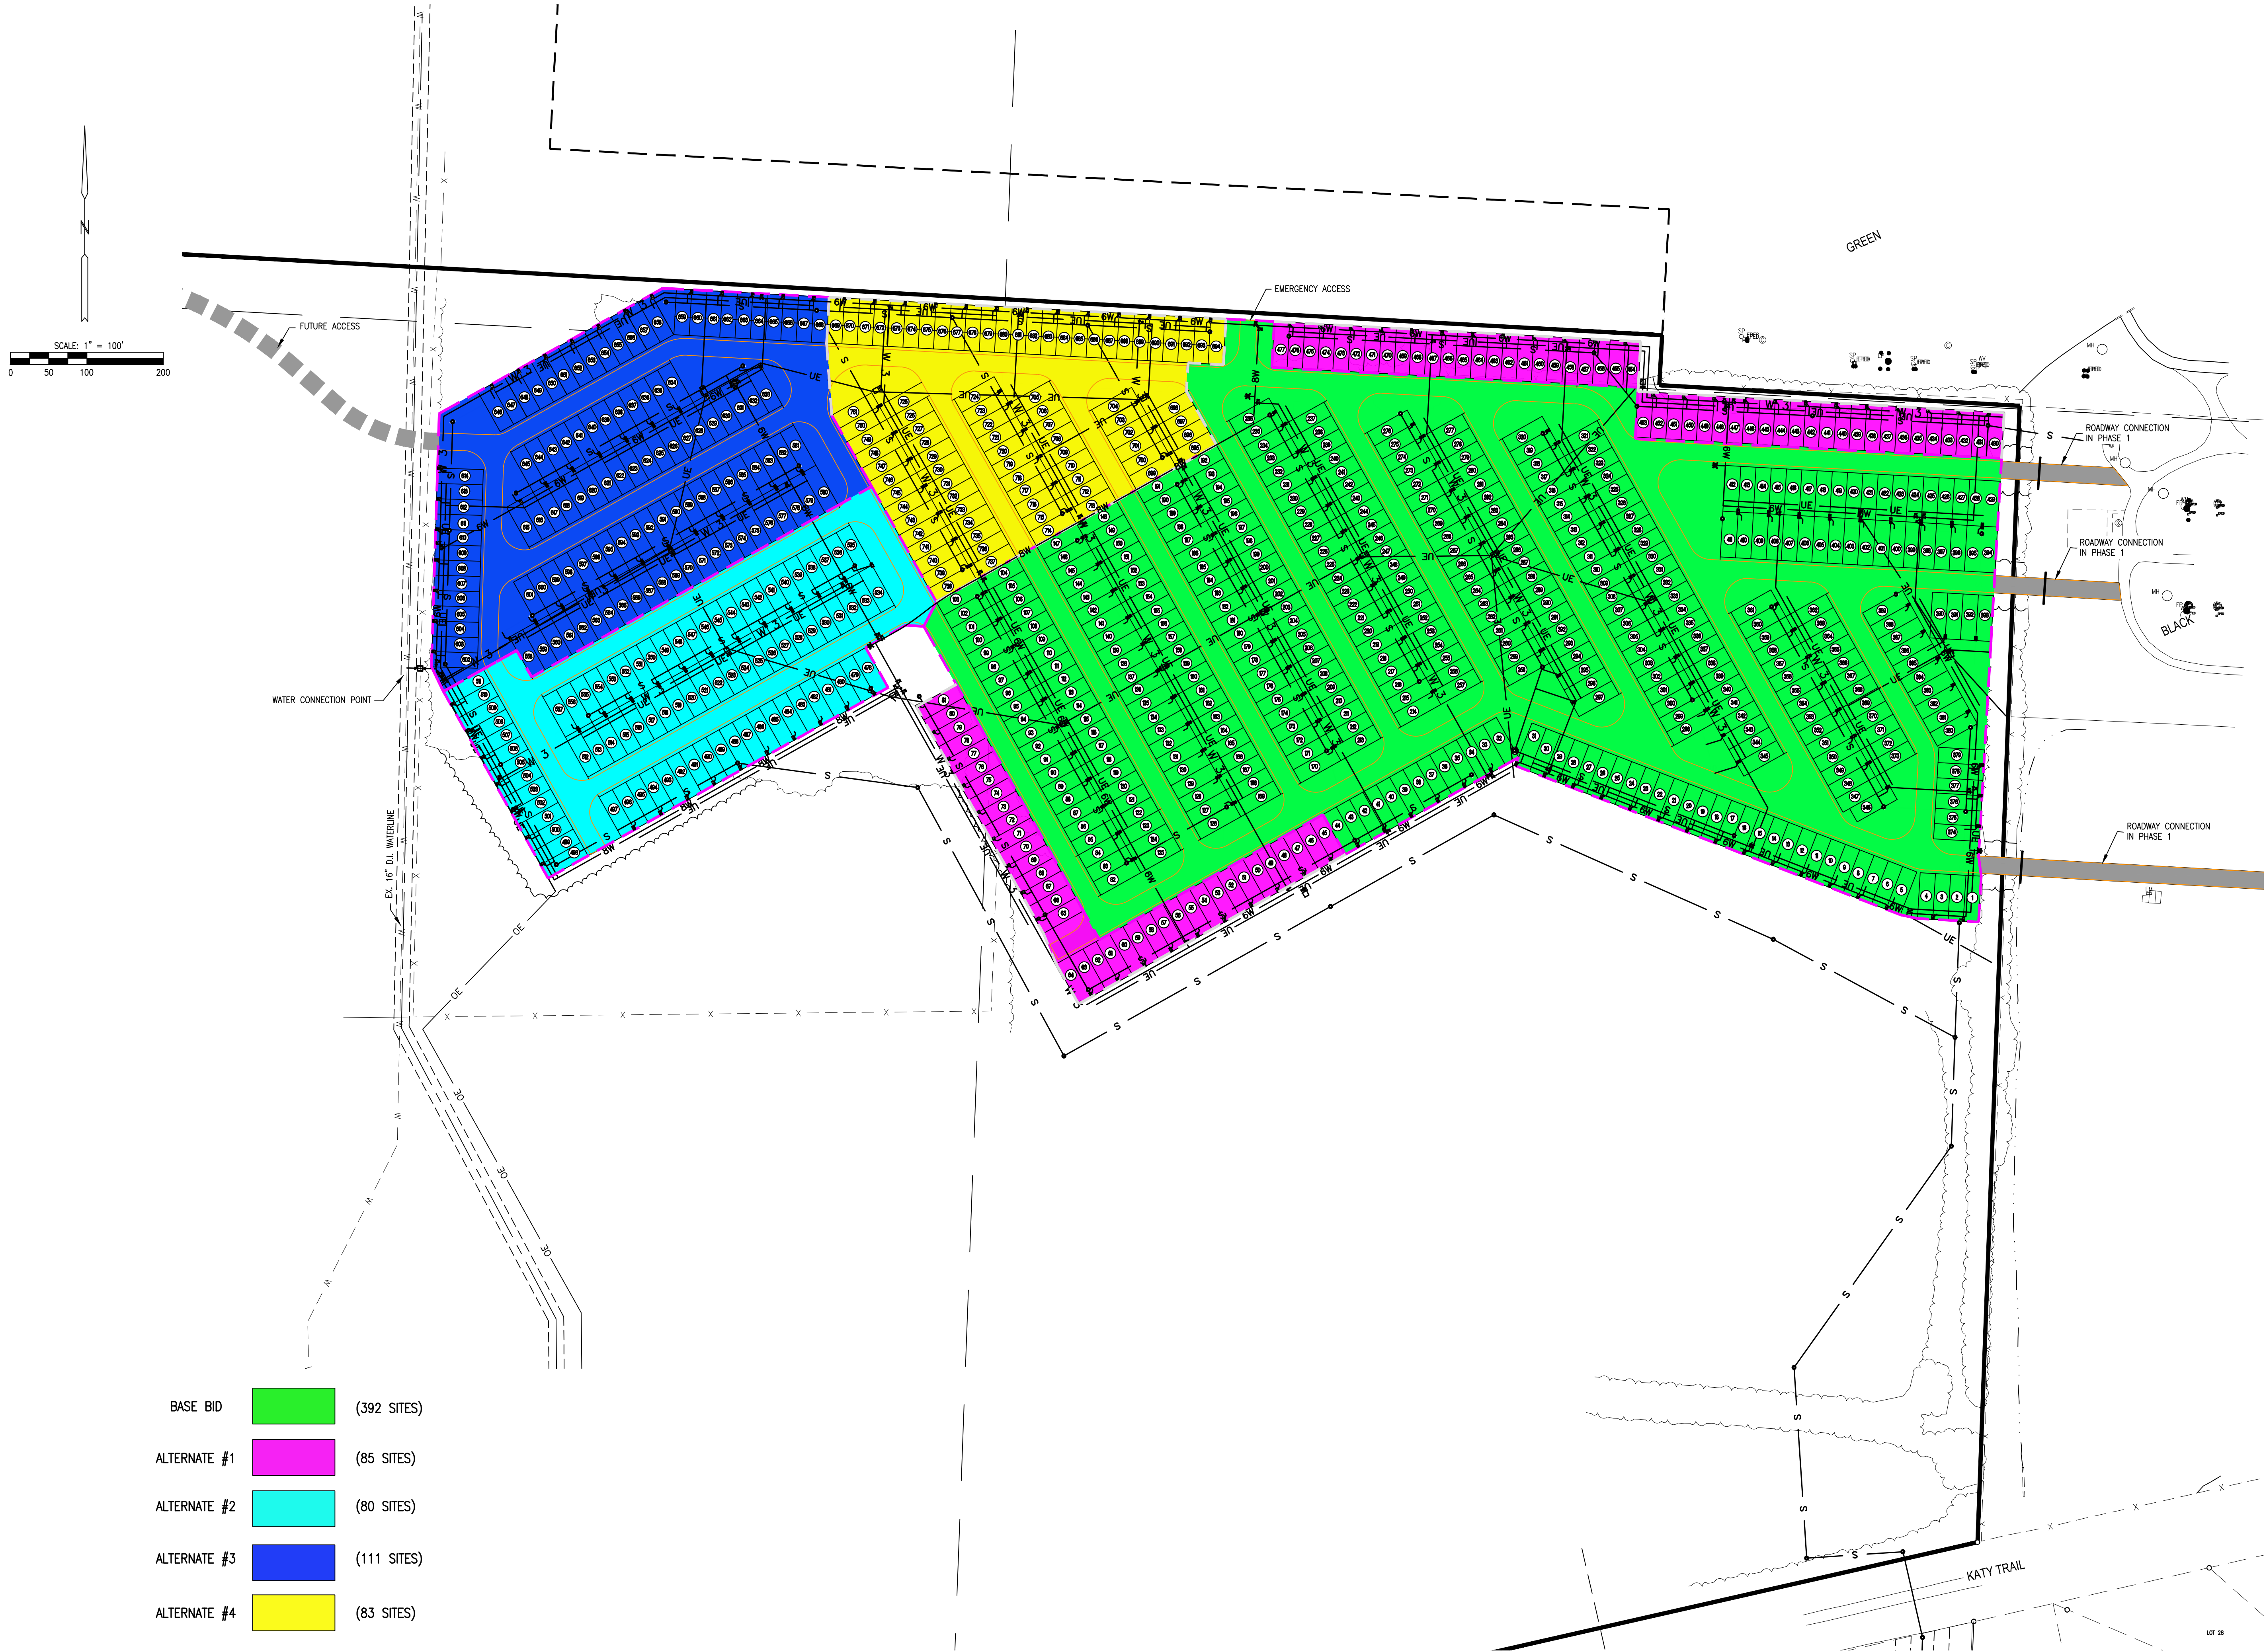

ALLSTATE
CONSULTANTS

allstateconsultants.net

3312 LEMONE INDUSTRIAL BLVD.
COLUMBIA, MO 65201
(573) 875-8799

P.O. BOX 156, 30601 HIGHWAY 5
MARCELINE, MO 64658
(660) 376-2941

410 SE THIRD ST., SUITE 103C
LEE'S SUMMIT, MO 64063
(816) 895-2310

MISSOURI STATE CERTIFICATE
OF AUTHORITY #2007004004
REUSE OF THIS DRAWING IN ANY MANNER IS
STRICTLY PROHIBITED WITHOUT THE WRITTEN
APPROVAL OF
ALLSTATE CONSULTANTS LLC

OFFICE OF ADMINISTRATION
DIVISION OF FACILITIES
MANAGEMENT,
DESIGN AND CONSTRUCTION

MISSOURI
STATE FAIRGROUNDS

NEW CAMPGROUND
CONSTRUCTION PLANS

MISSOURI
STATE FAIRGROUNDS
2503 W 16th STREET
SEDALIA, MO

PROJECT # F2307-01
SITE # 1501
ASSET # 3511501153

REVISION: _____
DATE: _____
REVISION: _____
DATE: _____
REVISION: _____
DATE: _____

ISSUE DATE: 11/11/2025



CAD DWG FILE: 23117.02-SHEETSBASE
DRAWN BY: DEP
CHECKED BY: CWS
DESIGNED BY: BPH

SHEET TITLE:
OVERALL PHASING

SHEET NUMBER:

C-003


3 OF 43
11/11/2025

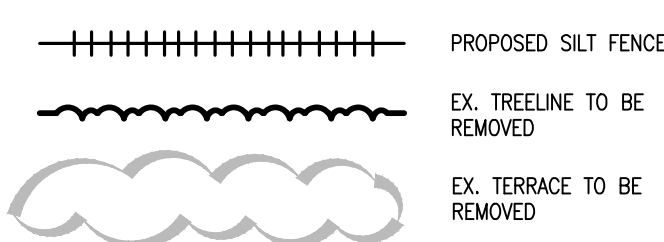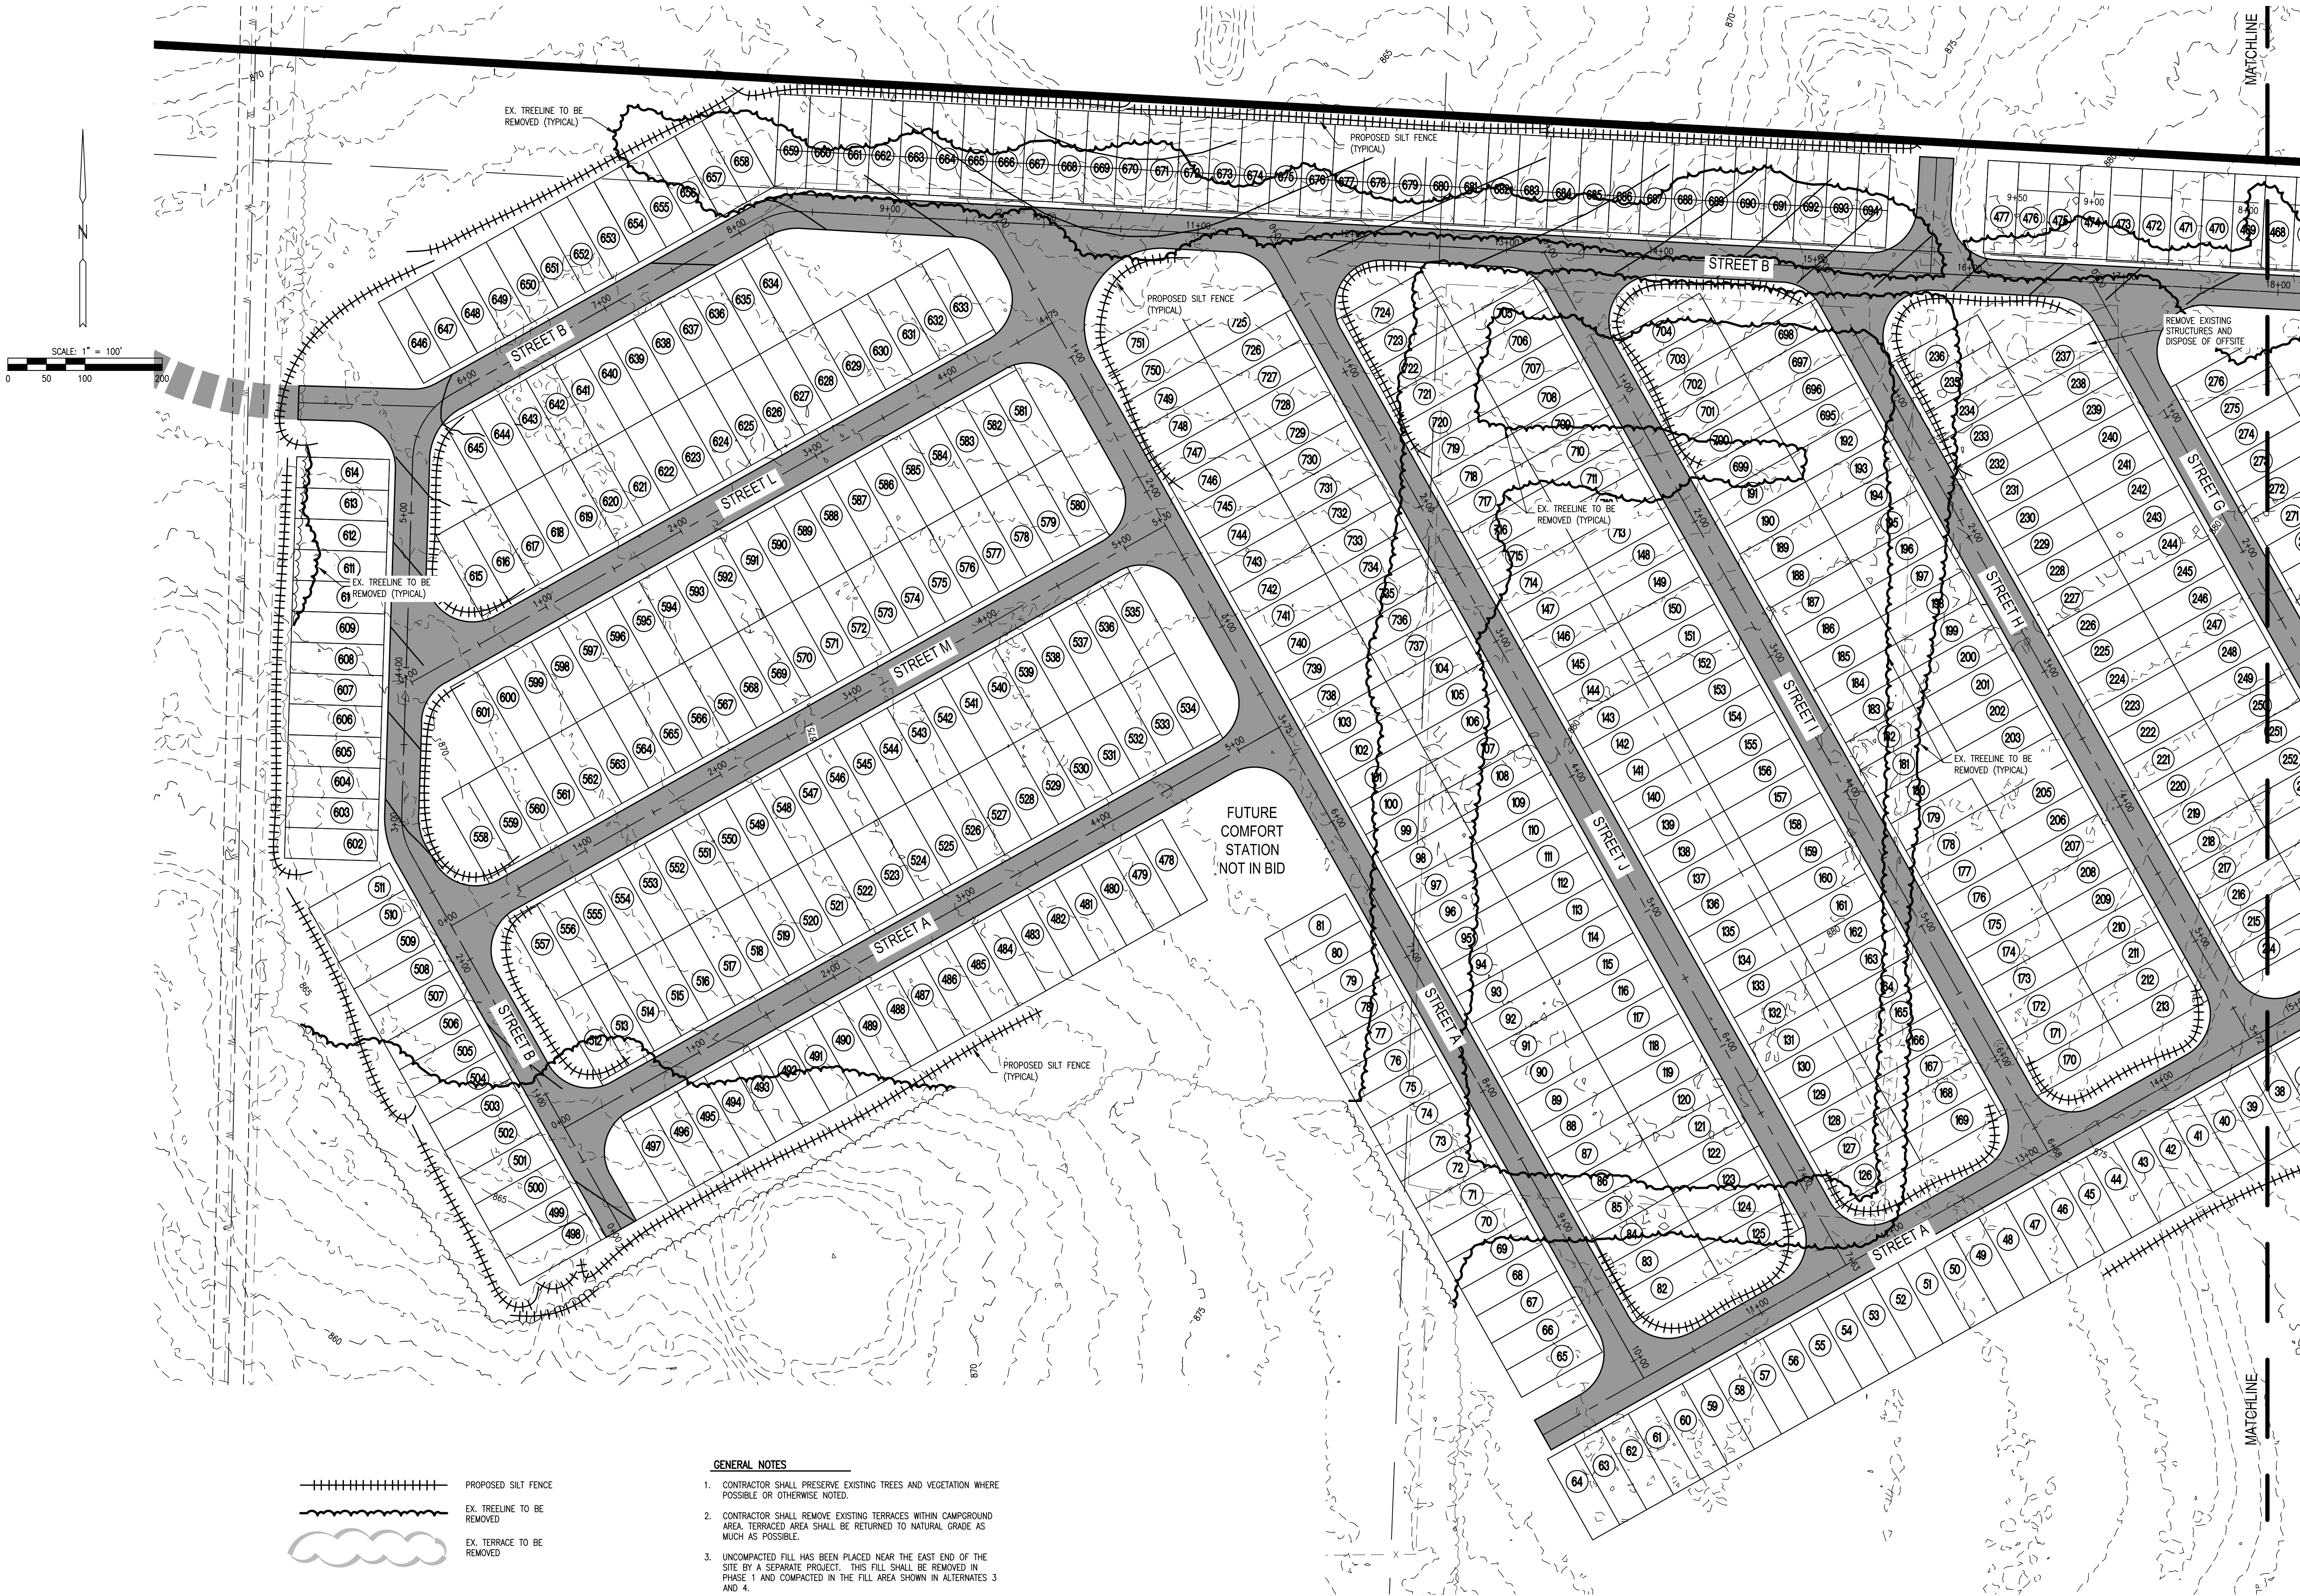

GENERAL NOTES

- CONTRACTOR SHALL PRESERVE EXISTING TREES AND VEGETATION WHERE POSSIBLE OR OTHERWISE NOTED.
- CONTRACTOR SHALL REMOVE EXISTING TERRACES WITHIN CAMPGROUND AREA. TERRACED AREA SHALL BE RETURNED TO NATURAL GRADE AS MUCH AS POSSIBLE.
- UNCOMPACTED FILL HAS BEEN PLACED NEAR THE EAST END OF THE SITE BY A SEPARATE PROJECT. THIS FILL SHALL BE REMOVED IN PHASE 1 AND COMPACTED IN THE FILL AREA SHOWN IN ALTERNATES 3 AND 4.
- EXCEPT AS CALLED OUT IN NOTES 2 AND 3 ABOVE, ONLY MINOR GRADING IS ANTICIPATED TO SHAPE INDIVIDUAL CAMPSITES TO FIT THE TYPICAL CAMPSITE GRADING DETAIL SHOWN ON SHEET C108.

STATE OF MISSOURI
MIKE KEHOE,
GOVERNOR

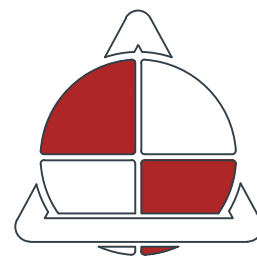

ALLSTATE
CONSULTANTS

allstateconsultants.net

3312 LEMONE INDUSTRIAL BLVD.
COLUMBIA, MO 65201
(573) 875-8799

P.O. BOX 156, 30601 HIGHWAY 5
MARCELINE, MO 64658
(660) 376-2941

410 SE THIRD ST., SUITE 103C
LEE'S SUMMIT, MO 64063
(816) 895-2310

MISSOURI STATE CERTIFICATE
OF AUTHORITY #2007004004
REUSE OF THIS DRAWING IN ANY MANNER IS
STRICTLY PROHIBITED WITHOUT THE WRITTEN
APPROVAL OF
ALLSTATE CONSULTANTS LLC

OFFICE OF ADMINISTRATION
DIVISION OF FACILITIES
MANAGEMENT,
DESIGN AND CONSTRUCTION

MISSOURI
STATE FAIRGROUNDS

NEW CAMPGROUND
CONSTRUCTION PLANS

MISSOURI
STATE FAIRGROUNDS
2503 W 16th STREET
SEDALIA, MO

PROJECT # F2307-01
SITE # 1501
ASSET # 3511501153

REVISION: _____
DATE: _____
REVISION: _____
DATE: _____
REVISION: _____
DATE: _____

ISSUE DATE: 11/11/2025


CAD DWG FILE: 231117.02-SHEETSBASE
DRAWN BY: DEP
CHECKED BY: CWS
DESIGNED BY: BPH

SHEET TITLE:
**STREET AND
GRADING**

SHEET NUMBER:


C-101

4 OF 43
11/11/2025

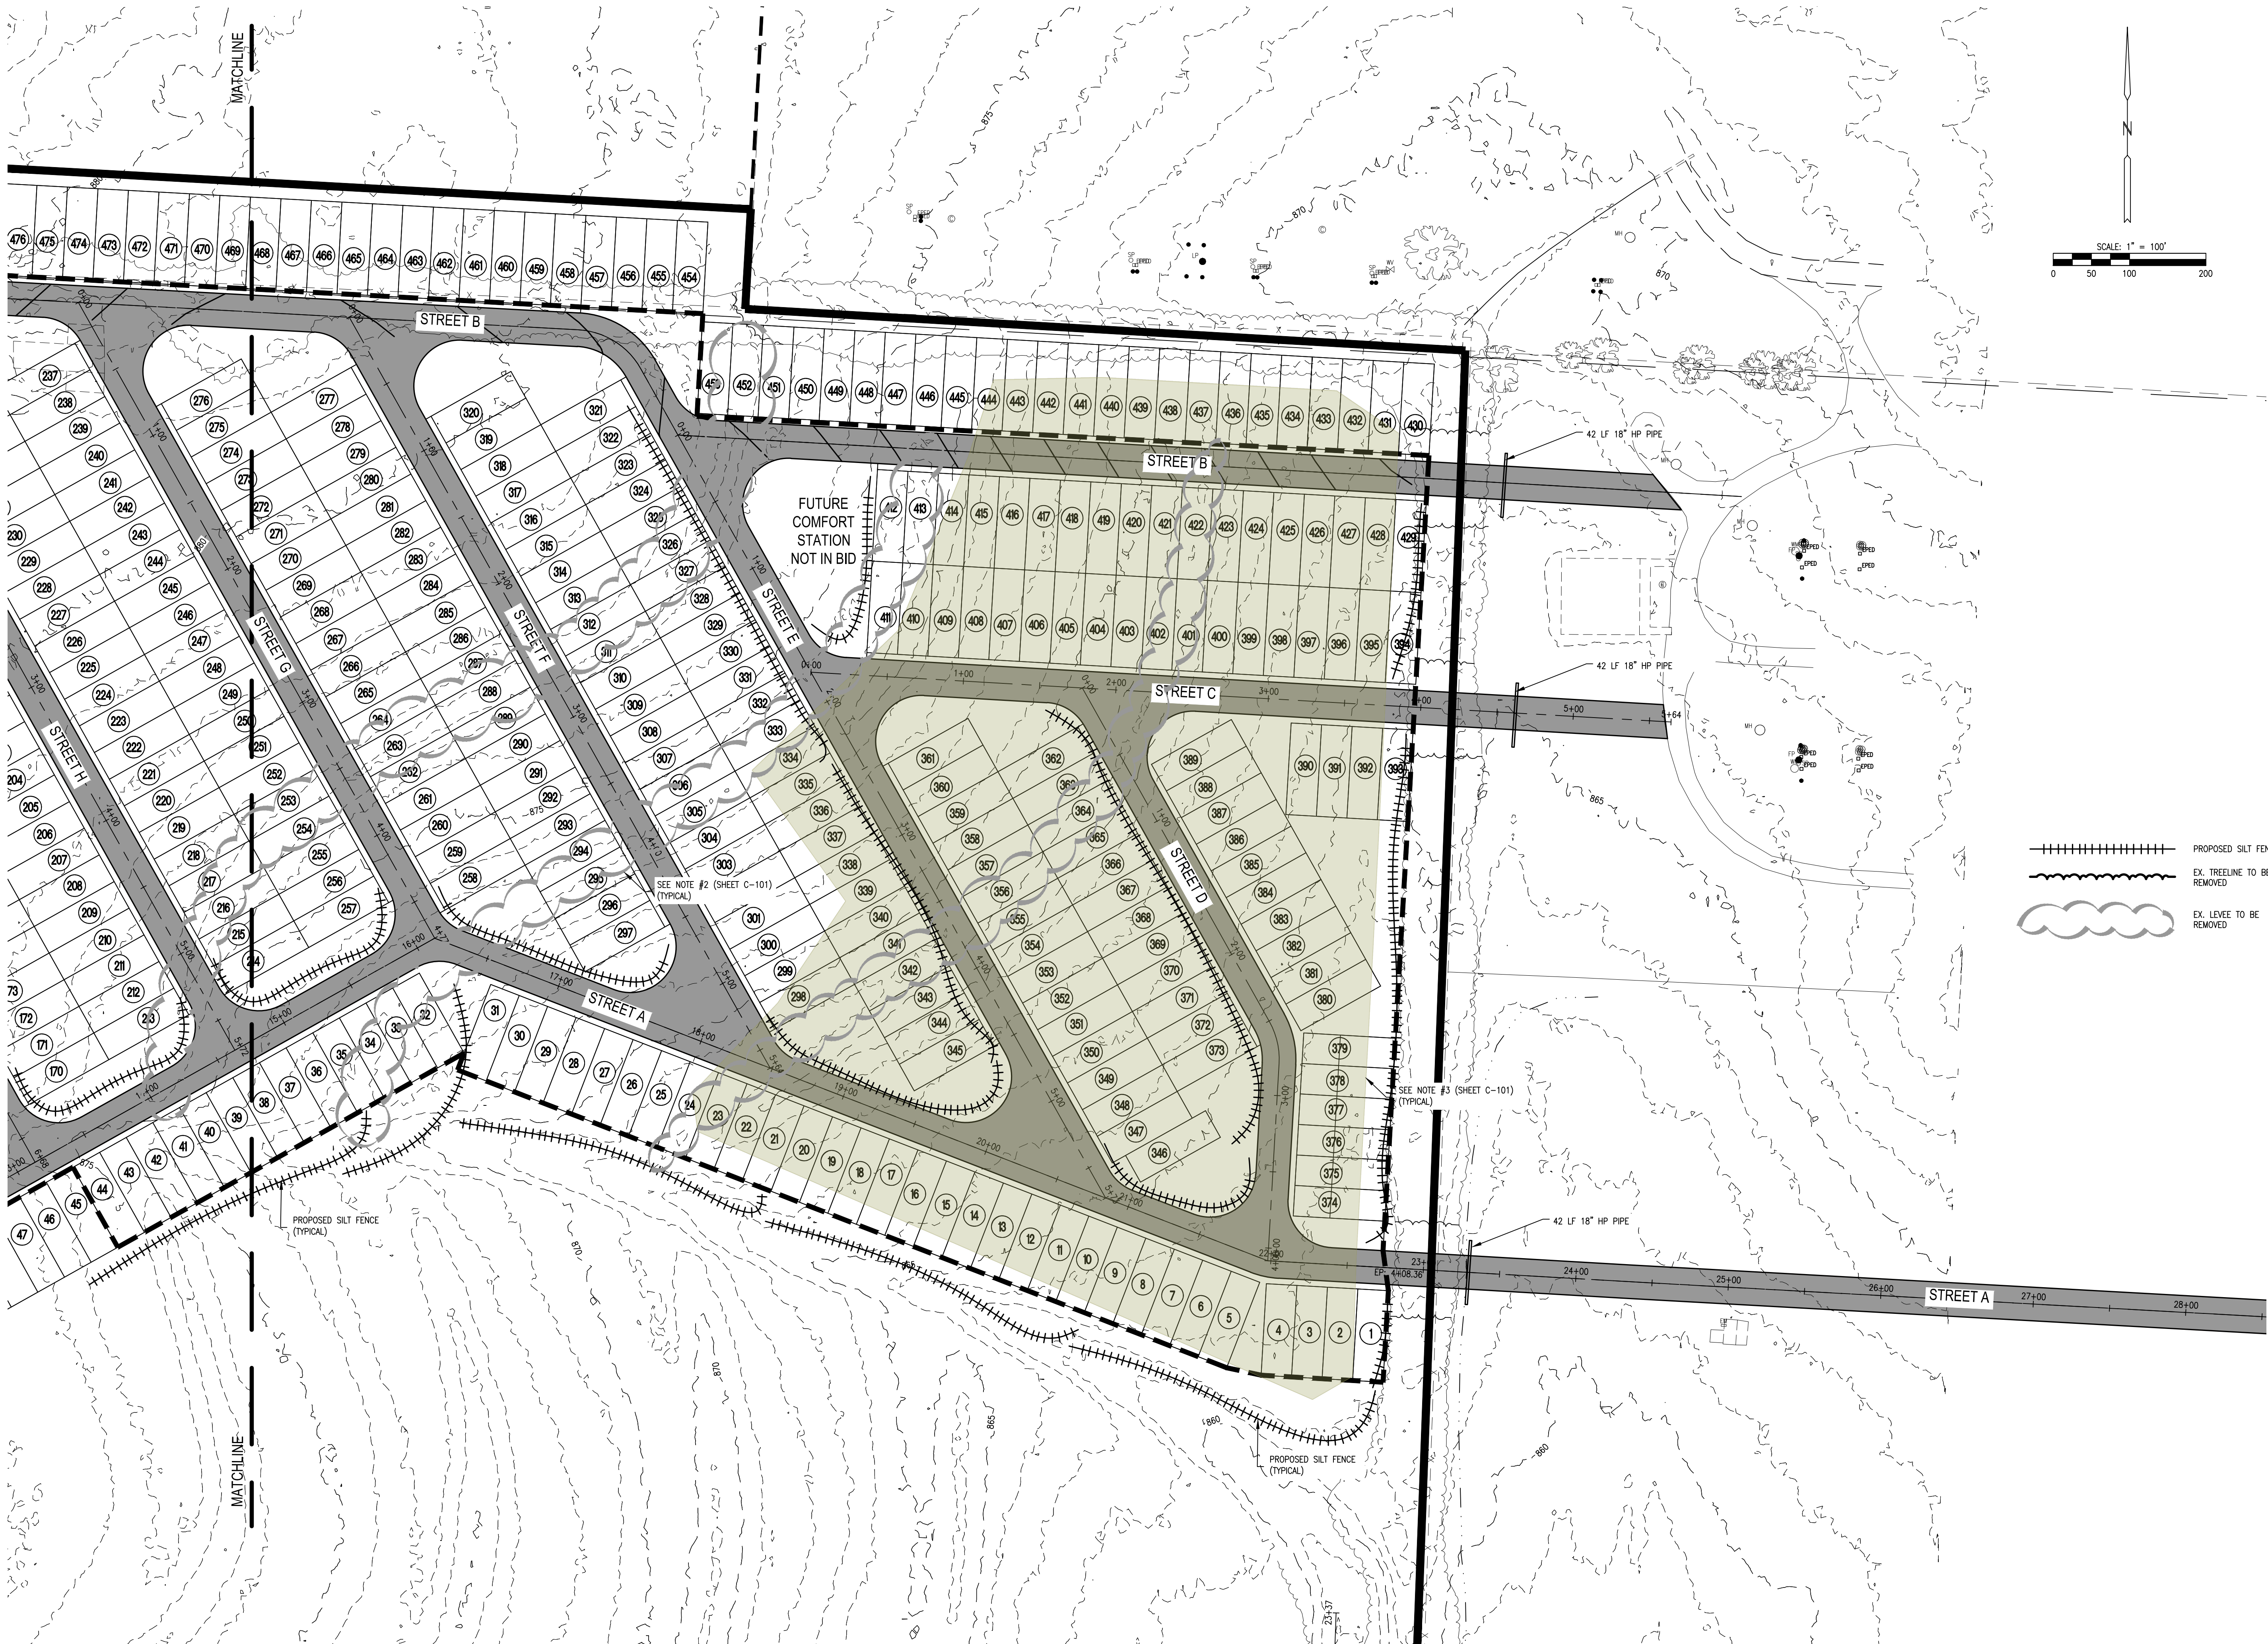

- PROPOSED SILT FENCE
- EX. TREELINE TO BE REMOVED
- EX. LEVEE TO BE REMOVED

STATE OF MISSOURI
MIKE KEHOE,
GOVERNOR

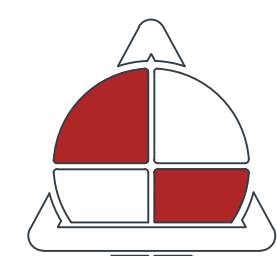

ALLSTATE CONSULTANTS
allstateconsultants.net
3312 LEMONE INDUSTRIAL BLVD.
COLUMBIA, MO 65201
(573) 875-8799
P.O. BOX 156, 30601 HIGHWAY 5
MARCELINE, MO 64658
(660) 376-2941
410 SE THIRD ST., SUITE 103C
LEE'S SUMMIT, MO 64063
(816) 895-2310
MISSOURI STATE CERTIFICATE
OF AUTHORITY #2007004004
REUSE OF THIS DRAWING IN ANY MANNER IS
STRICTLY PROHIBITED WITHOUT THE WRITTEN
APPROVAL OF
ALLSTATE CONSULTANTS LLC

OFFICE OF ADMINISTRATION
DIVISION OF FACILITIES
MANAGEMENT,
DESIGN AND CONSTRUCTION

MISSOURI
STATE FAIRGROUNDS

NEW CAMPGROUND
CONSTRUCTION PLANS

MISSOURI
STATE FAIRGROUNDS
2503 W 16th STREET
SEDALIA, MO

PROJECT # F2307-01
SITE # 1501
ASSET # 3511501153

REVISION: _____
DATE: _____
REVISION: _____
DATE: _____
REVISION: _____
DATE: _____
ISSUE DATE: 11/11/2025





CAD DWG FILE: 231117.02-SHEETSBASE
DRAWN BY: DEP
CHECKED BY: CWS
DESIGNED BY: BPH

SHEET TITLE:
**STREET AND
GRADING**



SHEET NUMBER:

C-102

5 OF 43
11/11/2025

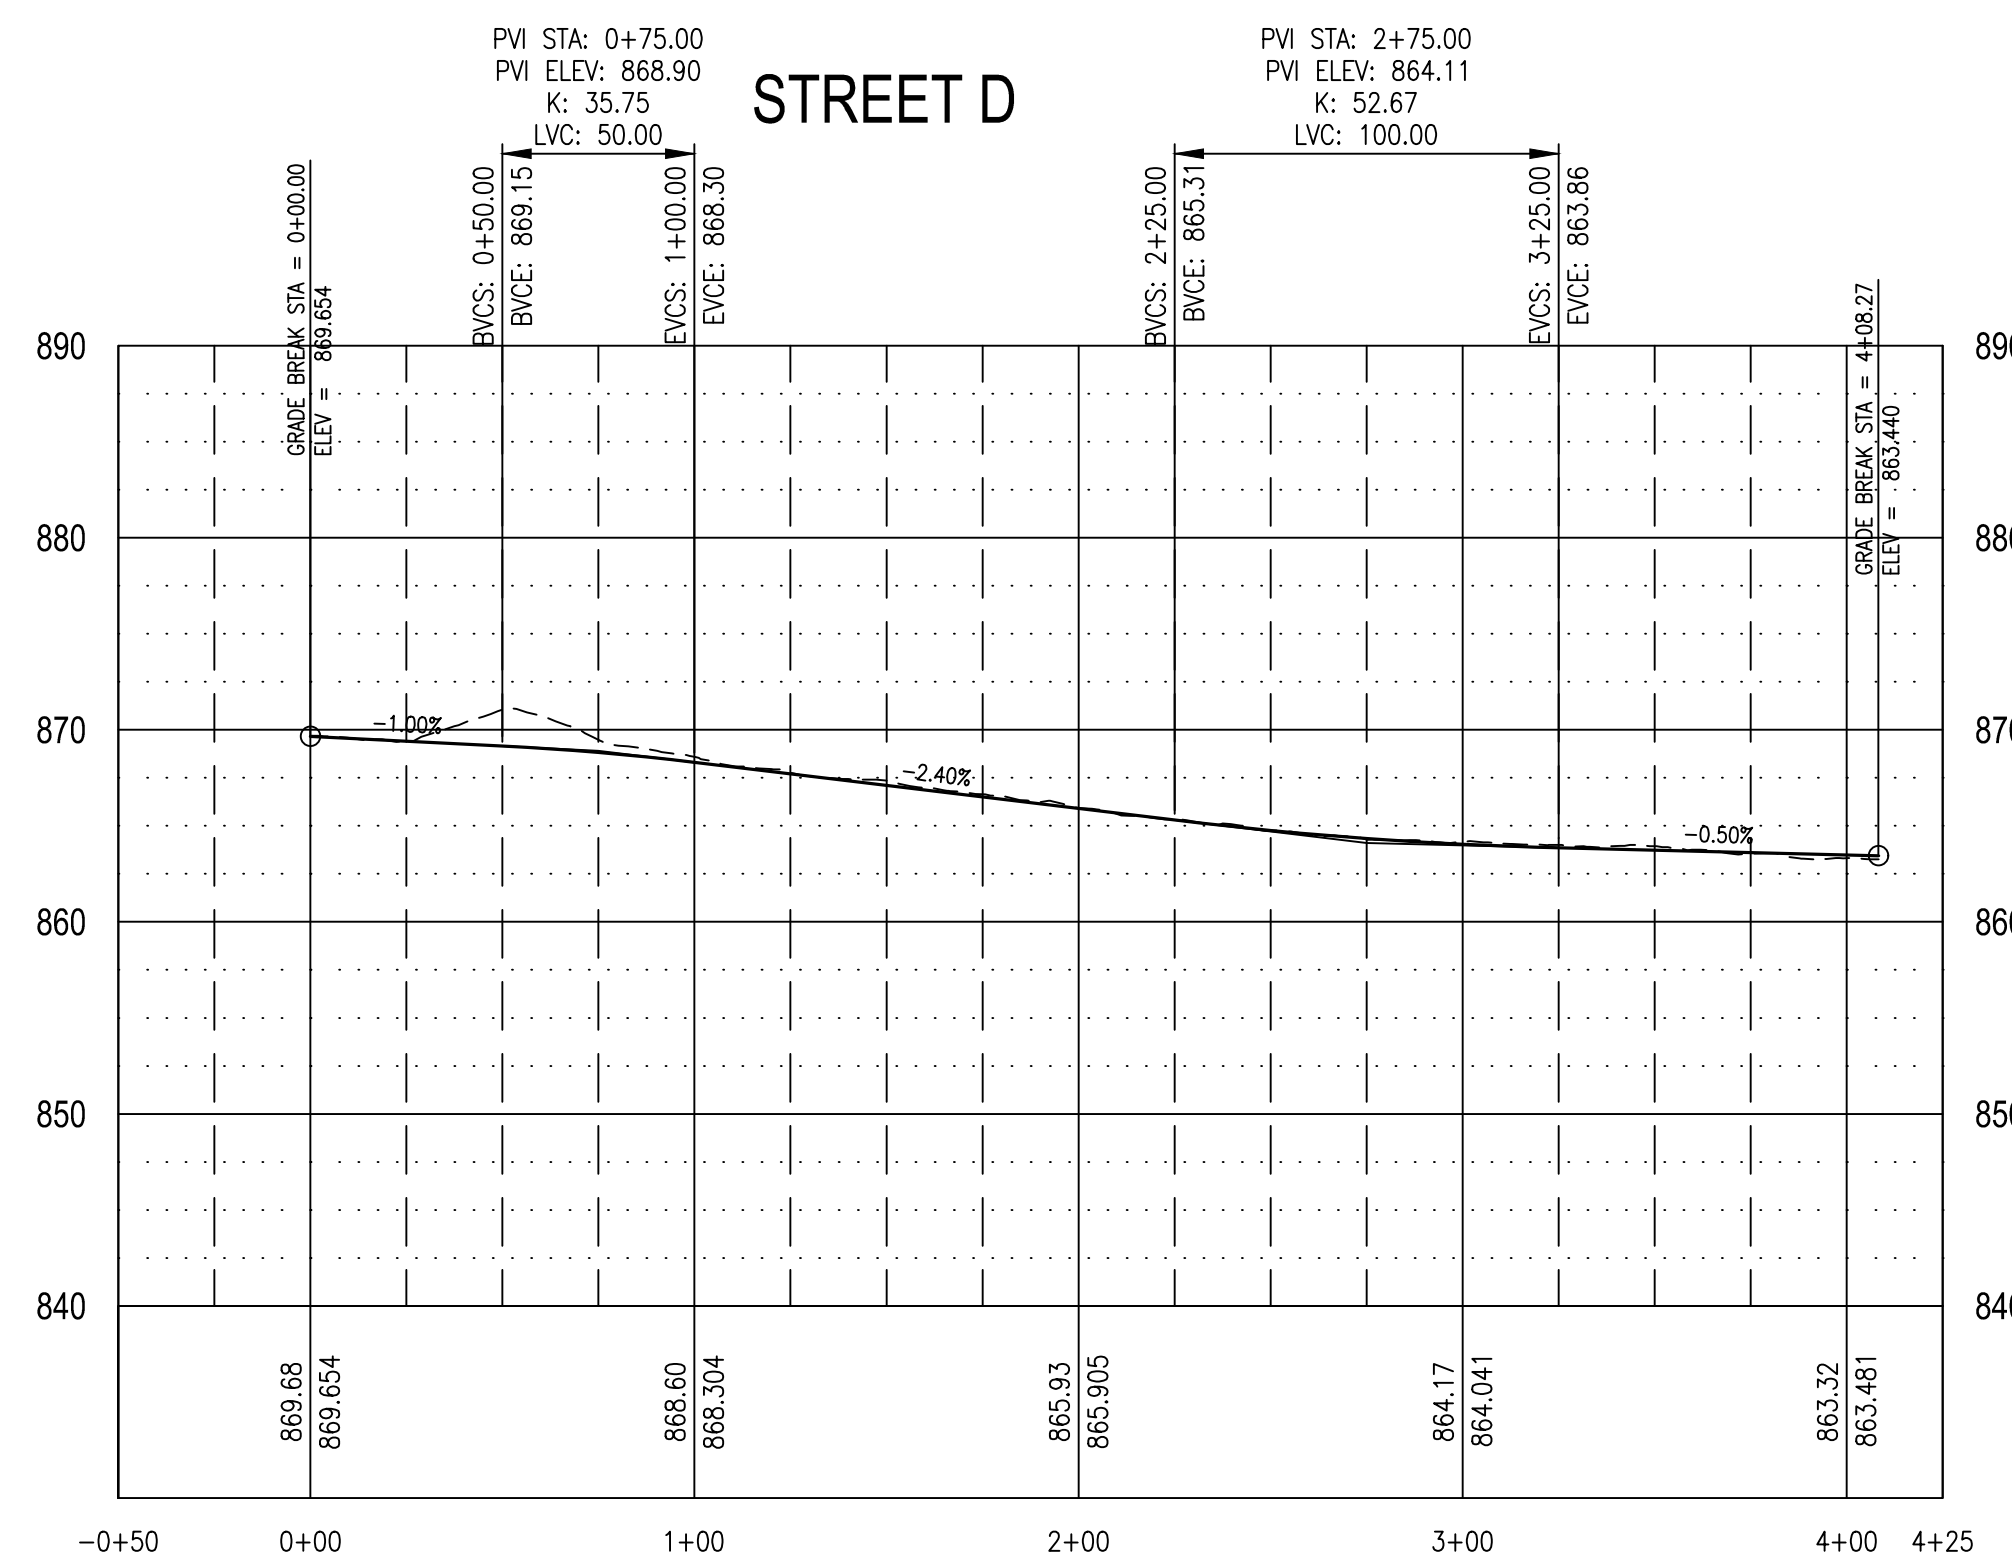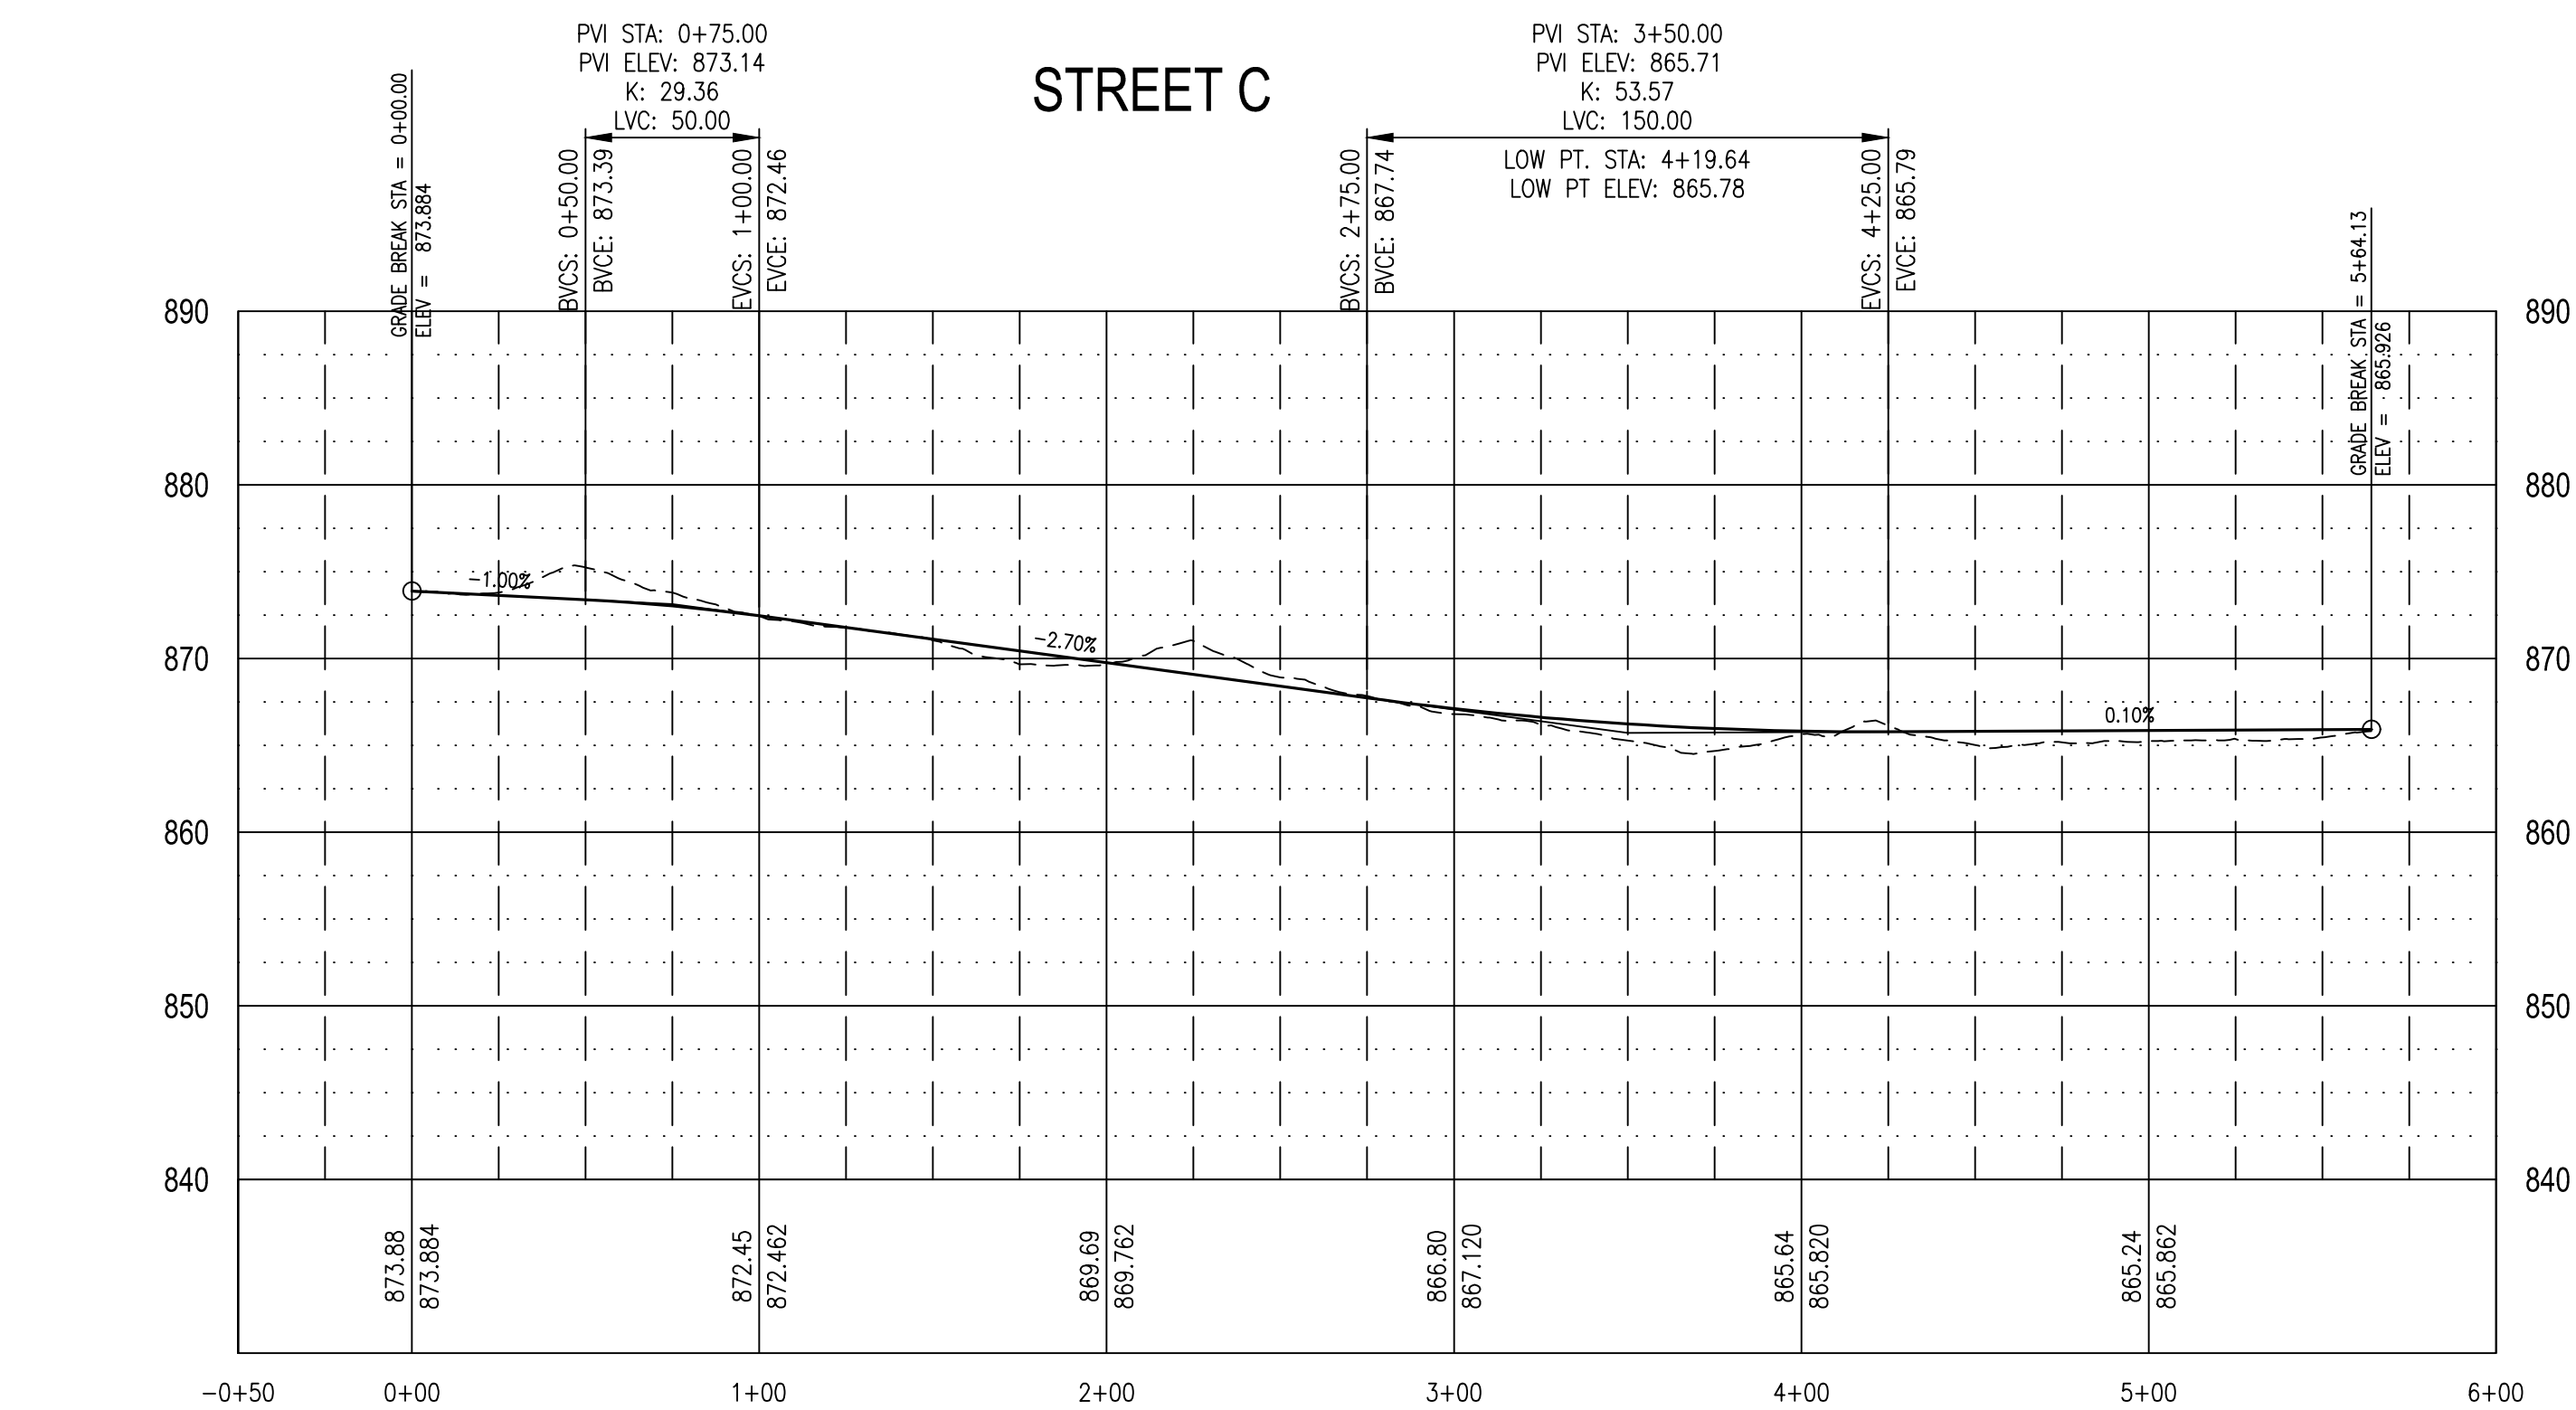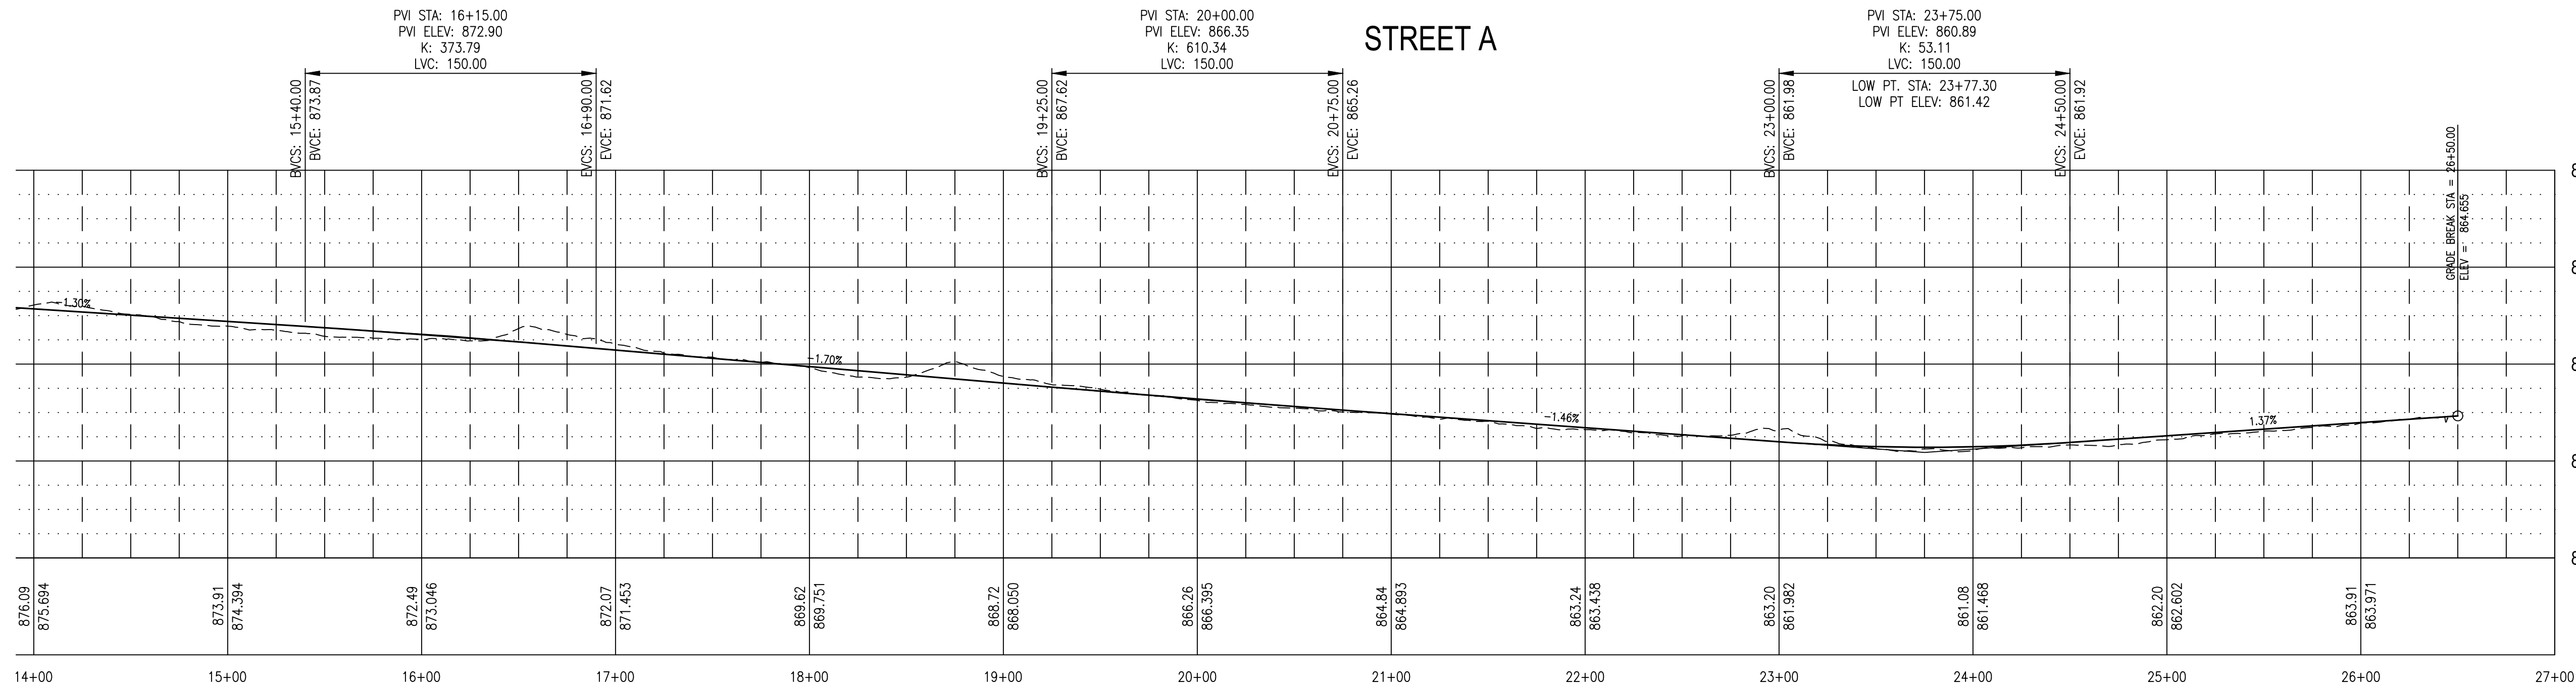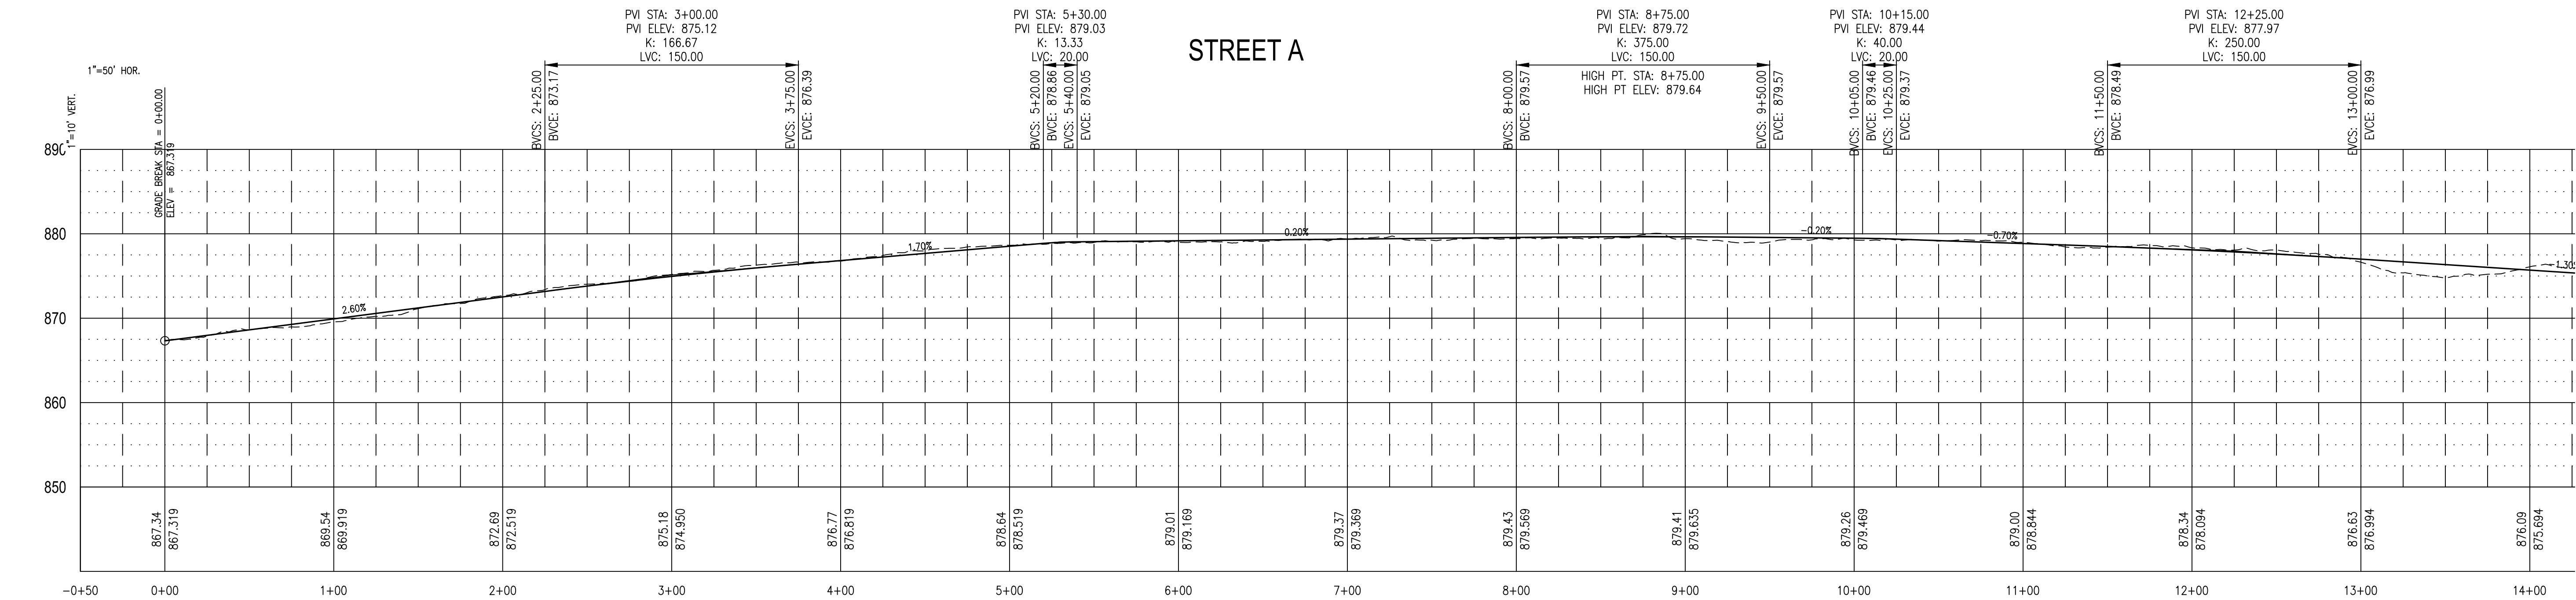

STATE OF MISSOURI
MIKE KEHOE,
GOVERNOR

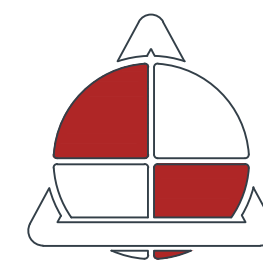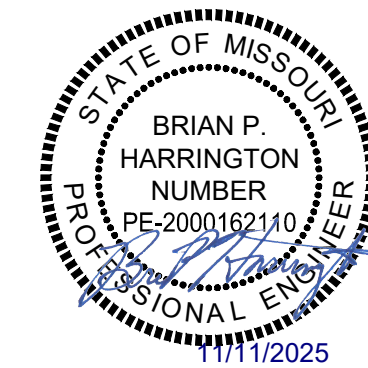

ALLSTATE
CONSULTANTS

allstateconsultants.net

3312 LEMONE INDUSTRIAL BLVD.
COLUMBIA, MO 65201
(573) 875-8799

P.O. BOX 156, 30601 HIGHWAY 5
MARCELINE, MO 64658
(660) 376-2941

410 SE THIRD ST., SUITE 103C
LEE'S SUMMIT, MO 64063
(816) 895-2310

MISSOURI STATE CERTIFICATE
OF AUTHORITY #2007004004
REUSE OF THIS DRAWING IN ANY MANNER IS
STRICTLY PROHIBITED WITHOUT THE WRITTEN
APPROVAL OF
ALLSTATE CONSULTANTS LLC

OFFICE OF ADMINISTRATION
DIVISION OF FACILITIES
MANAGEMENT,
DESIGN AND CONSTRUCTION

MISSOURI
STATE FAIRGROUNDS

NEW CAMPGROUND
CONSTRUCTION PLANS

MISSOURI
STATE FAIRGROUNDS
2503 W 16th STREET
SEDALIA, MO

PROJECT # F2307-01
SITE # 1501
ASSET # 3511501153


REVISION: _____
DATE: _____
REVISION: _____
DATE: _____
REVISION: _____
DATE: _____
ISSUE DATE: 11/11/2025

CAD DWG FILE: 23117.02-SHEETSBASE
DRAWN BY: DEP
CHECKED BY: CWS
DESIGNED BY: BPH


SHEET TITLE:
STREET PROFILES

SHEET NUMBER:
C-103
6 OF 43
11/11/2025


STREET B

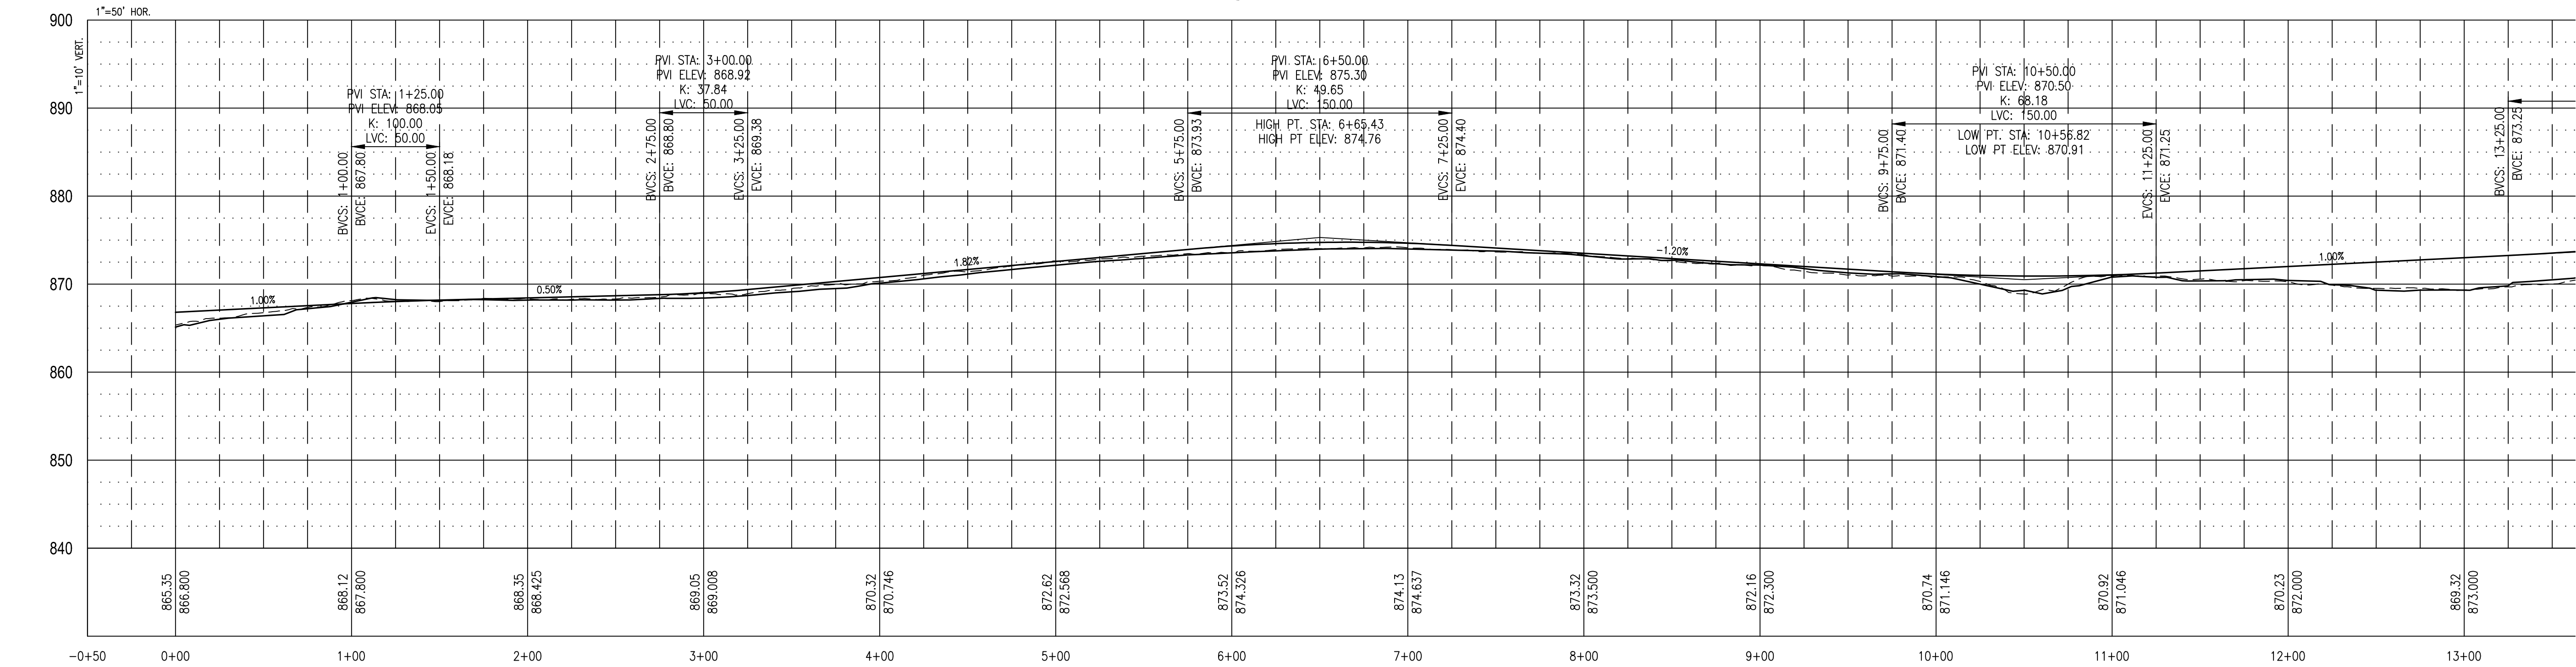

STREET B

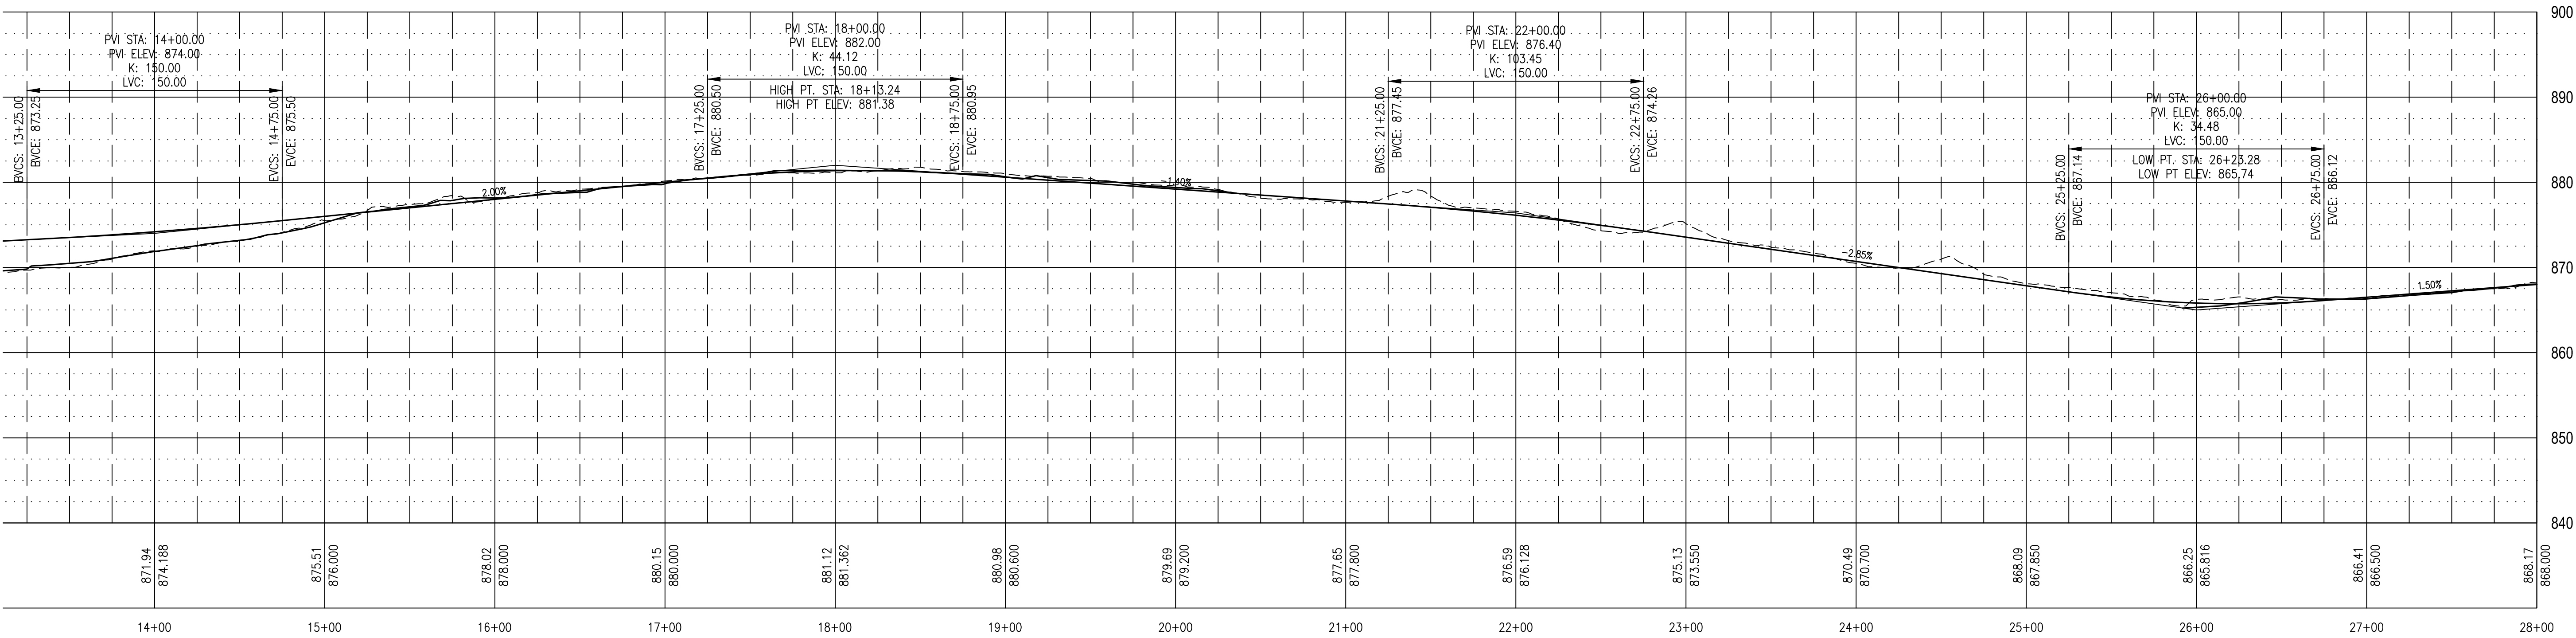

STATE OF MISSOURI
MIKE KEHOE,
GOVERNOR

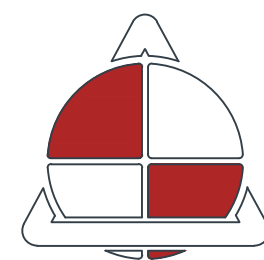

ALLSTATE
CONSULTANTS
allstateconsultants.net

3312 LEMONE INDUSTRIAL BLVD.
COLUMBIA, MO 65201
(573) 875-8799

P.O. BOX 156, 30601 HIGHWAY 5
MARCELINE, MO 64658
(660) 376-2941

410 SE THIRD ST., SUITE 103C
LEE'S SUMMIT, MO 64063
(816) 895-2310

MISSOURI STATE CERTIFICATE
OF AUTHORITY #2007004004
REUSE OF THIS DRAWING IN ANY MANNER IS
STRICTLY PROHIBITED WITHOUT THE WRITTEN
APPROVAL OF
ALLSTATE CONSULTANTS LLC

OFFICE OF ADMINISTRATION
DIVISION OF FACILITIES
MANAGEMENT,
DESIGN AND CONSTRUCTION

MISSOURI
STATE FAIRGROUNDS

NEW CAMPGROUND
CONSTRUCTION PLANS

MISSOURI
STATE FAIRGROUNDS
2503 W 16th STREET
SEDALIA, MO

PROJECT # F2307-01
SITE # 1501
ASSET # 3511501153

REVISION: _____
DATE: _____
REVISION: _____
DATE: _____
REVISION: _____
DATE: _____
ISSUE DATE: 11/11/2025

CAD DWG FILE: 231117.02-SHEETSBASE
DRAWN BY: DEP
CHECKED BY: CWS
DESIGNED BY: BPH


SHEET TITLE:
STREET PROFILES

SHEET NUMBER:


C-104

7 OF 43
11/11/2025


STREET E

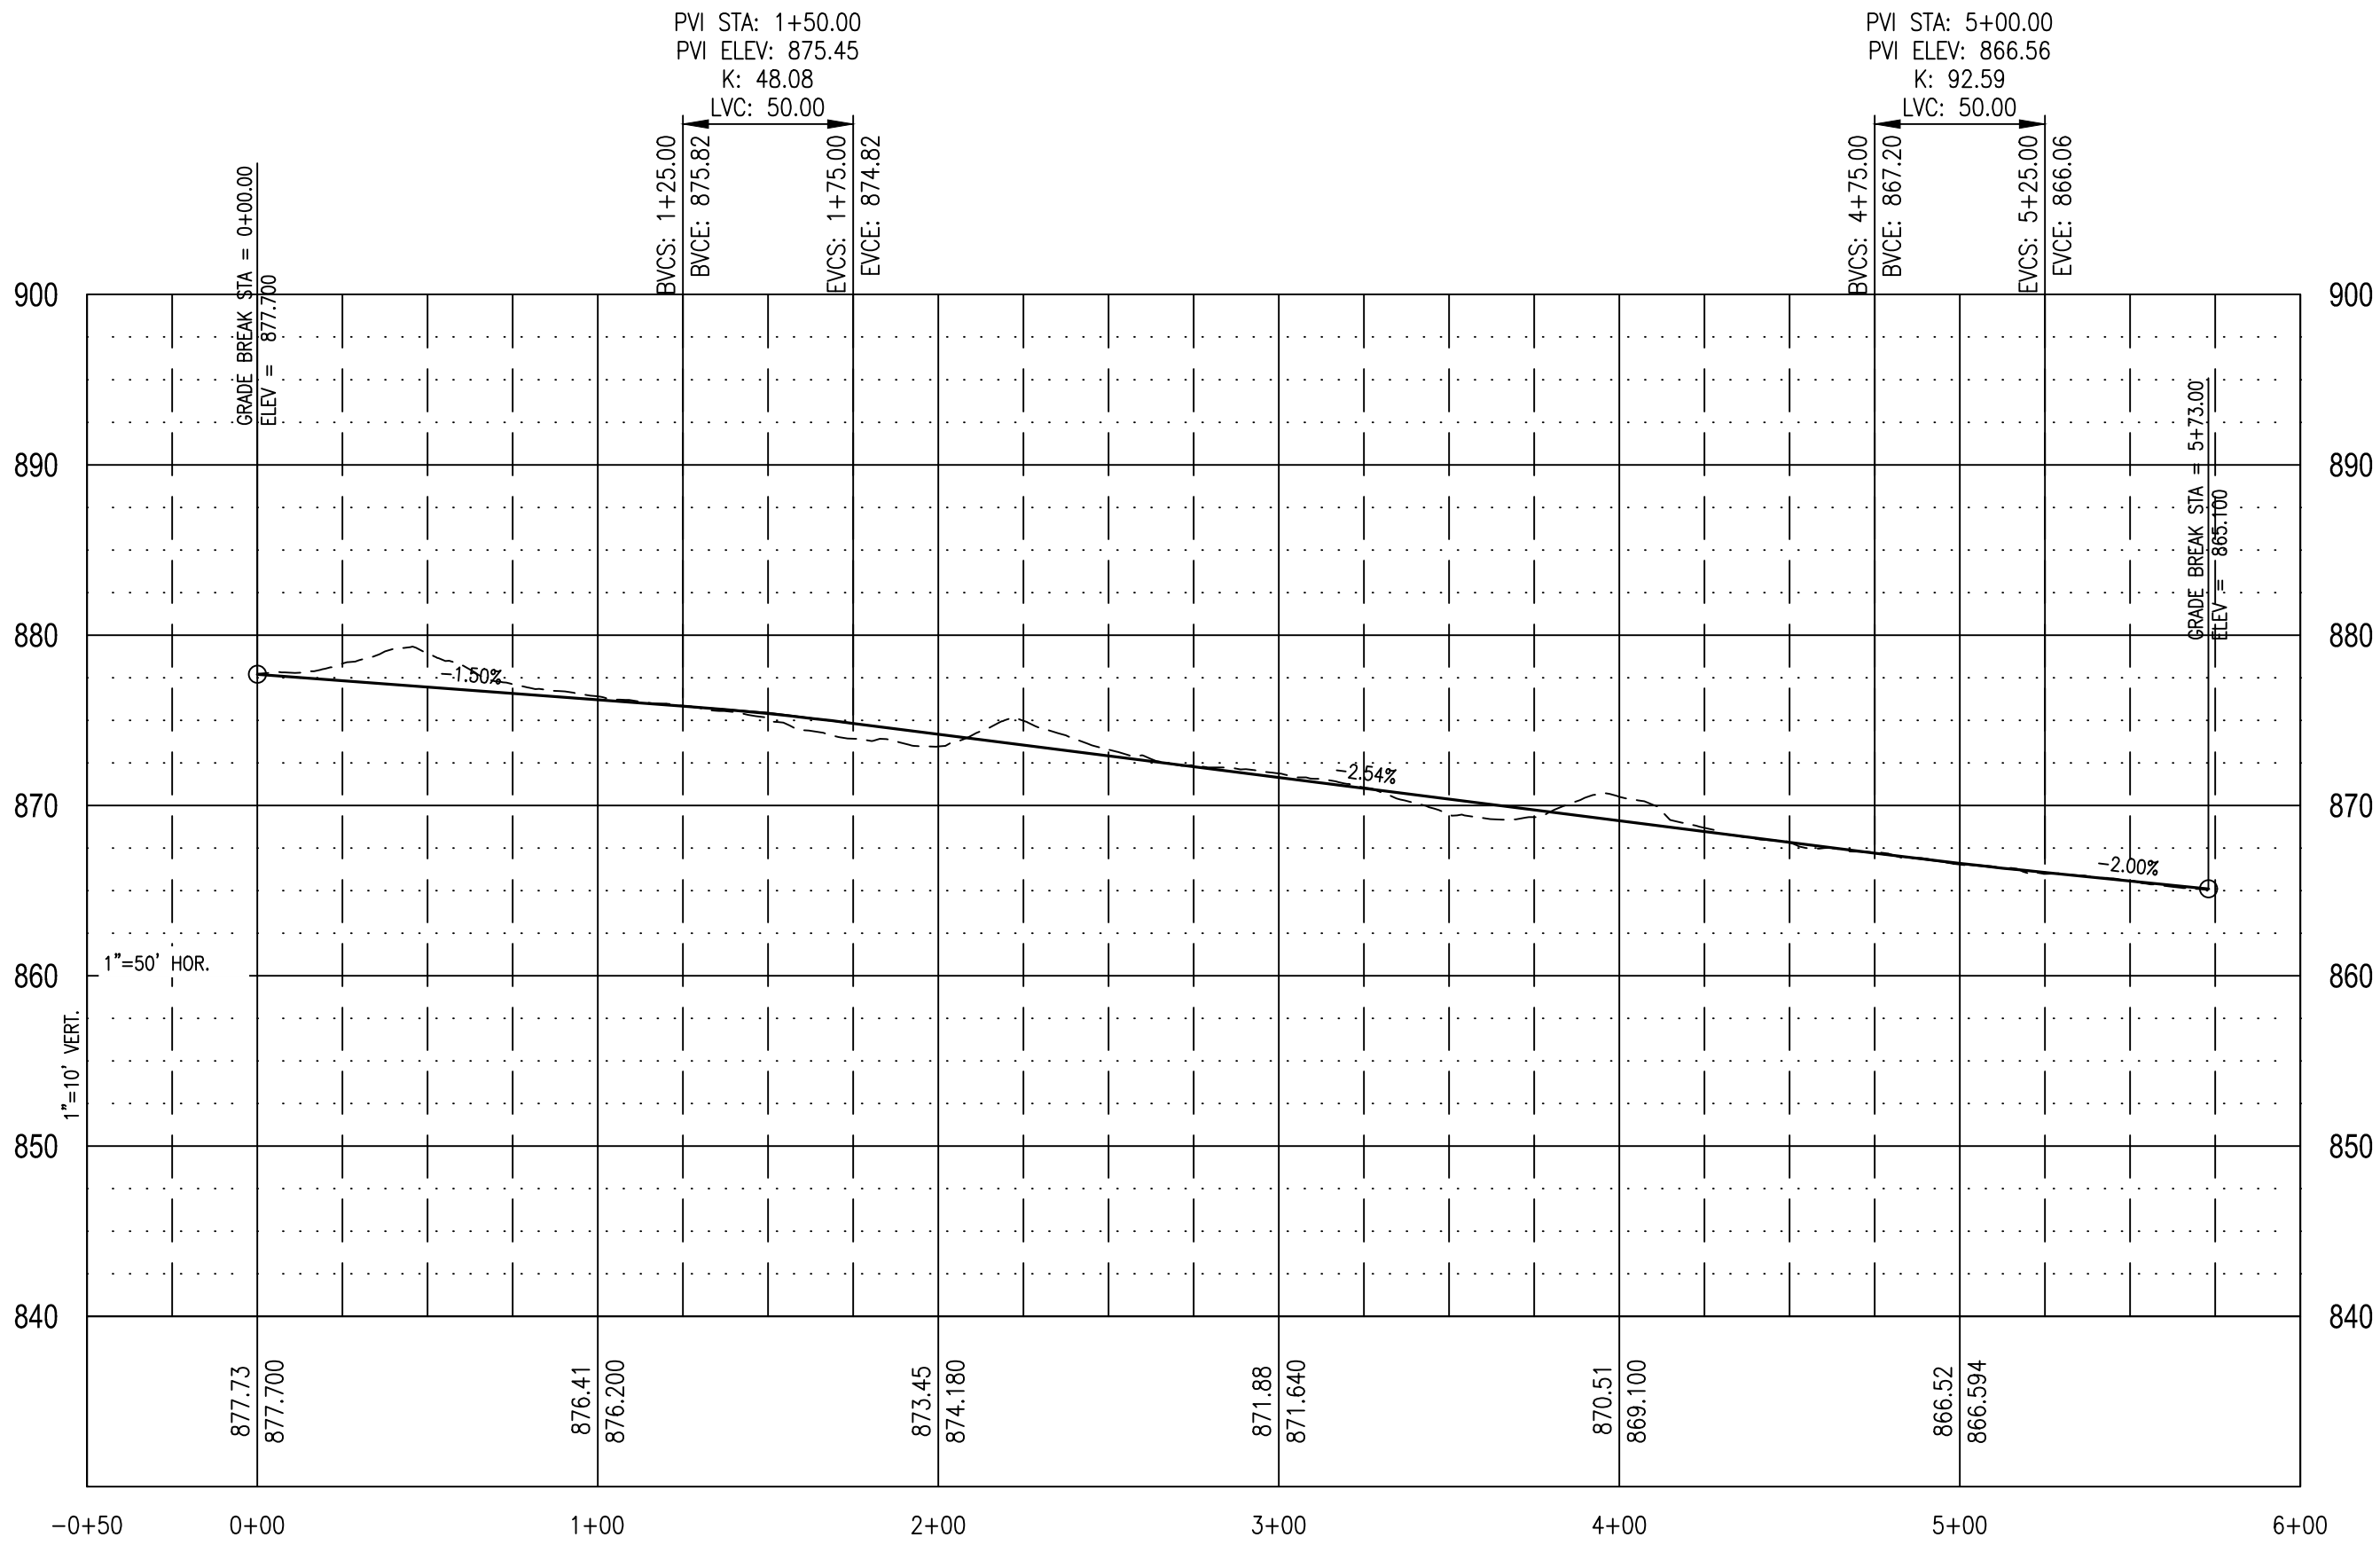


STREET F

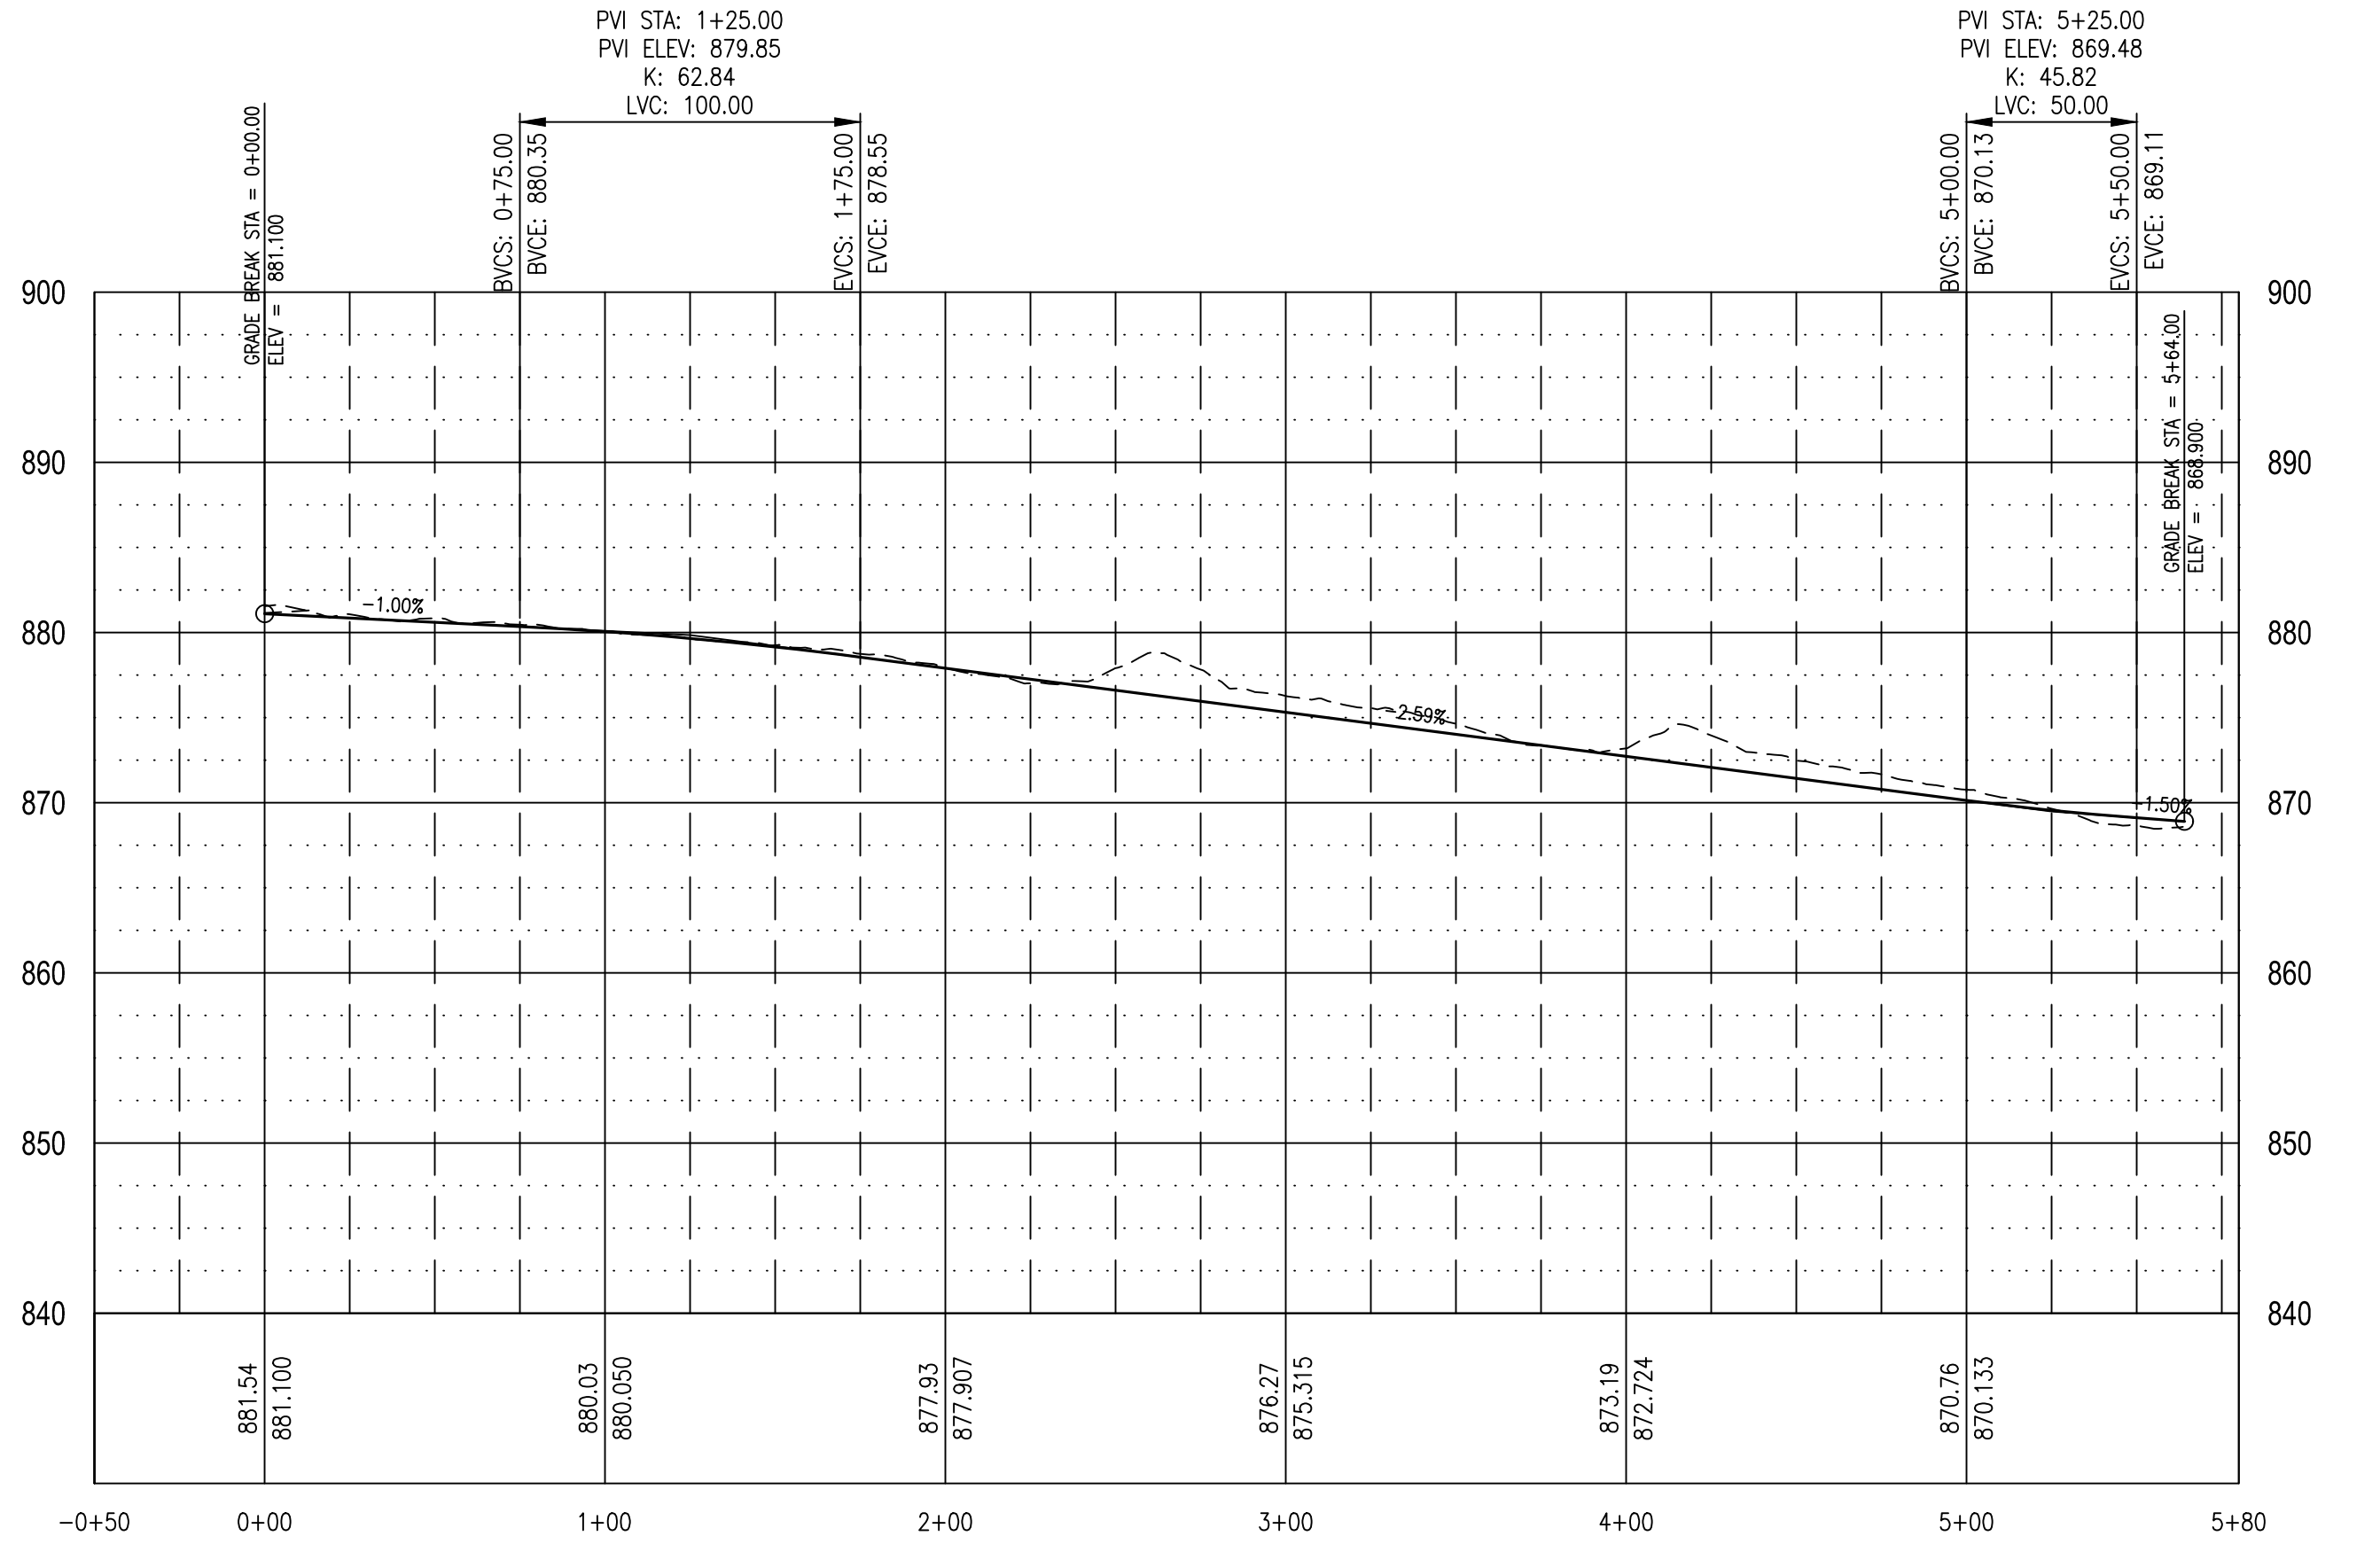


STREET G

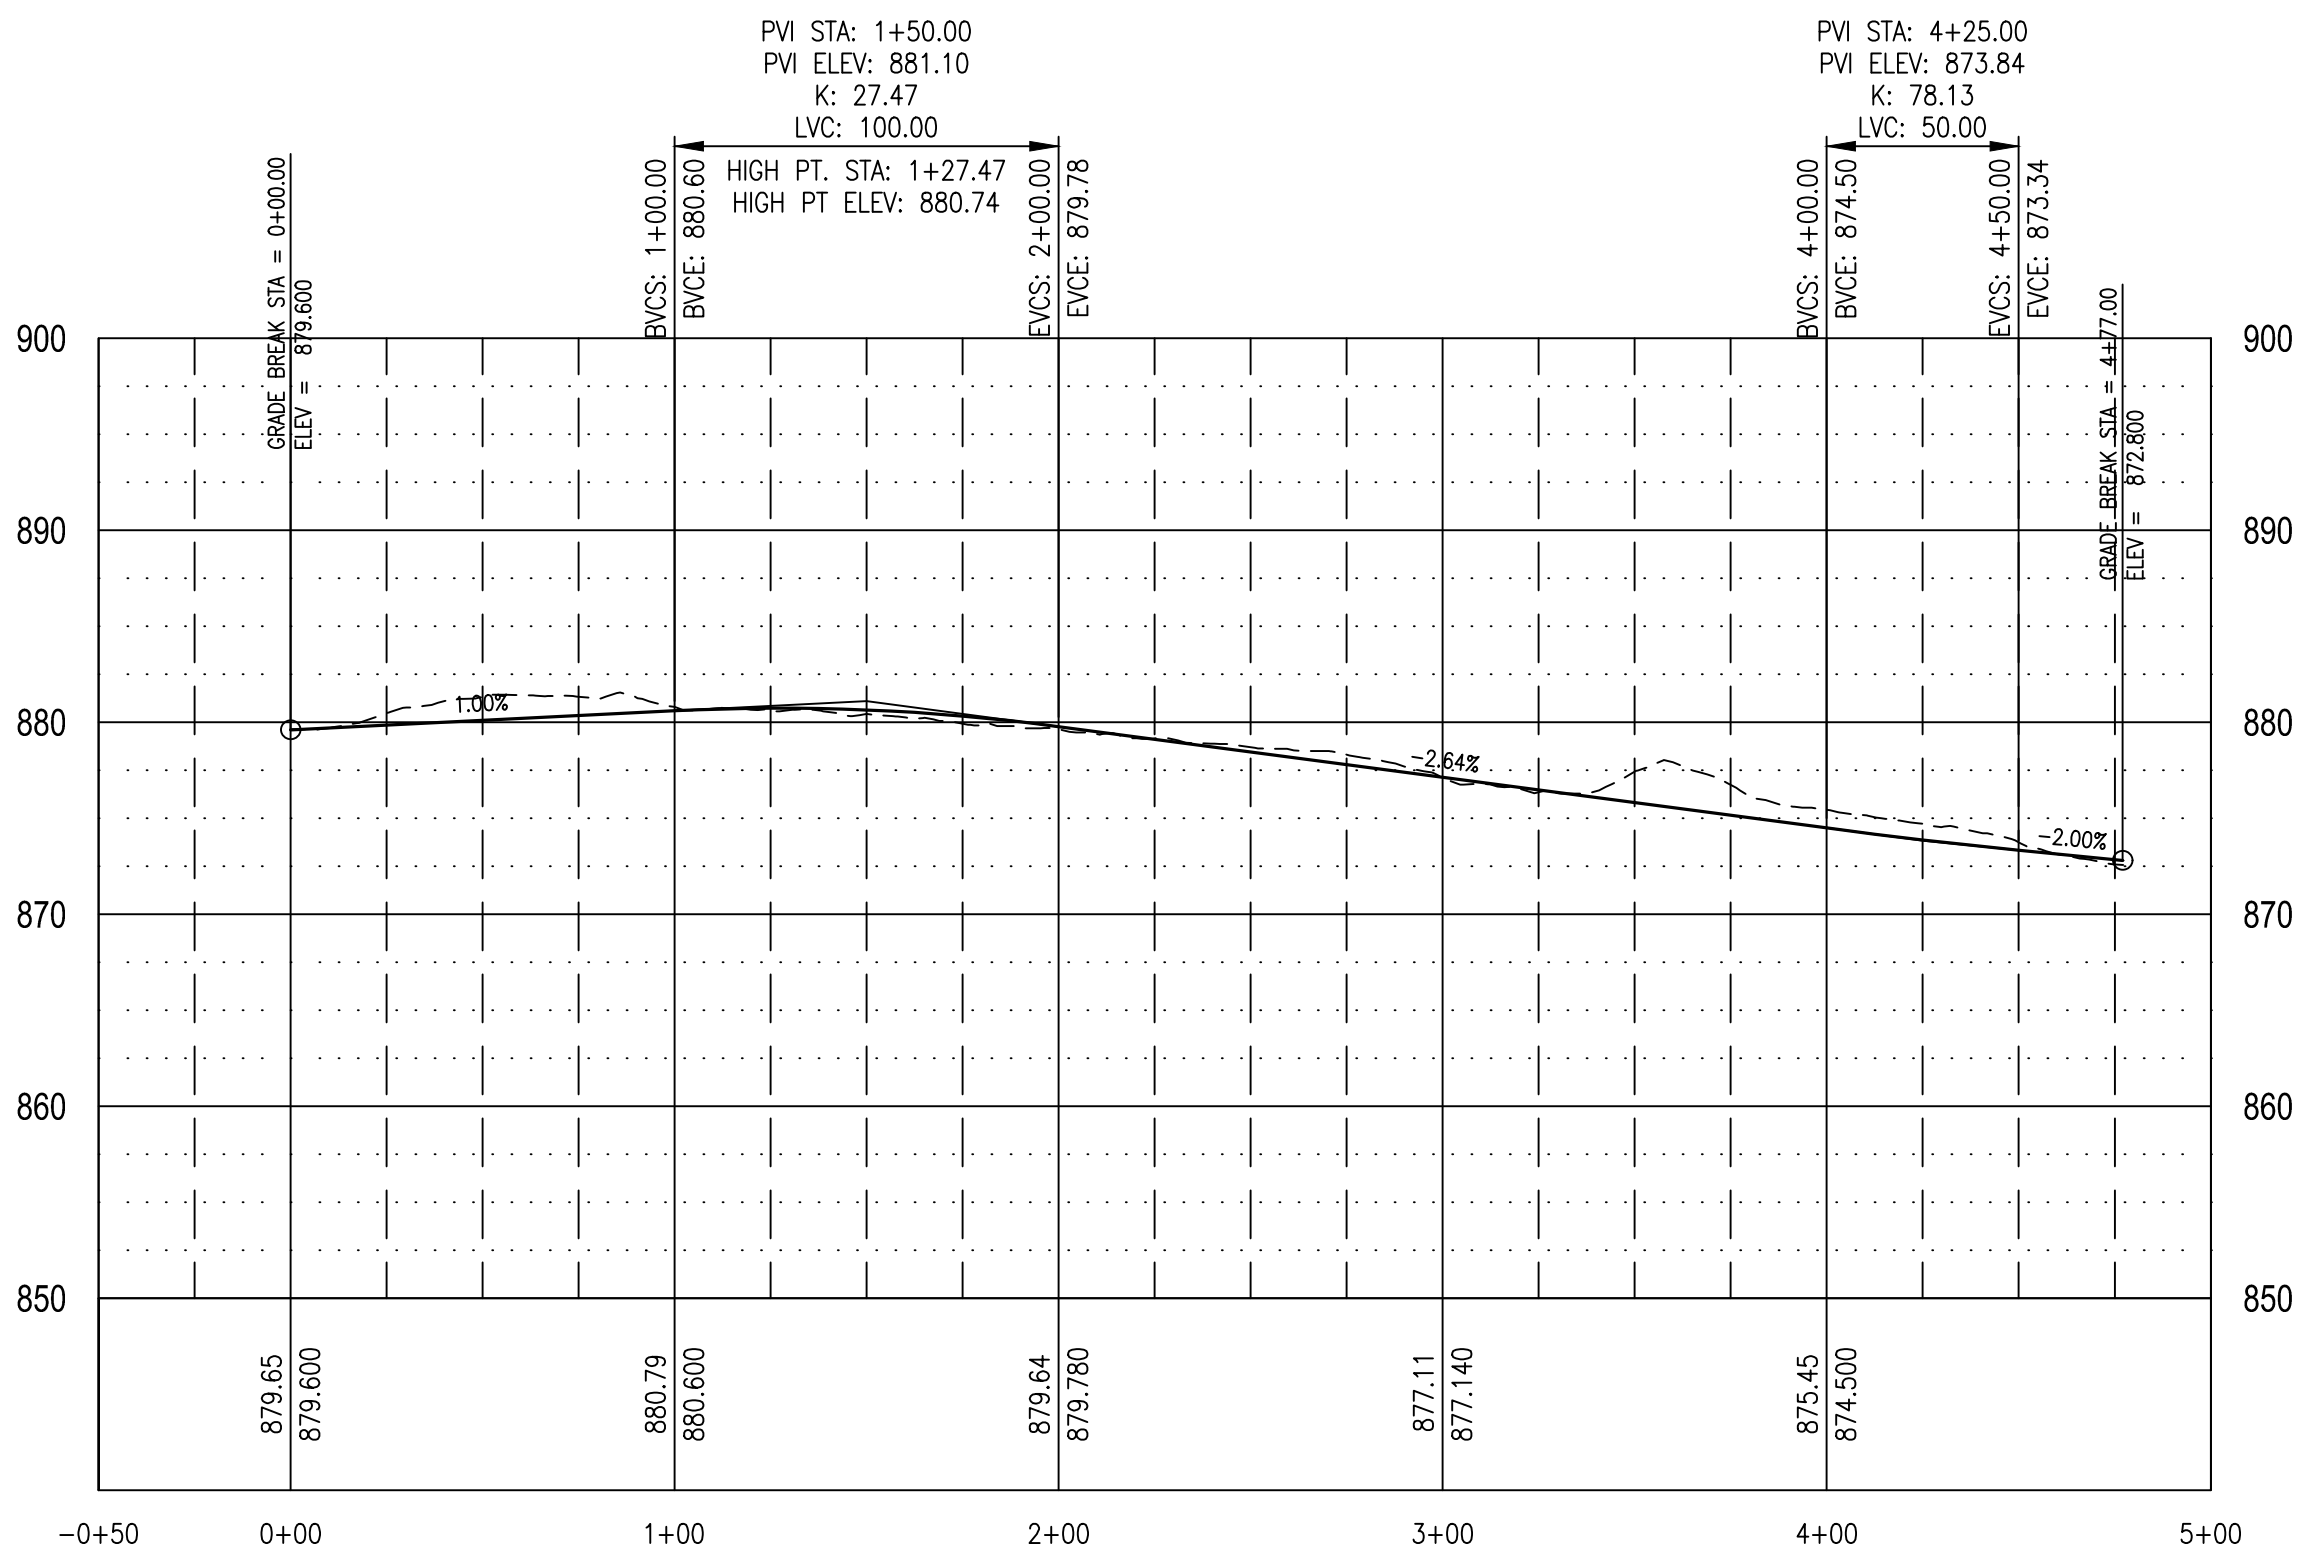

STREET H

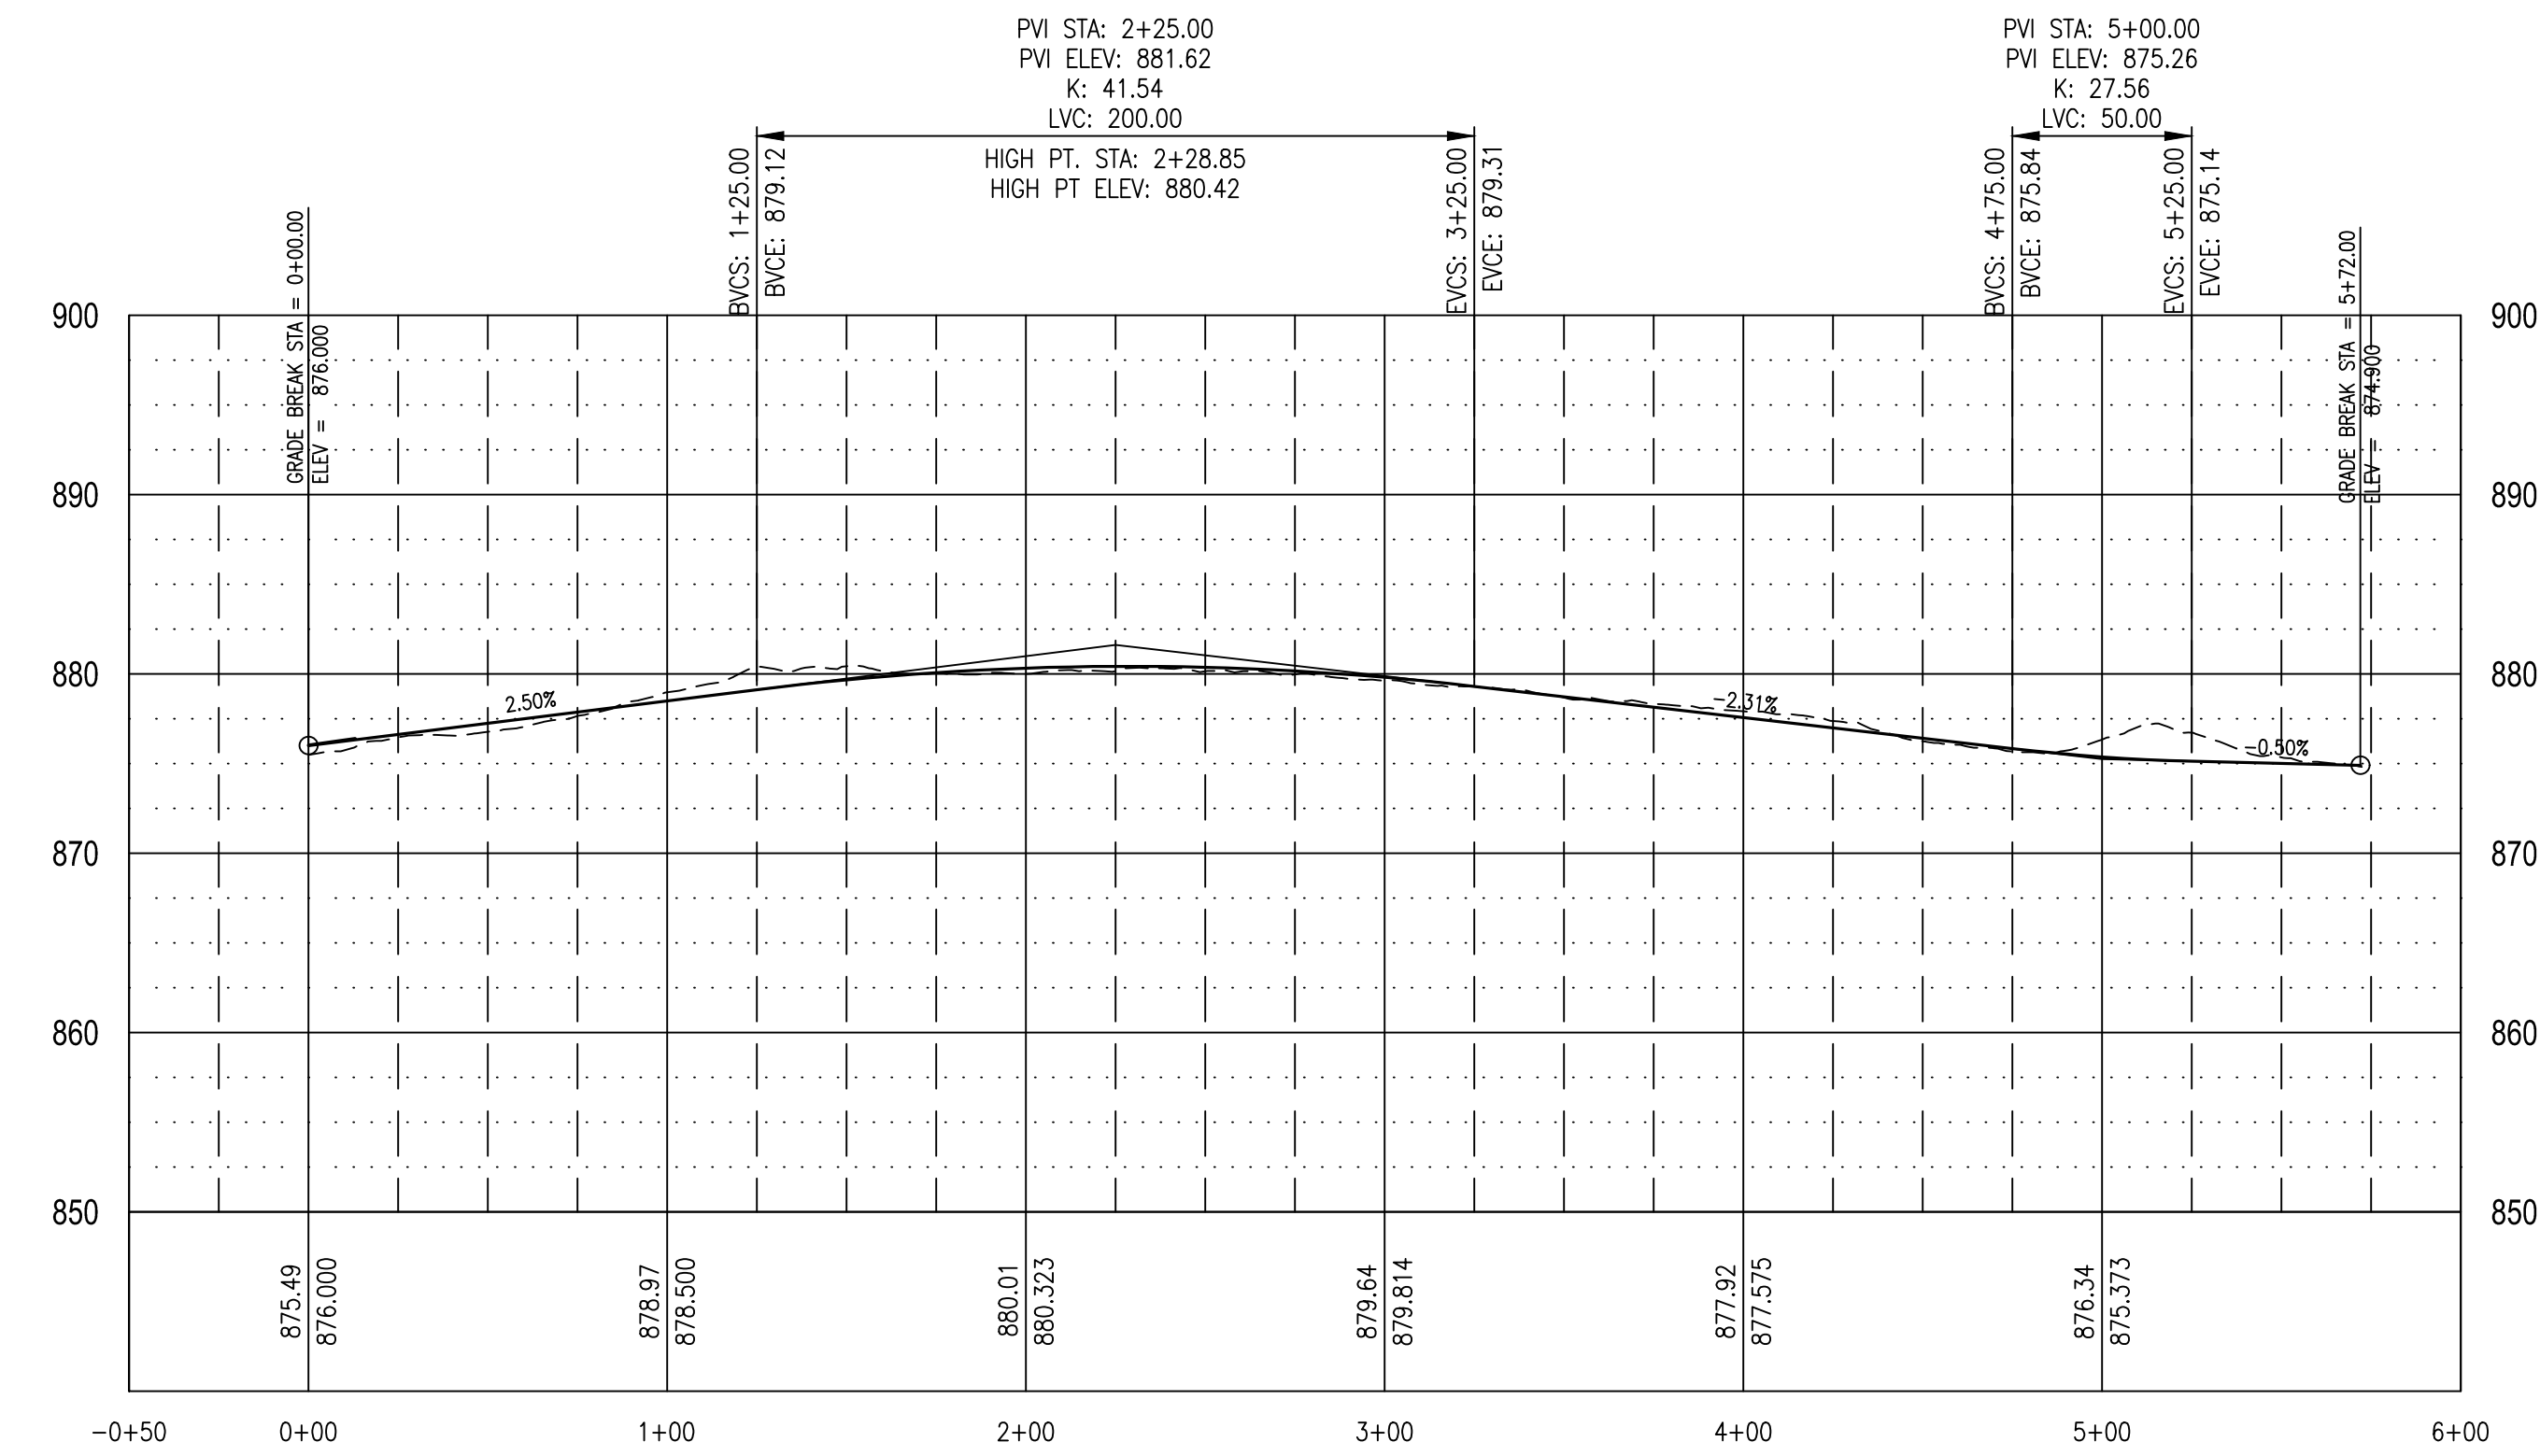

STATE OF MISSOURI
MIKE KEHOE,
GOVERNOR

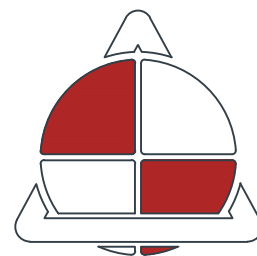

ALLSTATE
CONSULTANTS

allstateconsultants.net

3312 LEMONE INDUSTRIAL BLVD.
COLUMBIA, MO 65201
(573) 875-8799

P.O. BOX 156, 30601 HIGHWAY 5
MARCELINE, MO 64658
(660) 376-2941

410 SE THIRD ST., SUITE 103C
LEE'S SUMMIT, MO 64063
(816) 895-2310

MISSOURI STATE CERTIFICATE
OF AUTHORITY #2007004004
REUSE OF THIS DRAWING IN ANY MANNER IS
STRICTLY PROHIBITED WITHOUT THE WRITTEN
APPROVAL OF
ALLSTATE CONSULTANTS LLC

OFFICE OF ADMINISTRATION
DIVISION OF FACILITIES
MANAGEMENT,
DESIGN AND CONSTRUCTION

MISSOURI
STATE FAIRGROUNDS

NEW CAMPGROUND
CONSTRUCTION PLANS

MISSOURI
STATE FAIRGROUNDS
2503 W 16th STREET
SEDALIA, MO

PROJECT # F2307-01
SITE # 1501
ASSET # 3511501153

REVISION: _____
DATE: _____
REVISION: _____
DATE: _____
REVISION: _____
DATE: _____

ISSUE DATE: 11/11/2025

CAD DWG FILE: 23117.02-SHEETSBASE
DRAWN BY: DEP
CHECKED BY: CWS
DESIGNED BY: BPH


SHEET TITLE:
STREET PROFILES

SHEET NUMBER:


C-105

8 OF 43
11/11/2025


STREET I

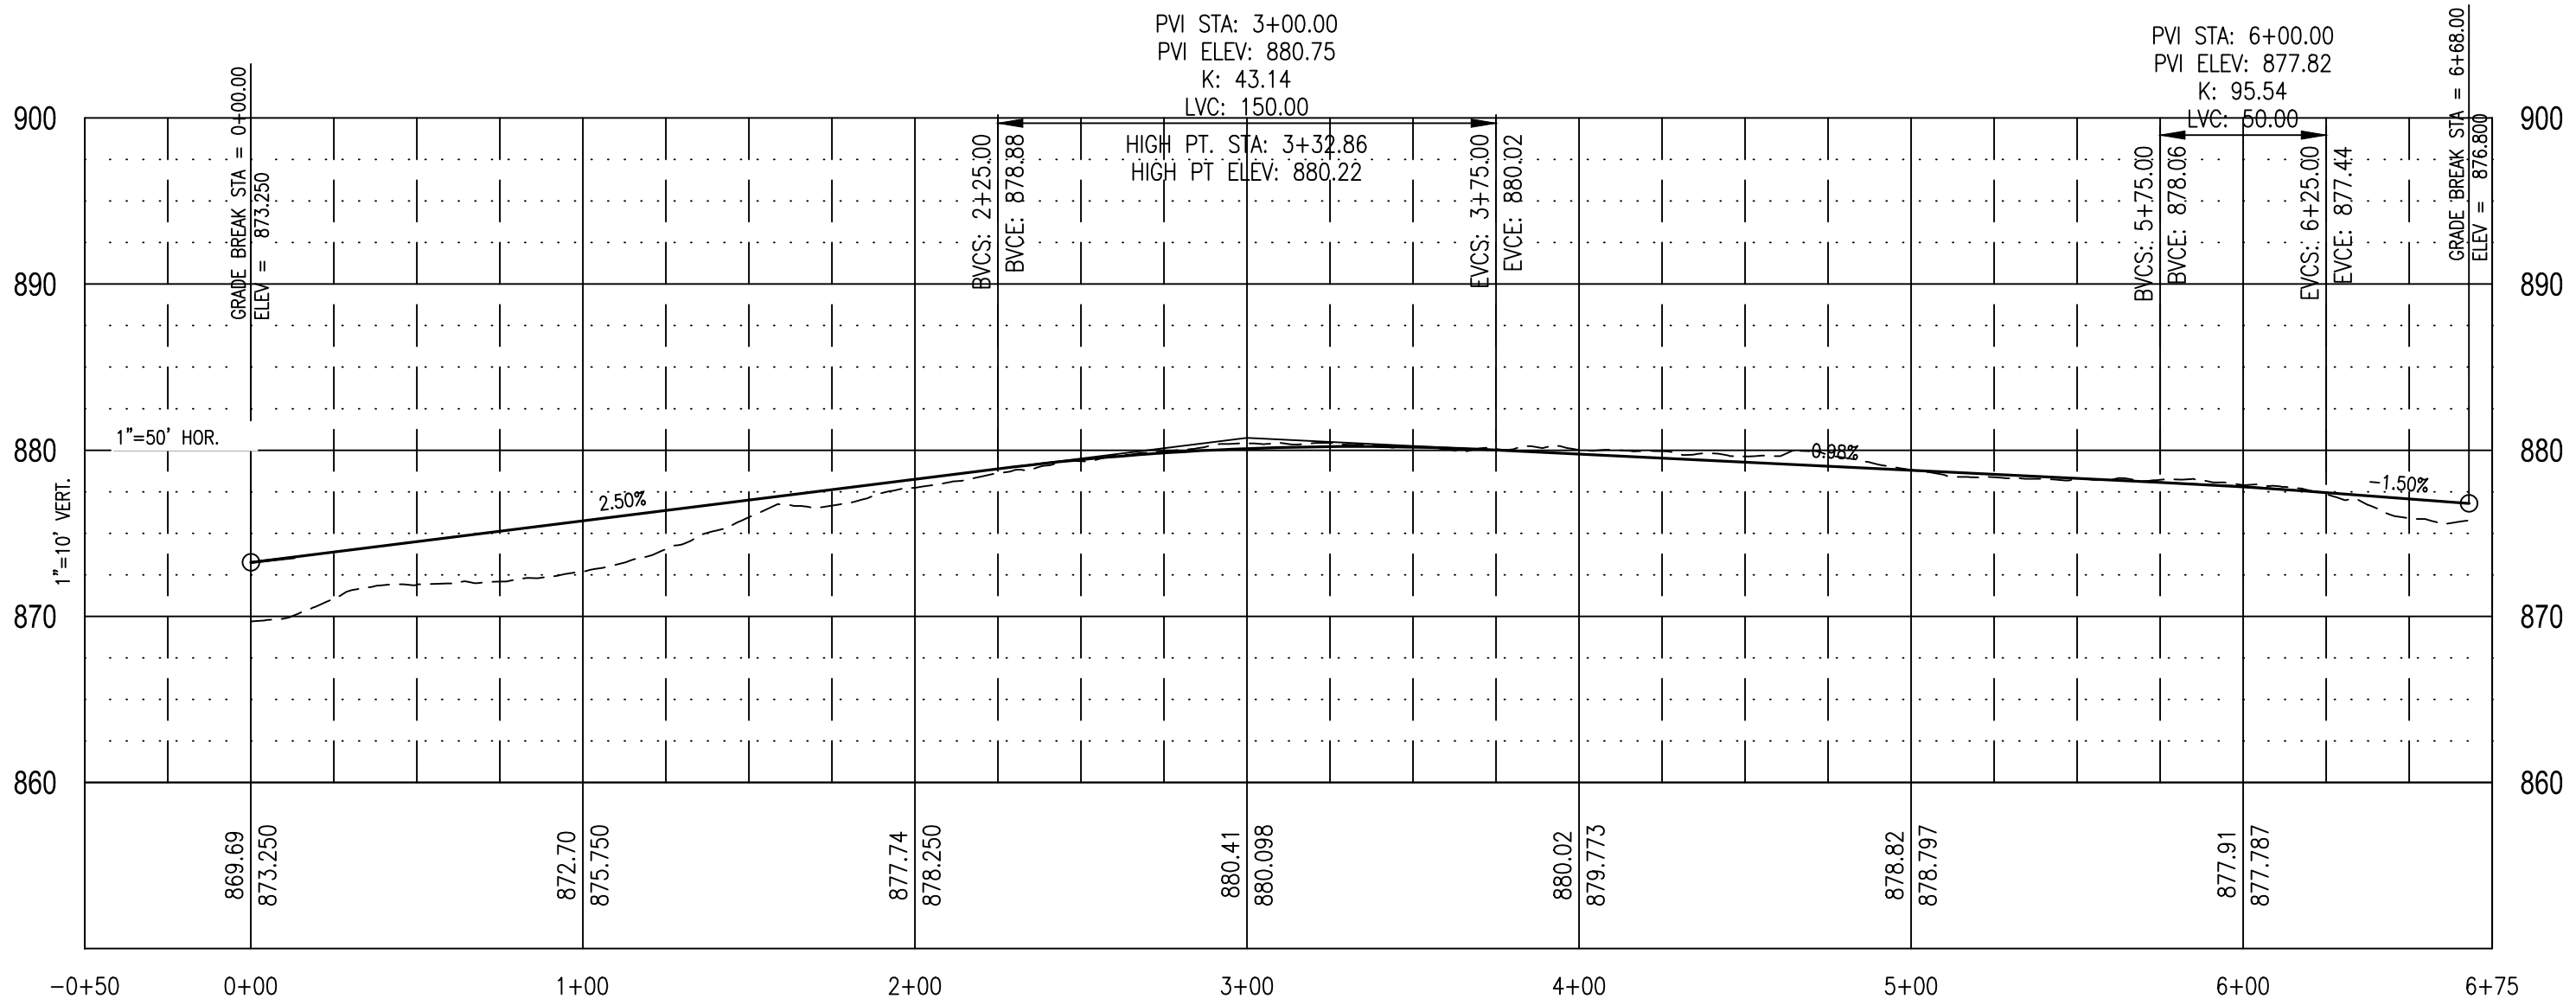


STREET K

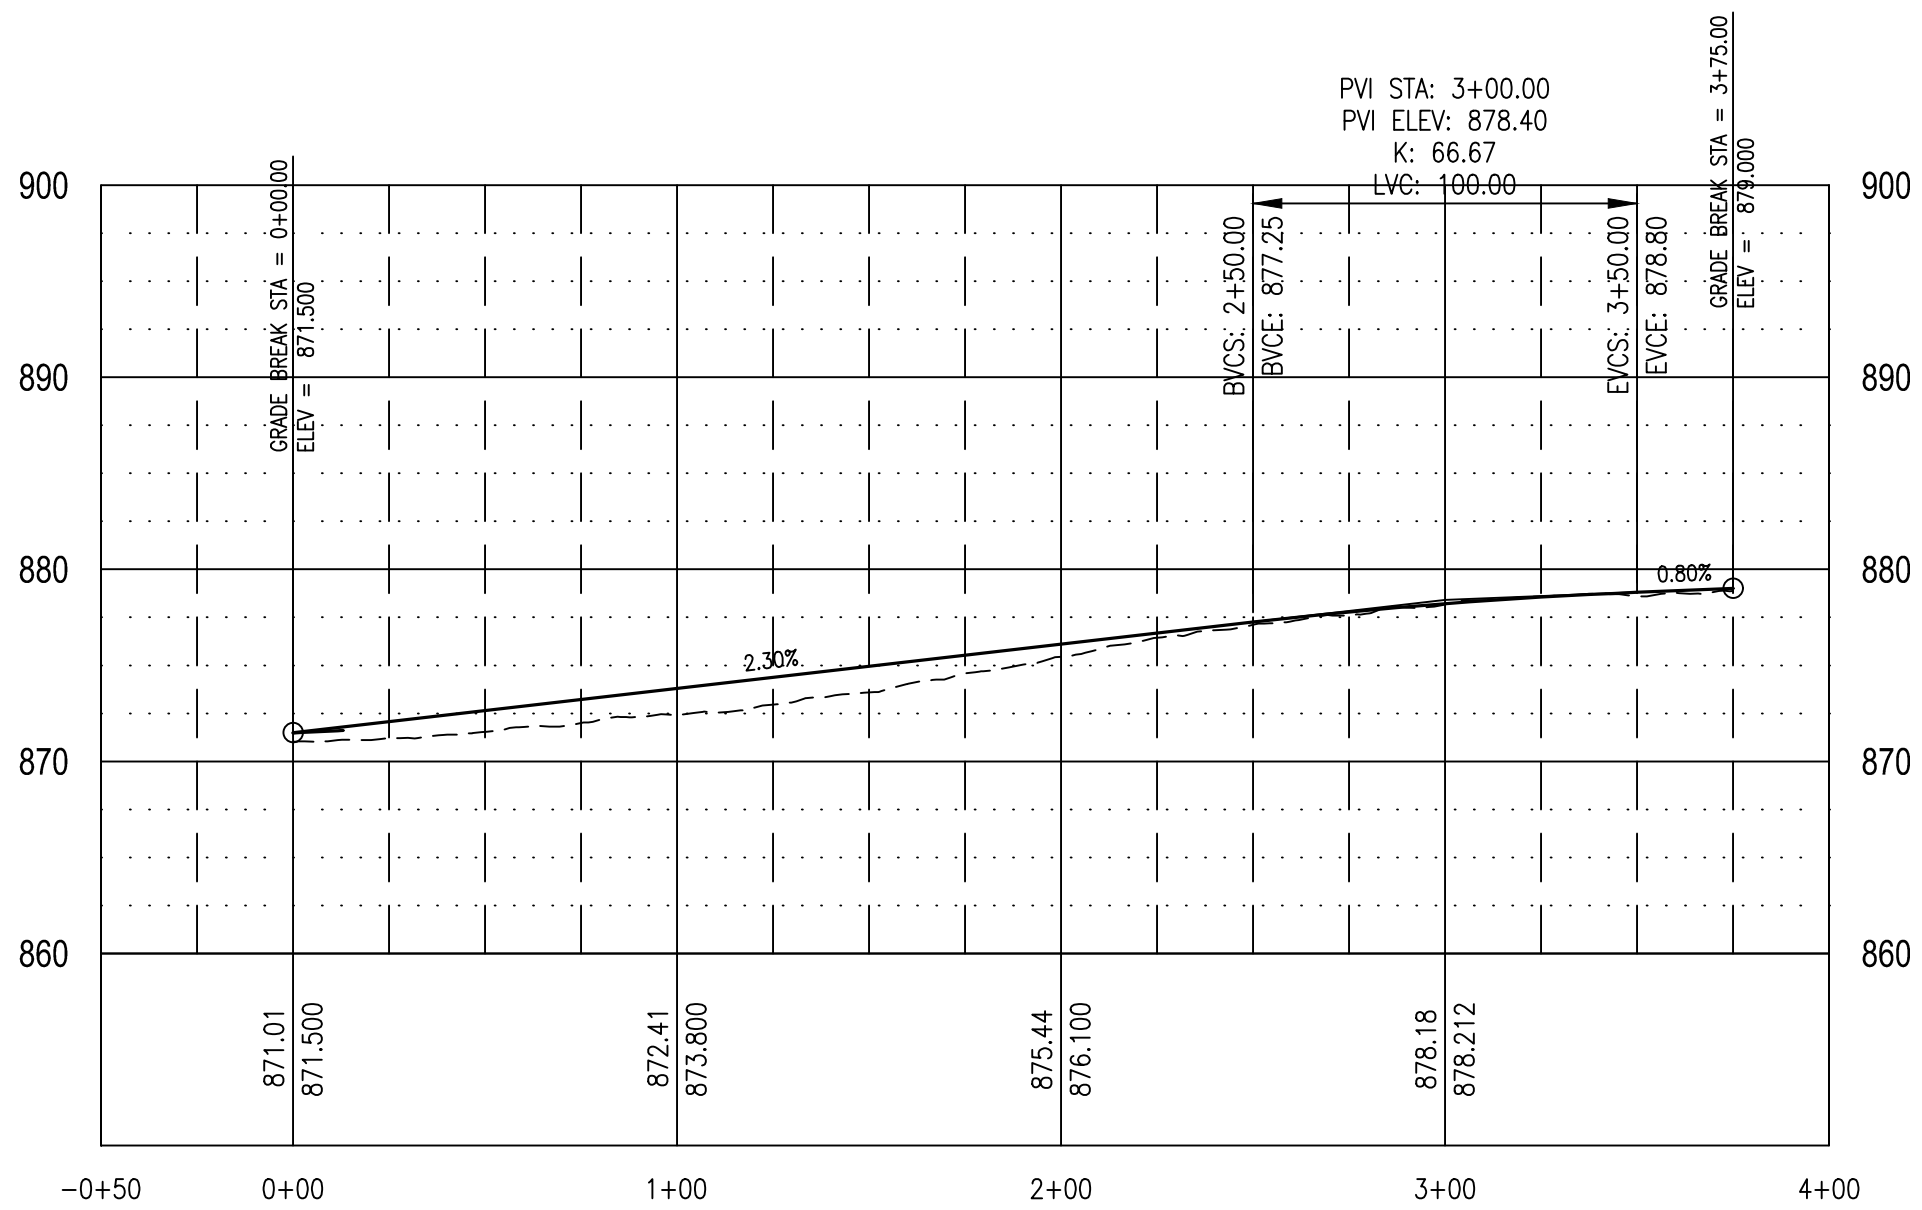


STREET I

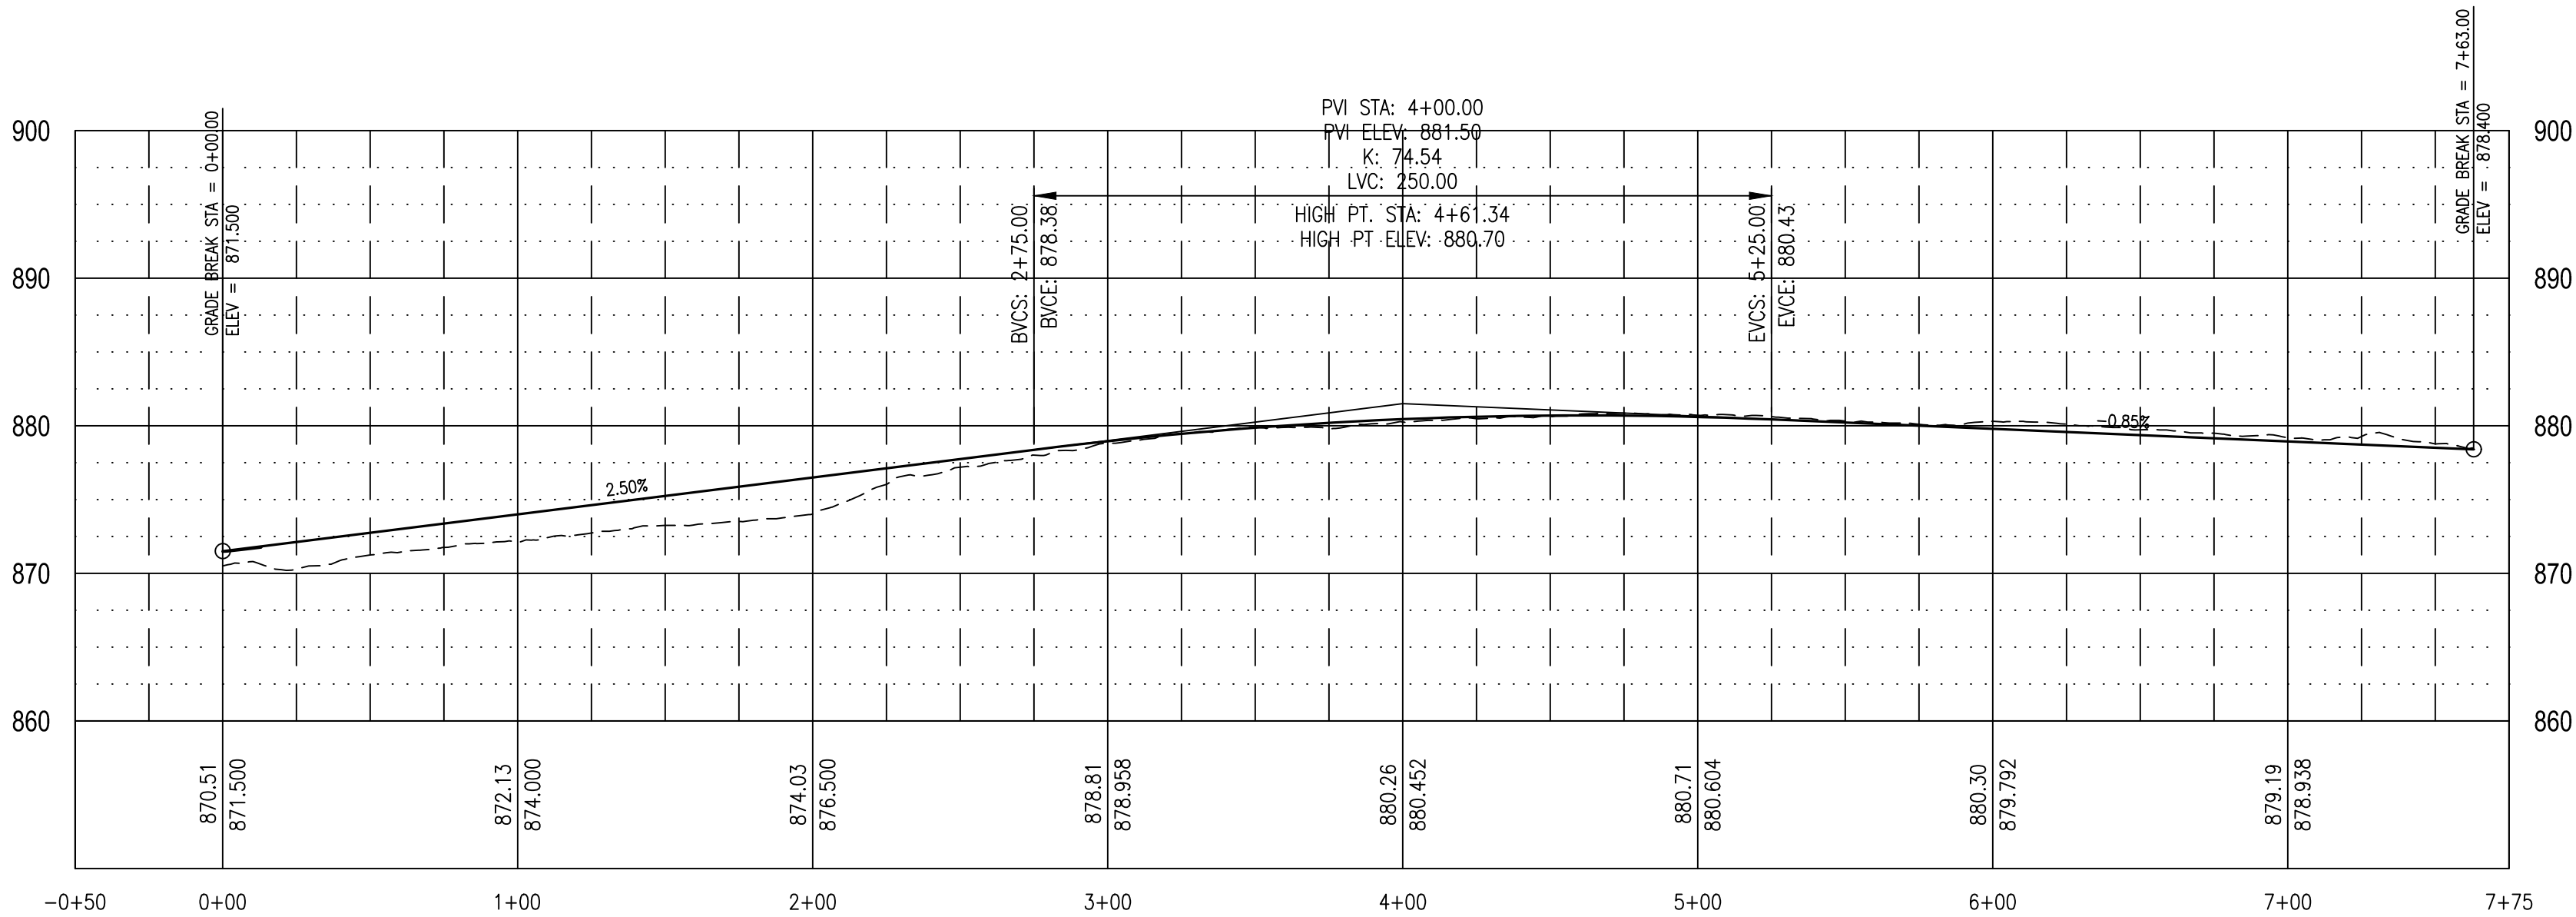


STREET L

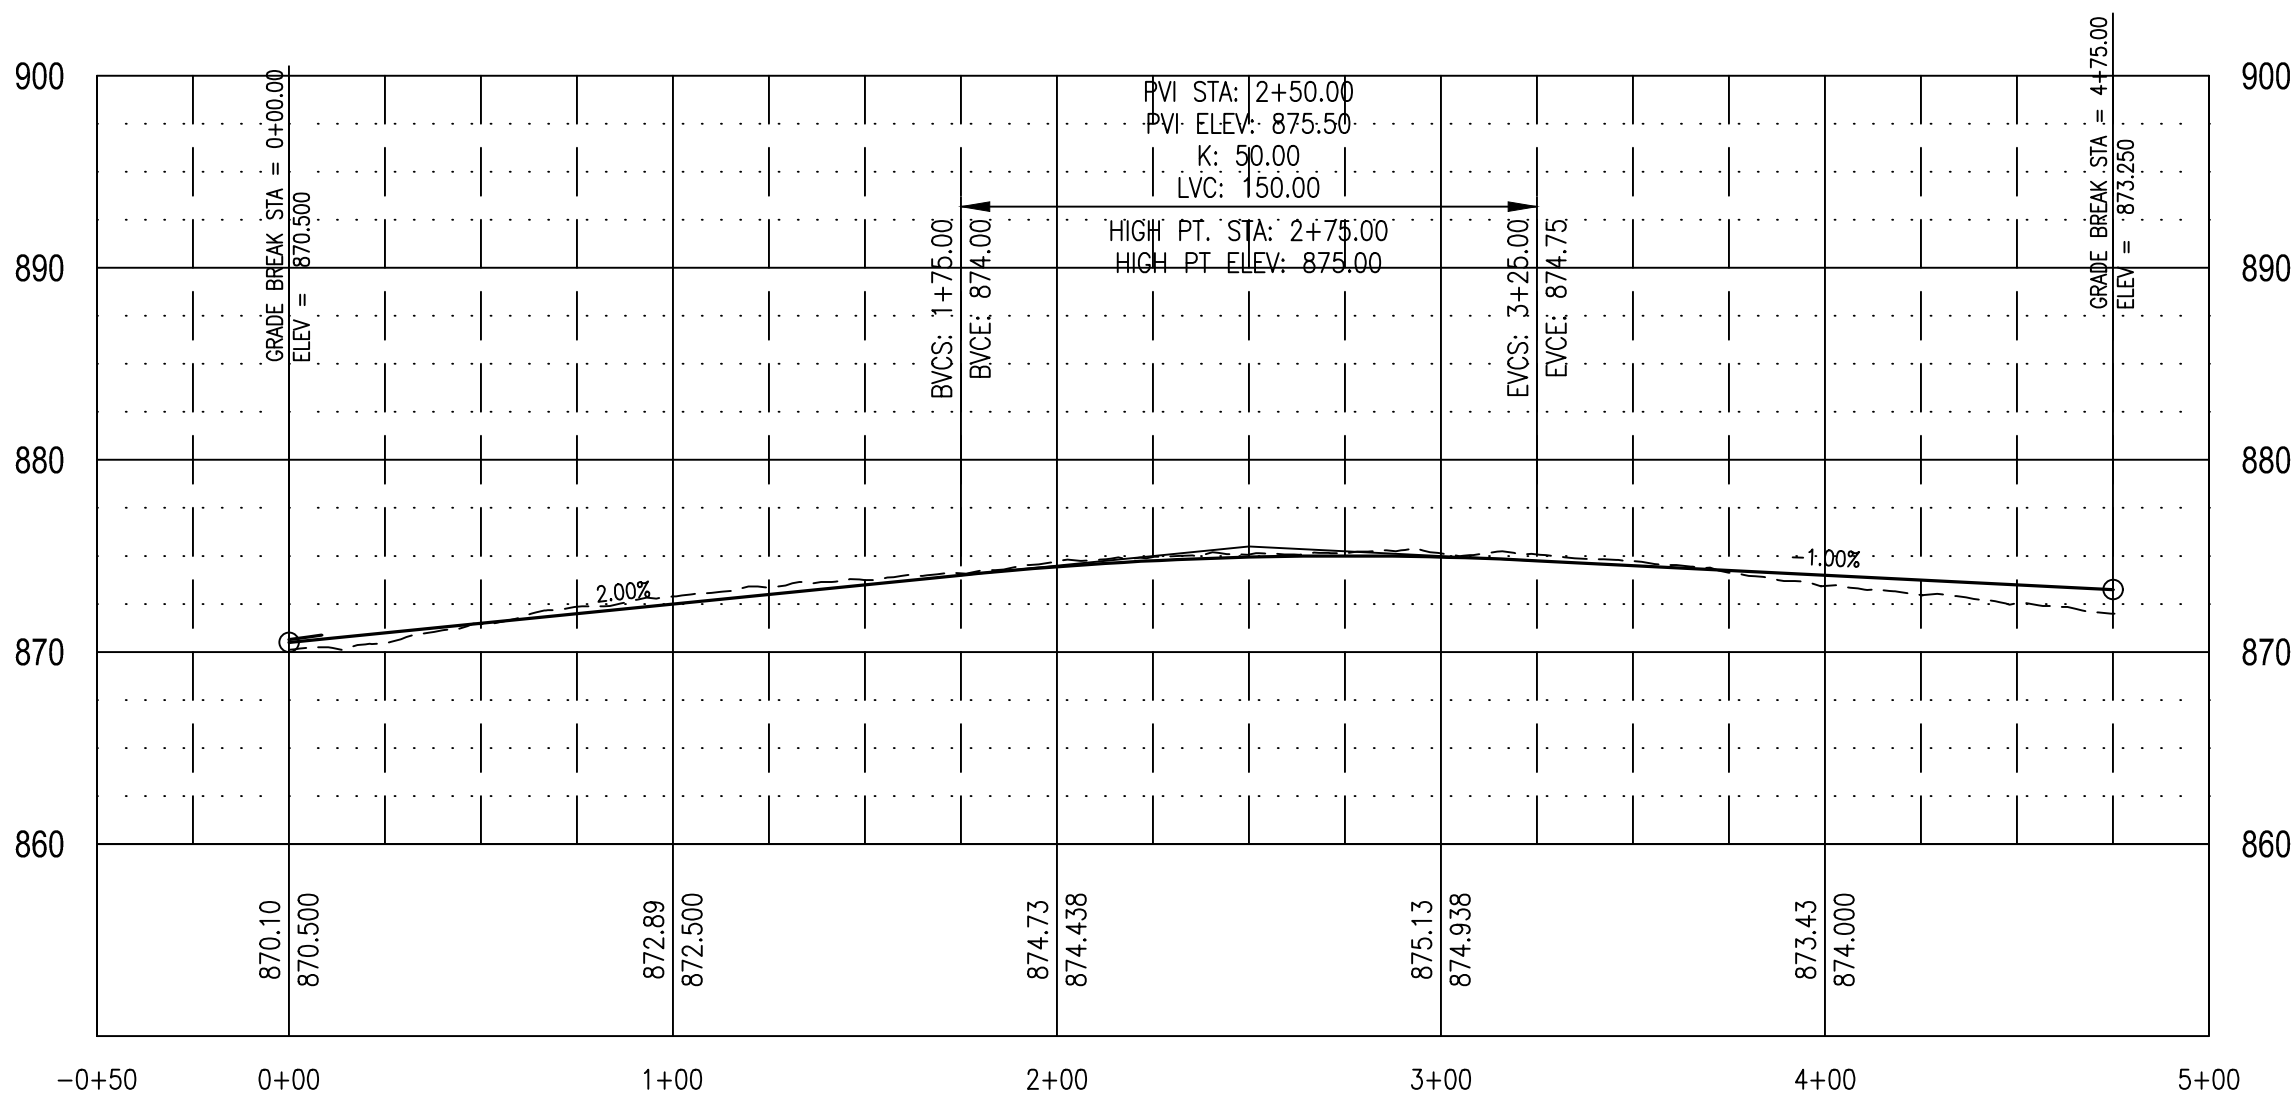

STREET M

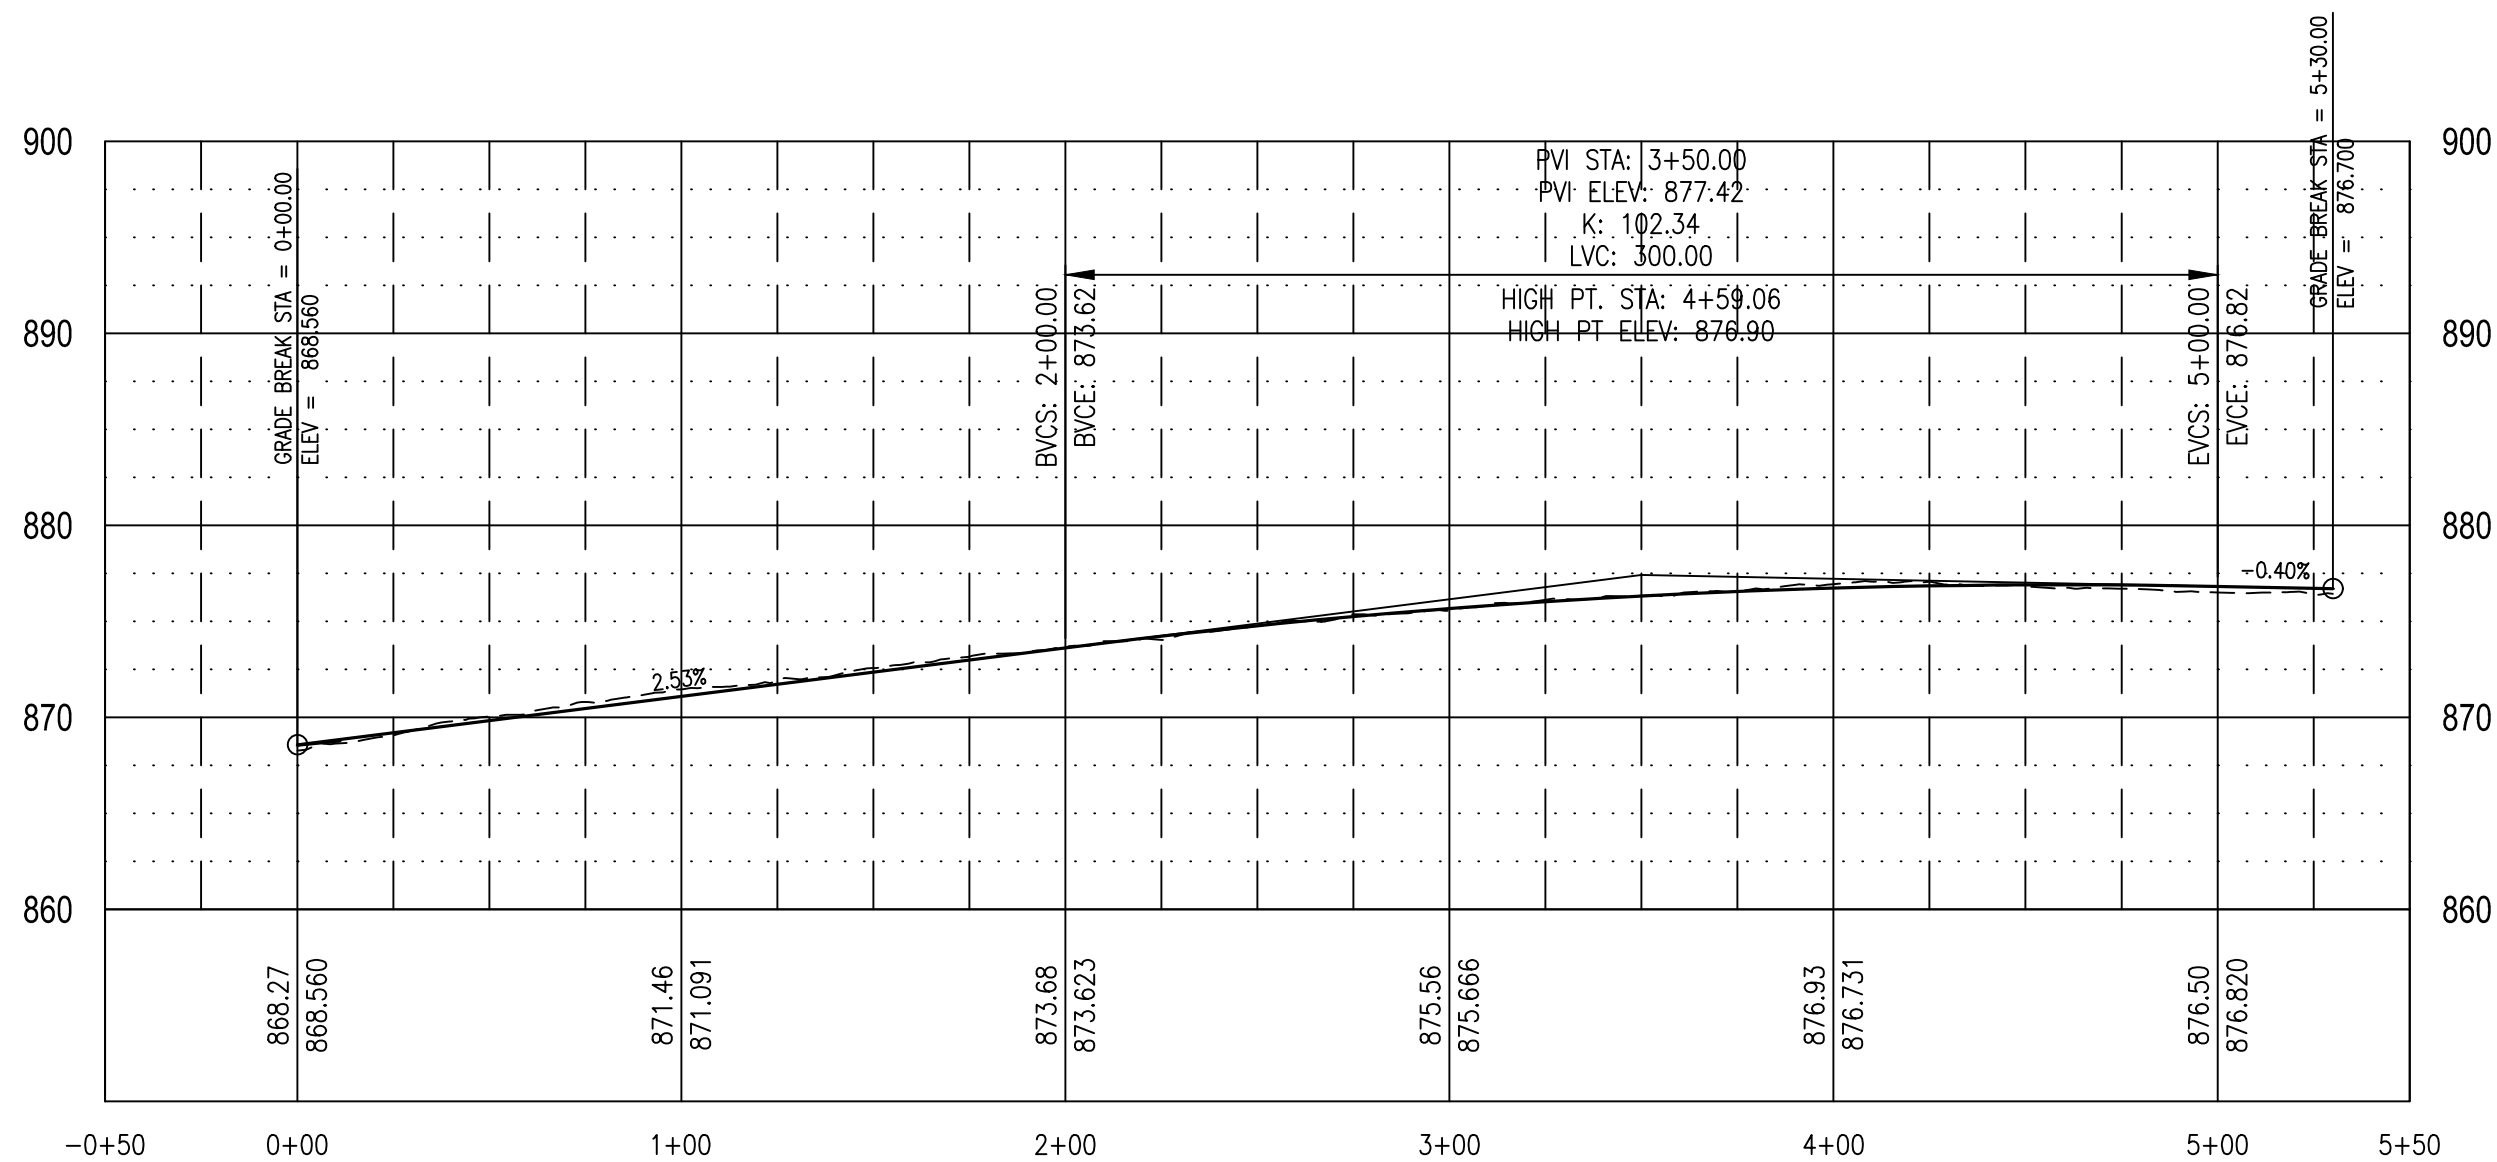

STATE OF MISSOURI
MIKE KEHOE,
GOVERNOR

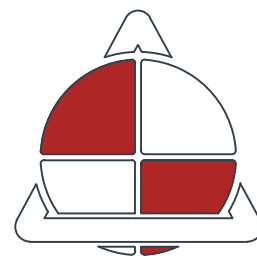

**ALLSTATE
CONSULTANTS**

allstateconsultants.net

3312 LEMONE INDUSTRIAL BLVD.
COLUMBIA, MO 65201
(573) 875-8799

P.O. BOX 156, 30601 HIGHWAY 5
MARCELINE, MO 64658
(660) 376-2941

410 SE THIRD ST., SUITE 103C
LEE'S SUMMIT, MO 64063
(816) 895-2310

MISSOURI STATE CERTIFICATE
OF AUTHORITY #2007004004
REUSE OF THIS DRAWING IN ANY MANNER IS
STRICTLY PROHIBITED WITHOUT THE WRITTEN
APPROVAL OF
ALLSTATE CONSULTANTS LLC

OFFICE OF ADMINISTRATION
DIVISION OF FACILITIES
MANAGEMENT,
DESIGN AND CONSTRUCTION

MISSOURI
STATE FAIRGROUNDS

NEW CAMPGROUND
CONSTRUCTION PLANS

MISSOURI
STATE FAIRGROUNDS
2503 W 16th STREET
SEDALIA, MO

PROJECT # F2307-01
SITE # 1501
ASSET # 3511501153

REVISION: _____
DATE: _____
REVISION: _____
DATE: _____
REVISION: _____
DATE: _____
ISSUE DATE: 11/11/2025

CAD DWG FILE: 231117.02-SHEETSBASE
DRAWN BY: DEP
CHECKED BY: CWS
DESIGNED BY: BPH


SHEET TITLE:
STREET PROFILES

SHEET NUMBER:

C-106

9 OF 43
11/11/2025




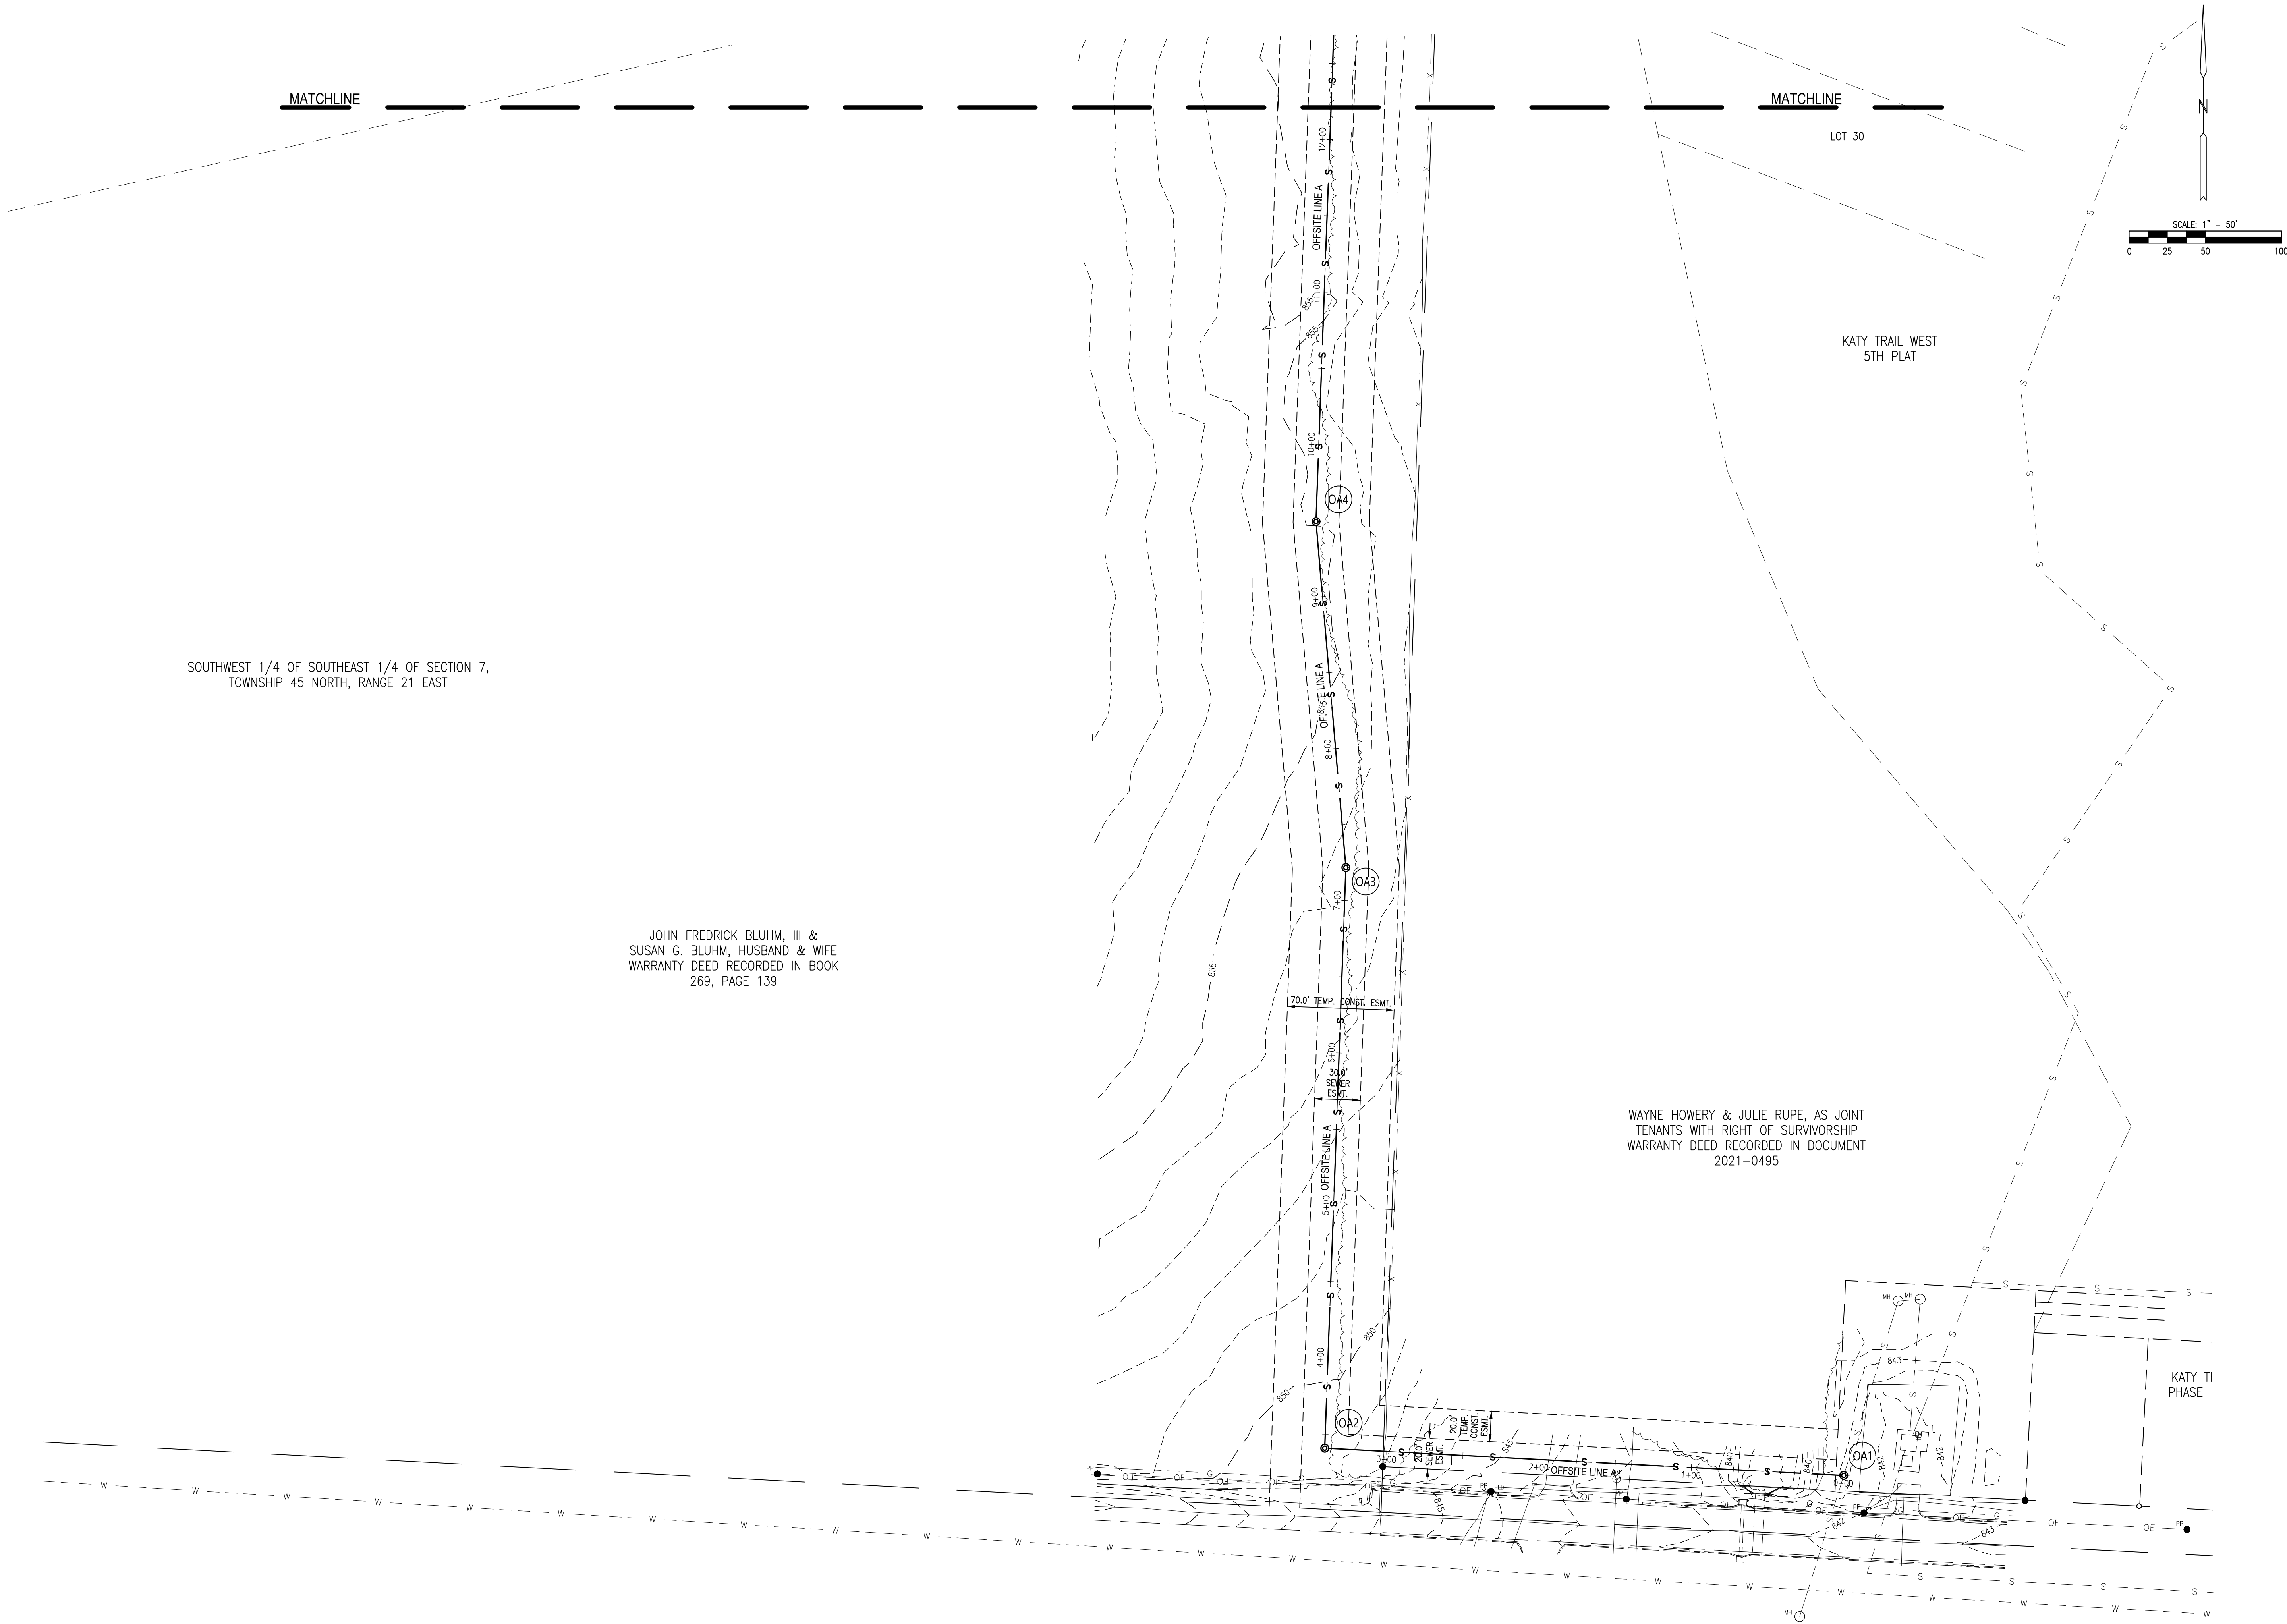


SOUTHWEST 1/4 OF SOUTHEAST 1/4 OF SECTION 7,
TOWNSHIP 45 NORTH, RANGE 21 EAST

JOHN FREDRICK BLUHM, III &
SUSAN G. BLUHM, HUSBAND & WIFE
WARRANTY DEED RECORDED IN BOOK
269, PAGE 139

WAYNE HOWERY & JULIE RUPE, AS JOINT
TENANTS WITH RIGHT OF SURVIVORSHIP
WARRANTY DEED RECORDED IN DOCUMENT
2021-0495

STATE OF MISSOURI
MIKE KEHOE,
GOVERNOR

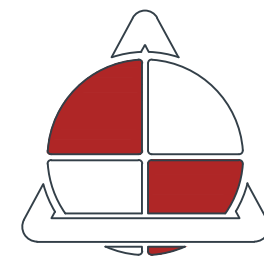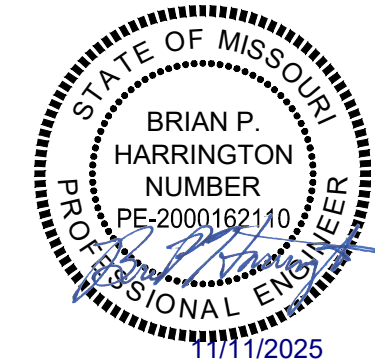

ALLSTATE
CONSULTANTS
allstateconsultants.net
3312 LEMONE INDUSTRIAL BLVD.
COLUMBIA, MO 65201
(573) 875-8799
P.O. BOX 156, 30601 HIGHWAY 5
MARCELINE, MO 64658
(660) 376-2941
410 SE THIRD ST., SUITE 103C
LEE'S SUMMIT, MO 64063
(816) 895-2310
MISSOURI STATE CERTIFICATE
OF AUTHORITY #2007004004
REUSE OF THIS DRAWING IN ANY MANNER IS
STRICTLY PROHIBITED WITHOUT THE WRITTEN
APPROVAL OF
ALLSTATE CONSULTANTS LLC

OFFICE OF ADMINISTRATION
DIVISION OF FACILITIES
MANAGEMENT,
DESIGN AND CONSTRUCTION

MISSOURI
STATE FAIRGROUNDS

NEW CAMPGROUND
CONSTRUCTION PLANS

MISSOURI
STATE FAIRGROUNDS
2503 W 16th STREET
SEDALIA, MO

PROJECT # F2307-01
SITE # 1501
ASSET # 3511501153

REVISION: _____
DATE: _____
REVISION: _____
DATE: _____
REVISION: _____
DATE: _____
ISSUE DATE: 11/11/2025

CAD DWG FILE: 231117.02-SHEETSBASE
DRAWN BY: DEP
CHECKED BY: CWS
DESIGNED BY: BPH

SHEET TITLE:
SANITARY SEWER


SHEET NUMBER:

C-201

12 OF 43
11/11/2025

S 104.00

MATCHLINE

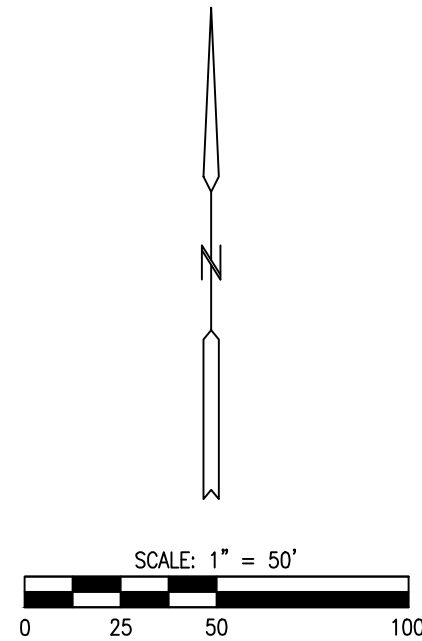


1.Katy Trail Sewer Bore: The sanitary sewer located in the Katy Trail Right-of-Way (Sta. 13+54 to Sta. 14+53) shall be bored with steel encasement and provided with restrained joint PVC carrier pipe.

- A.Steel Casing Pipe
- 1.Material: Steel, Comply with ASTM A53
 - 2.Minimum Yield Strength: 35,000 psi
 - 3.Minimum Thickness: 0.375 inch
 - 4.Diameter: 18 inch
 - 5.Length: 100 L.F.
 - 6.Welded Joints comply with AWS D1.1
 - 7.Cathodic Protection: 17 lb. anode pack

- B.Carrier Pipe
- 1.Material: Restrained Joint PVC, ASTM D2241, SDR-21
 - 2.Diameter: 10 inch
 - 3.Length: 115 L.F.

- C.Casing Spacers
- 1.Material: Polyethylene, Injection Molded
 - 2.Spacing: Max. 8 feet, Min. 3 spacers per stick of pipe


- D.End Seals
- 1.Material: 1/8" Thick Synthetic Rubber
 - 2.Type: Pull On
 - 3.Bands: Stainless Steel

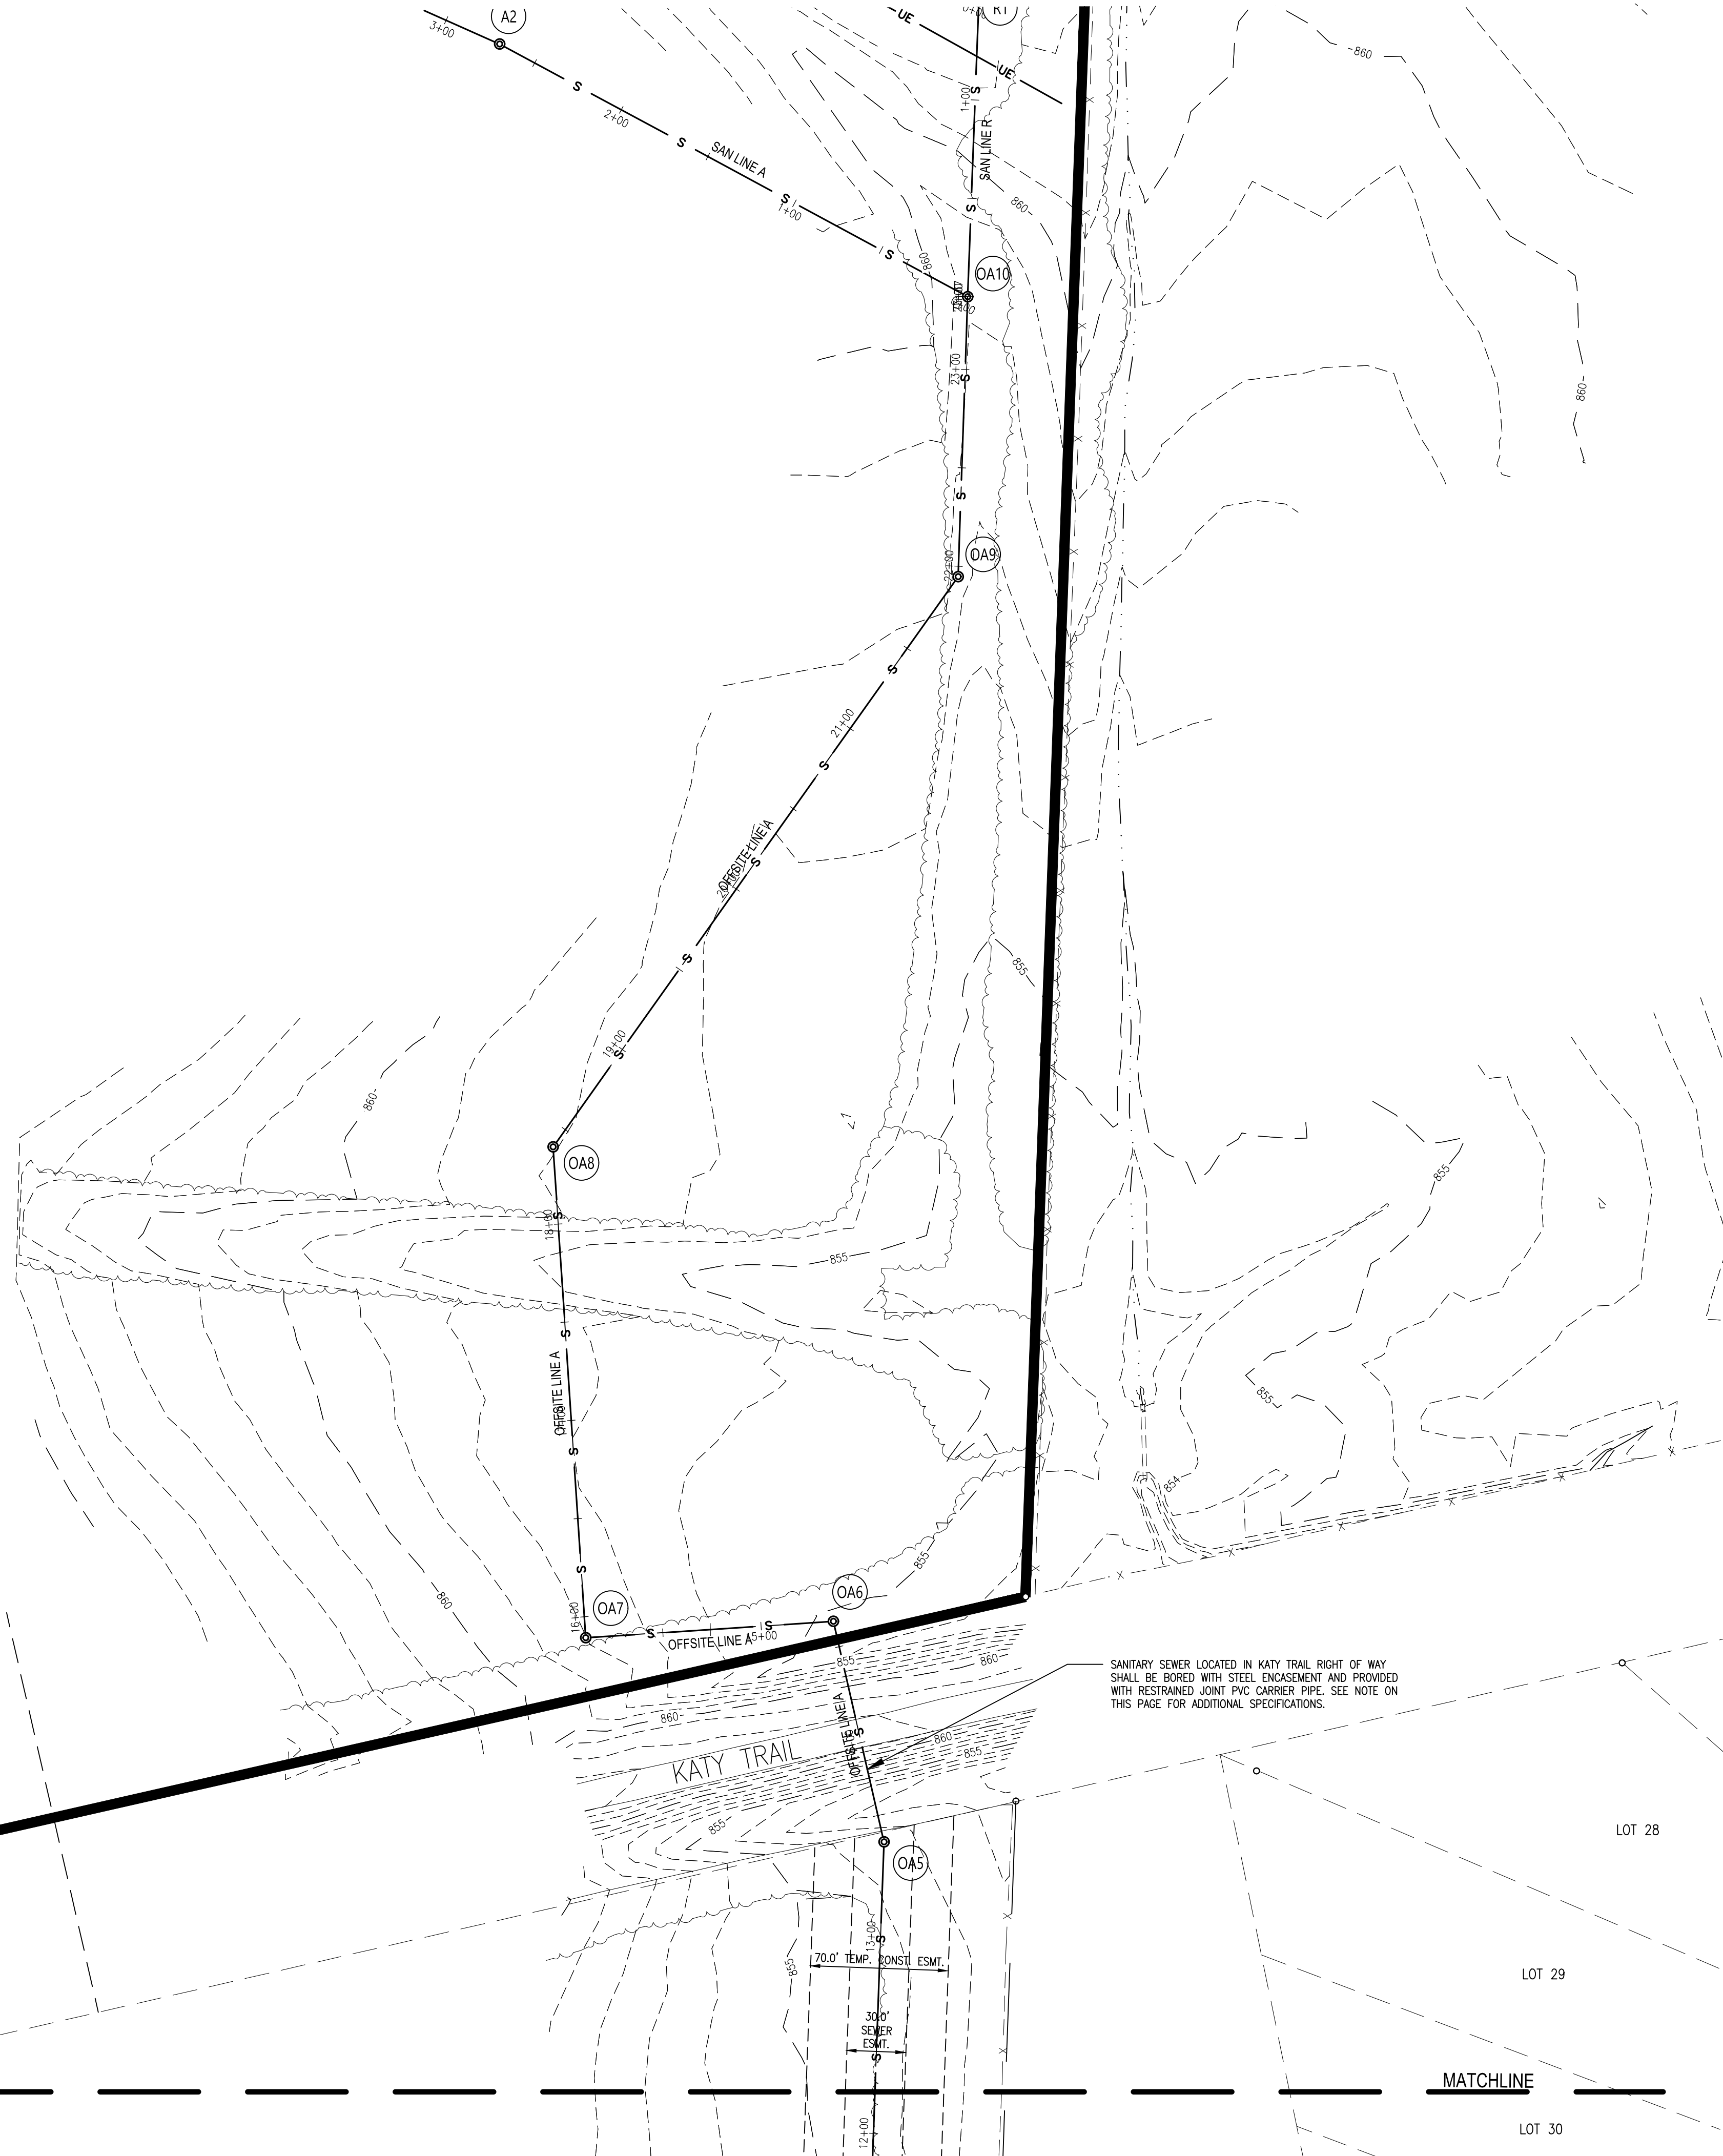

MATCHLINE

MATCHLINE

STATE OF MISSOURI
MIKE KEHOE,
GOVERNOR

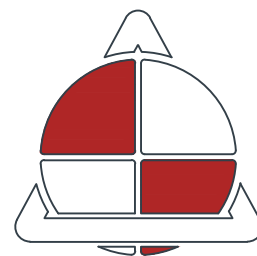

ALLSTATE
CONSULTANTS

allstateconsultants.net

3312 LEMONE INDUSTRIAL BLVD.
COLUMBIA, MO 65201
(573) 875-8799

P.O. BOX 156, 30601 HIGHWAY 5
MARCELINE, MO 64658
(660) 376-2941

410 SE THIRD ST., SUITE 103C
LEE'S SUMMIT, MO 64063
(816) 895-2310

MISSOURI STATE CERTIFICATE
OF AUTHORITY #2007004004
REUSE OF THIS DRAWING IN ANY MANNER IS
STRICTLY PROHIBITED WITHOUT THE WRITTEN
APPROVAL OF
ALLSTATE CONSULTANTS LLC

OFFICE OF ADMINISTRATION
DIVISION OF FACILITIES
MANAGEMENT,
DESIGN AND CONSTRUCTION

MISSOURI
STATE FAIRGROUNDS

NEW CAMPGROUND
CONSTRUCTION PLANS

MISSOURI
STATE FAIRGROUNDS
2503 W 16th STREET
SEDALIA, MO

PROJECT # F2307-01
SITE # 1501
ASSET # 3511501153

REVISION: _____
DATE: _____
REVISION: _____
DATE: _____
REVISION: _____
DATE: _____
ISSUE DATE: 11/11/2025

CAD DWG FILE:23117.02-SHEETSBASE
DRAWN BY: DEP
CHECKED BY: CWS
DESIGNED BY: BPH

SHEET TITLE:
SANITARY SEWER

SHEET NUMBER:

C-202

13 OF 43
11/11/2025

P:\2023\23117.02 - Campgrounds Expansion\DWG\DESIGN\23117.02-SHEETSBASE_SANITARY.dwg, C-202, 11/11/2025 12:32:08 PM



MISSOURI STATE CERTIFICATE
OF AUTHORITY #2007004004

REUSE OF THIS DRAWING IN ANY MANNER IS
STRICTLY PROHIBITED WITHOUT THE WRITTEN
APPROVAL OF
ALLSTATE CONSULTANTS LLC

MISSOURI
STATE FAIRGROUNDS

PROJECT # F2307-01
SITE # 1501
ASSET # 3511501153

REVISION: _____
DATE: _____
REVISION: _____
DATE: _____
REVISION: _____
DATE: _____
ISSUE DATE: 11/11/2025


CAD DWG FILE: 23117.02-SHEETSBASE
DRAWN BY: DEP
CHECKED BY: CWS
DESIGNED BY: BPH


SHEET TITLE:
SANITARY SEWER

SHEET NUMBER:


C-203

14 OF 43
11/11/2025

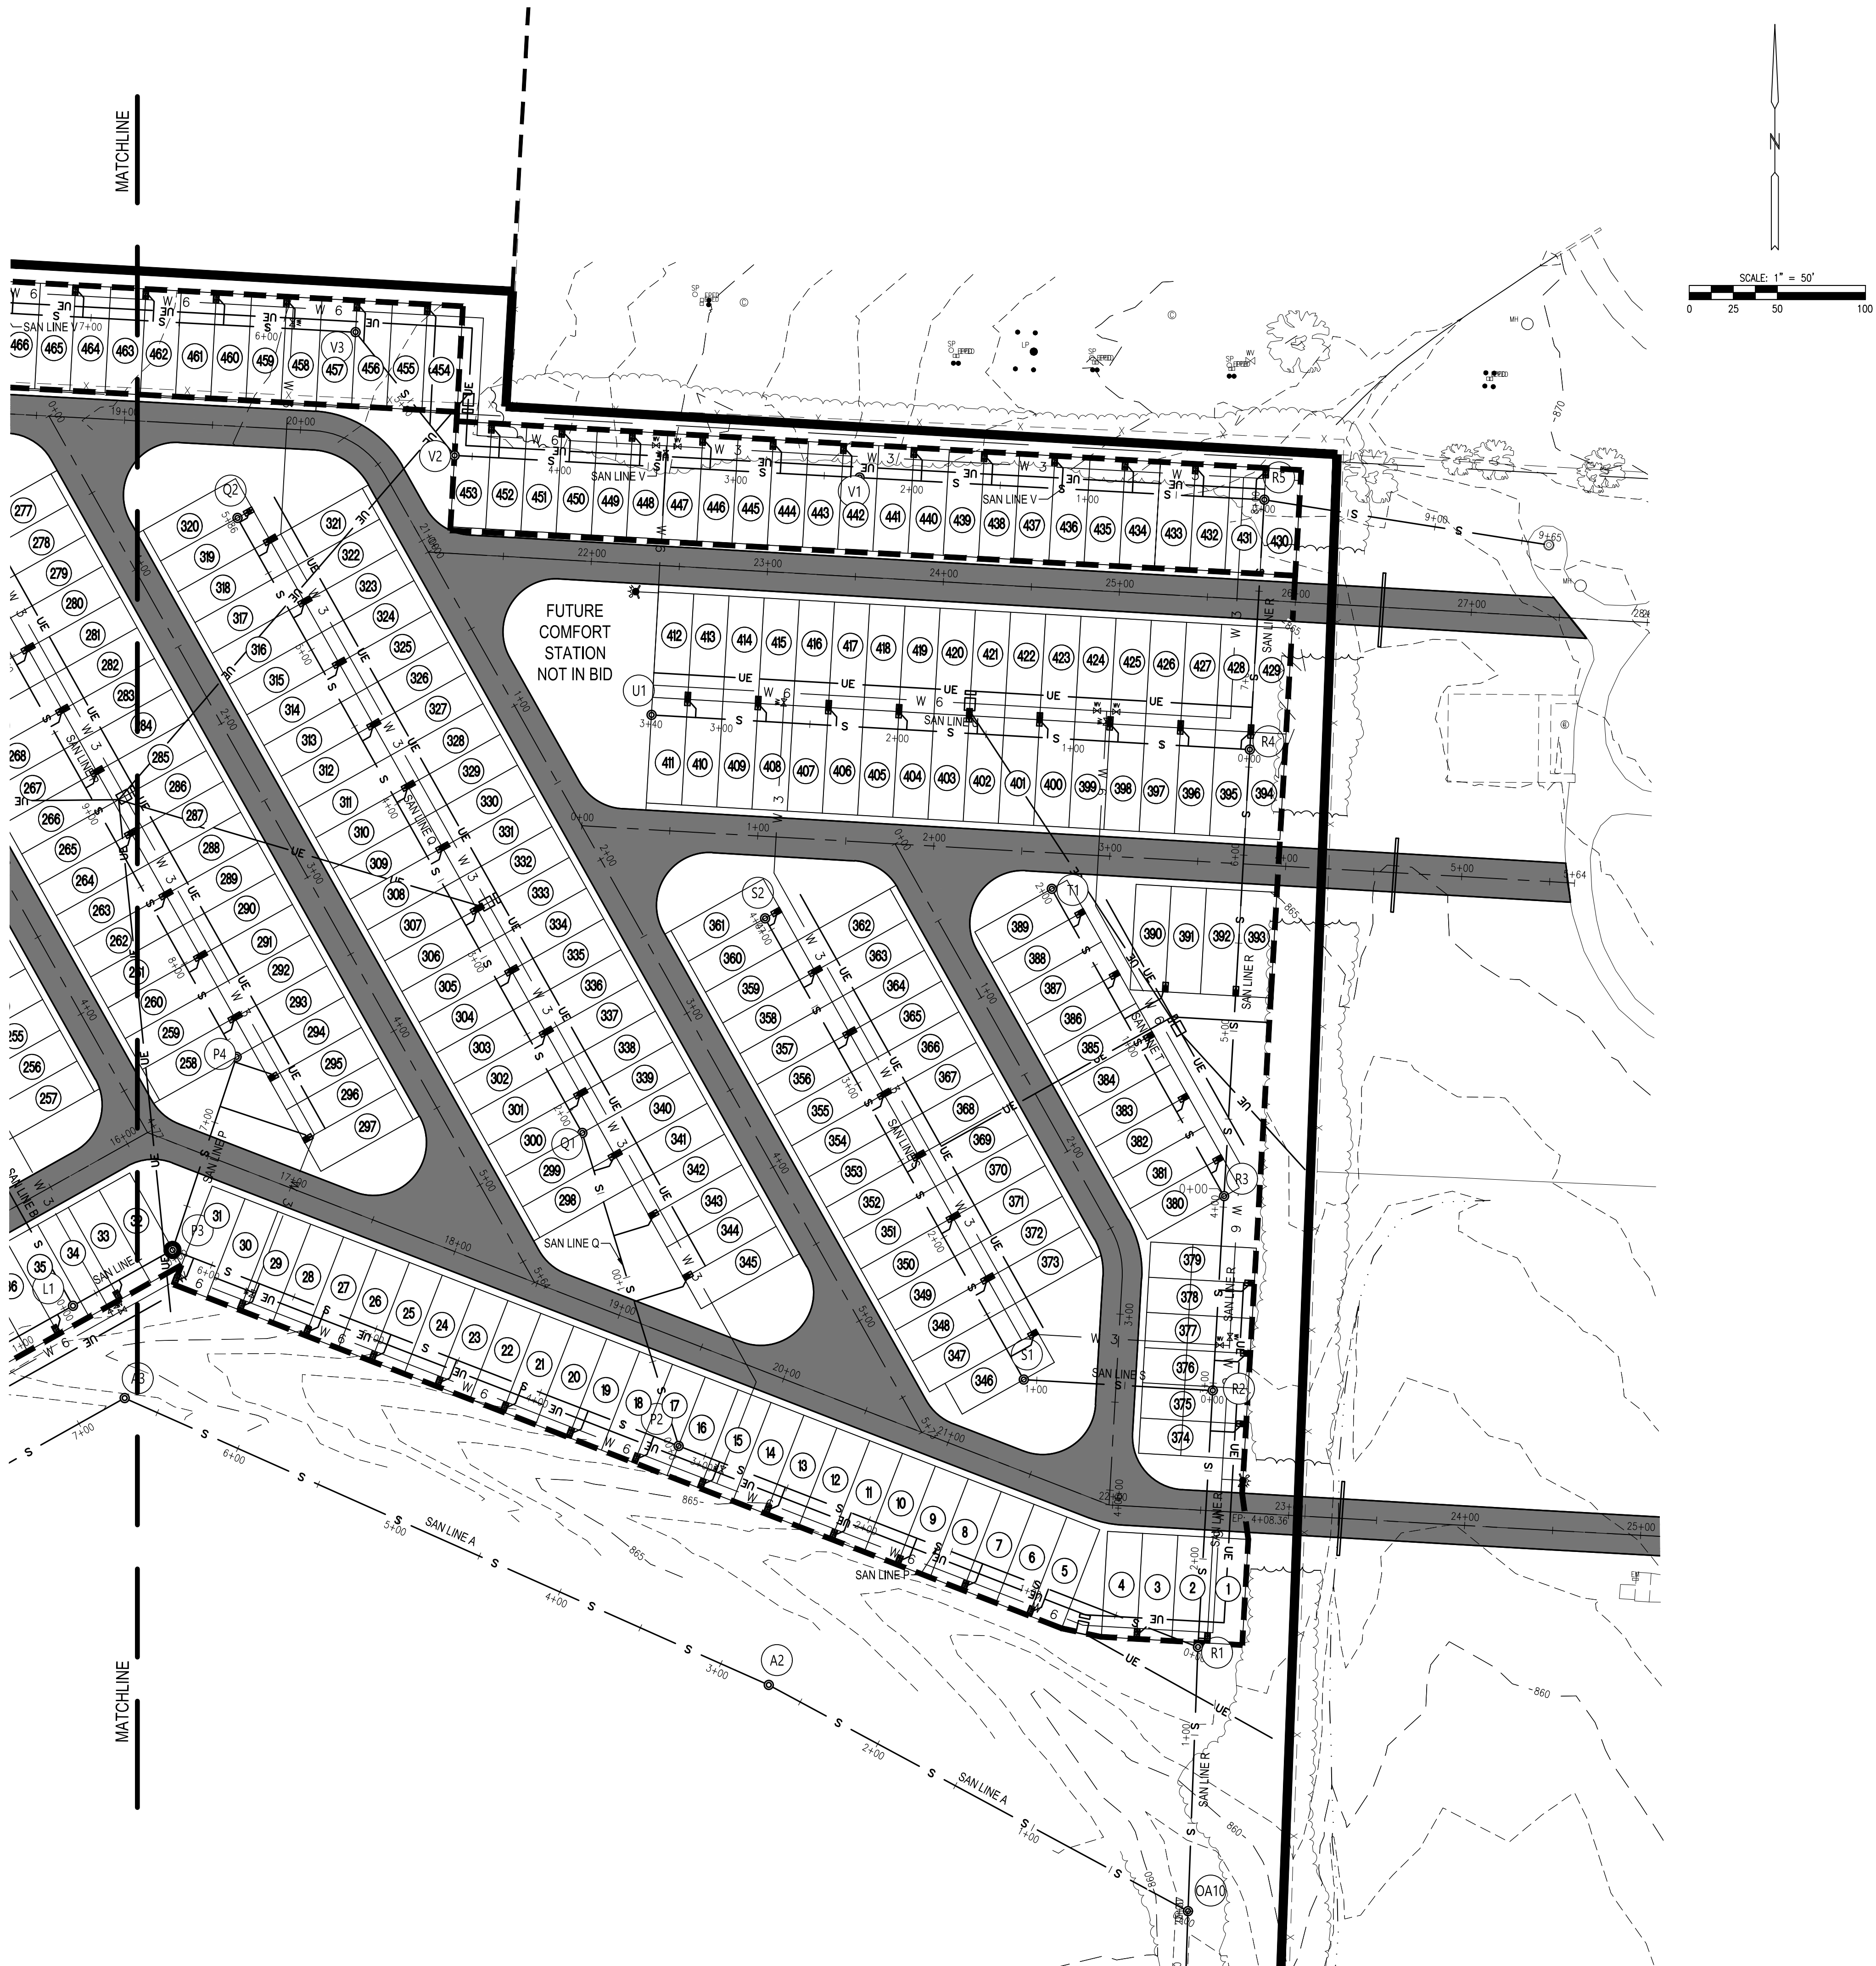

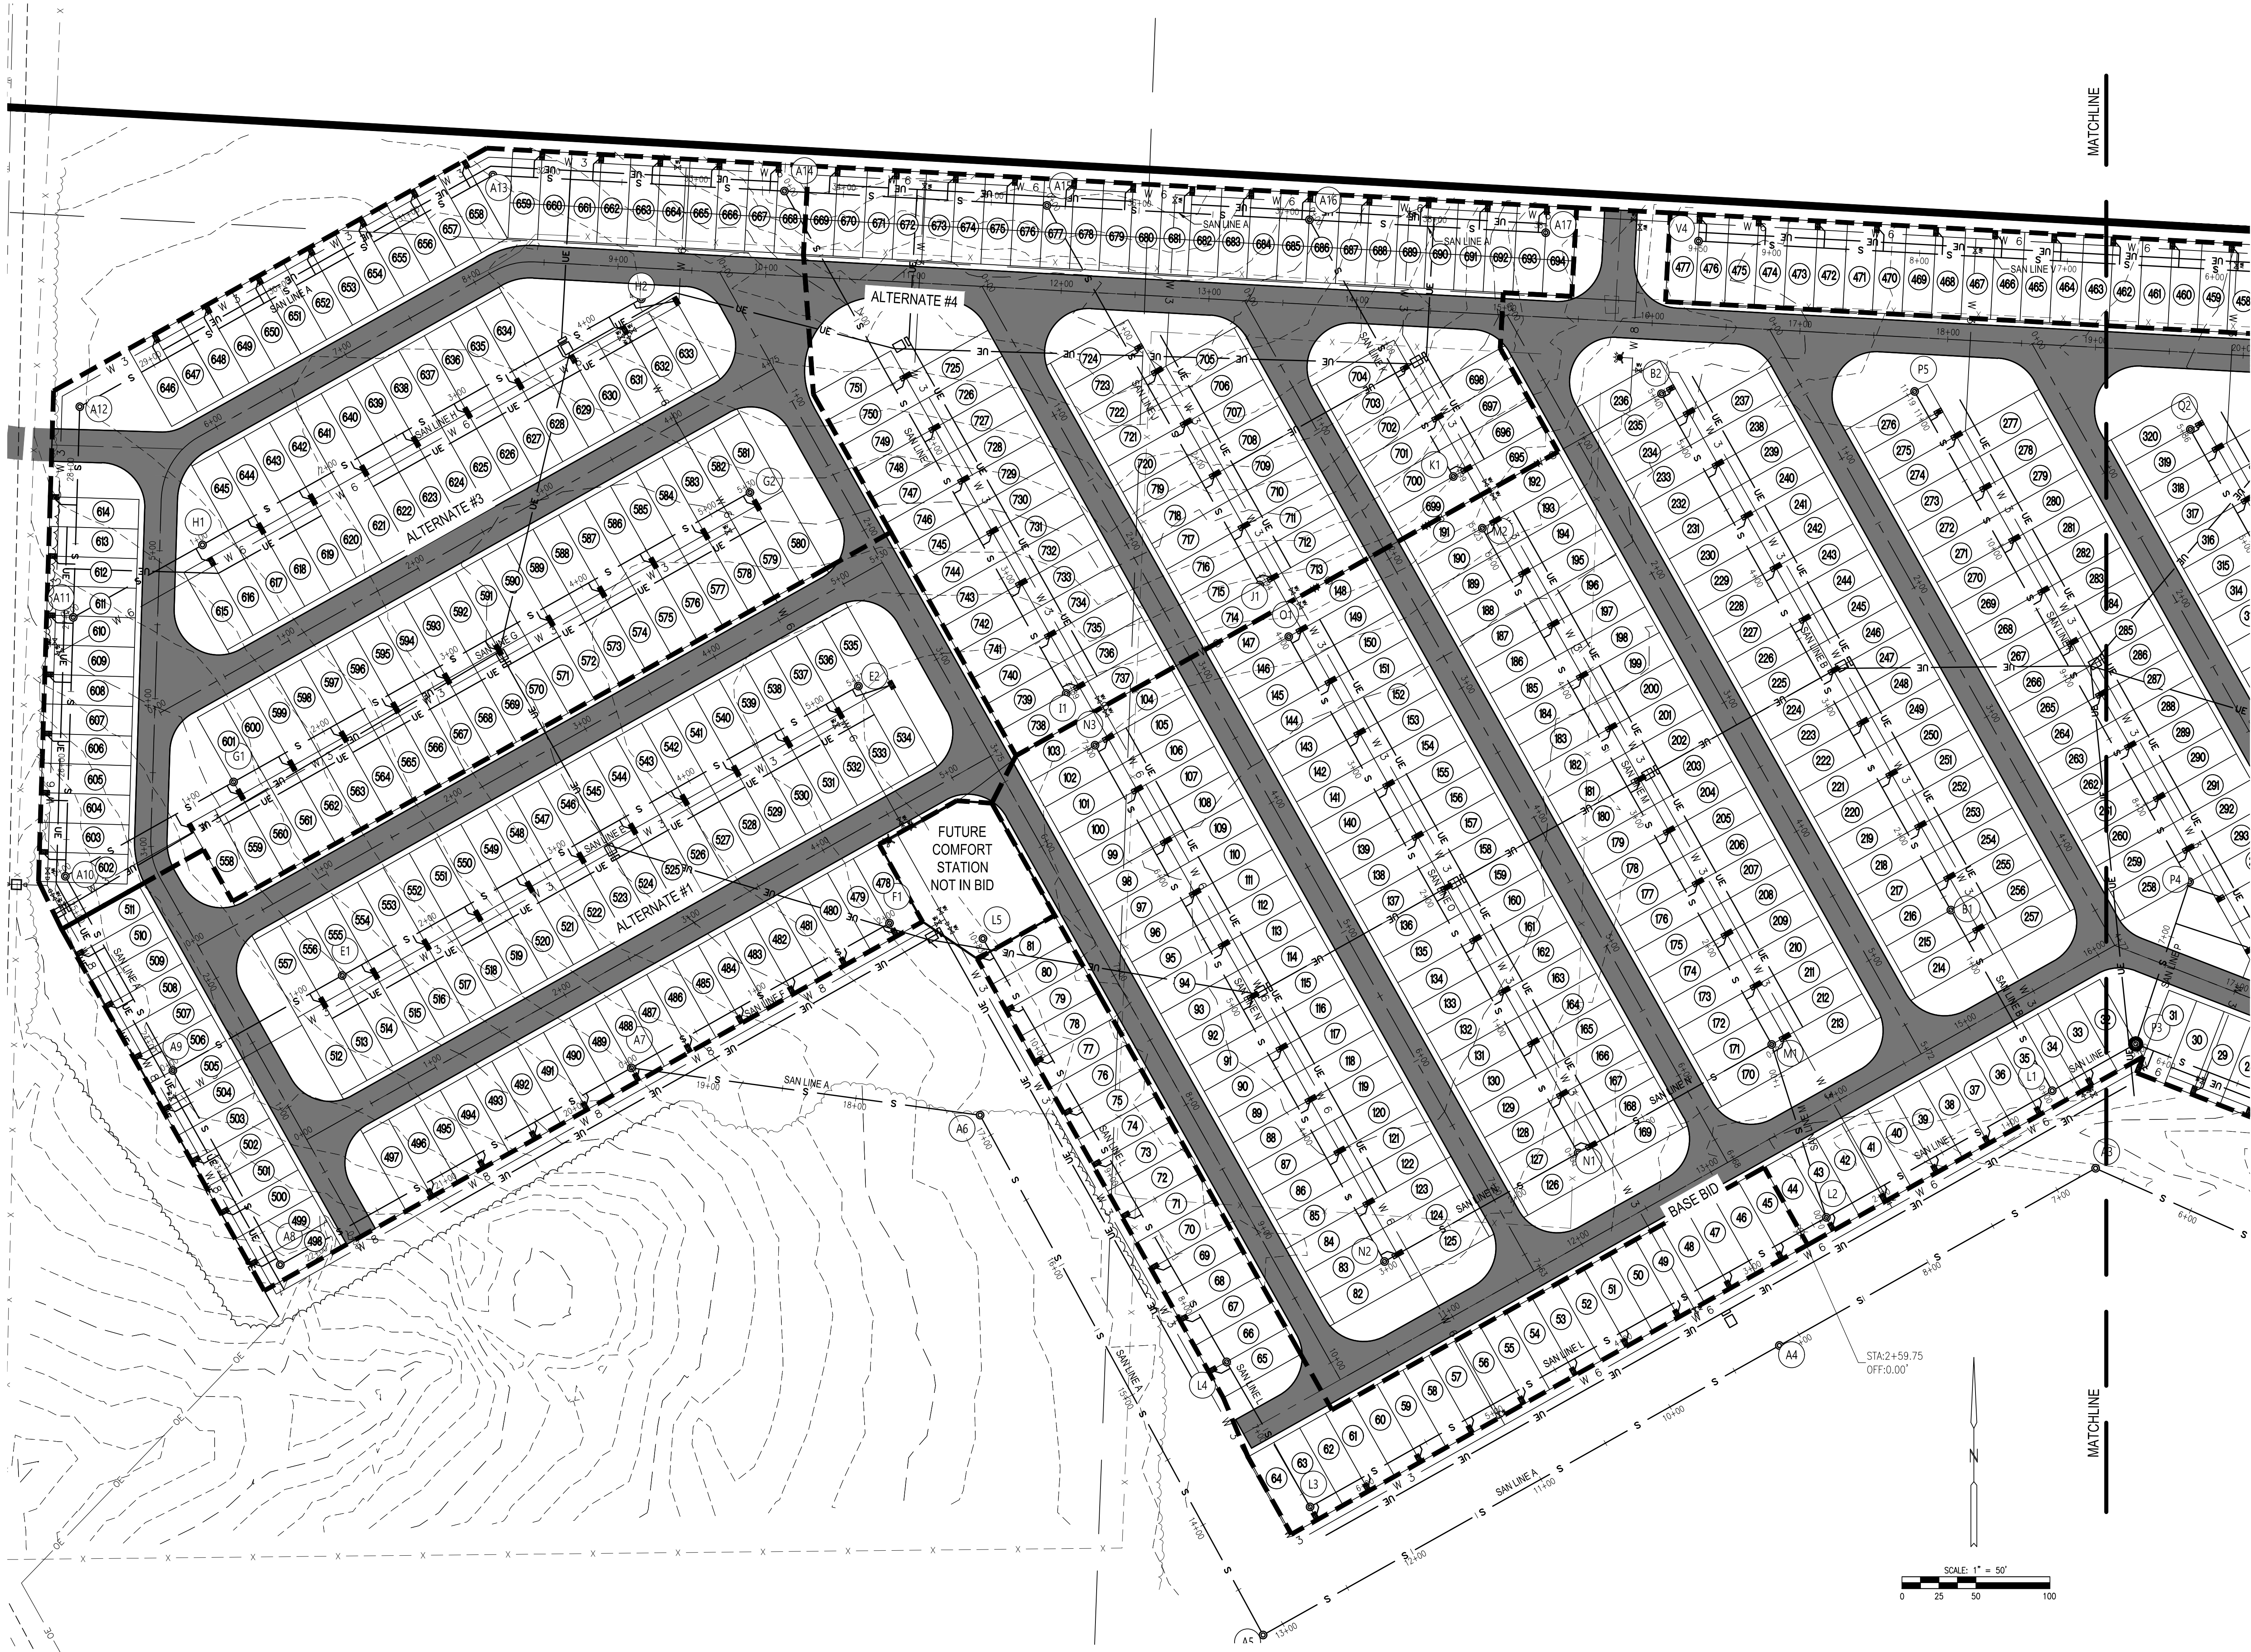

STATE OF MISSOURI
MIKE KEHOE,
GOVERNOR

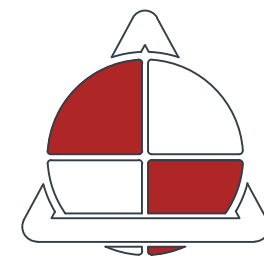

ALLSTATE
CONSULTANTS

allstateconsultants.net

3312 LEMONE INDUSTRIAL BLVD.
COLUMBIA, MO 65201
(573) 875-8799

P.O. BOX 156, 30601 HIGHWAY 5
MARCELINE, MO 64658
(660) 376-2941

410 SE THIRD ST., SUITE 103C
LEE'S SUMMIT, MO 64063
(816) 895-2310

MISSOURI STATE CERTIFICATE
OF AUTHORITY #2007004004
REUSE OF THIS DRAWING IN ANY MANNER IS
STRICTLY PROHIBITED WITHOUT THE WRITTEN
APPROVAL OF
ALLSTATE CONSULTANTS LLC

OFFICE OF ADMINISTRATION
DIVISION OF FACILITIES
MANAGEMENT,
DESIGN AND CONSTRUCTION

MISSOURI
STATE FAIRGROUNDS

NEW CAMPGROUND
CONSTRUCTION PLANS

MISSOURI
STATE FAIRGROUNDS
2503 W 16th STREET
SEDALIA, MO

PROJECT # F2307-01
SITE # 1501
ASSET # 3511501153

REVISION: _____
DATE: _____
REVISION: _____
DATE: _____
REVISION: _____
DATE: _____
ISSUE DATE: 11/11/2025

CAD DWG FILE: 23117.02-SHEETSBASE
DRAWN BY: DEP
CHECKED BY: CWS
DESIGNED BY: BPH



SHEET TITLE:
SANITARY SEWER

SHEET NUMBER:

C-204


15 OF 43
11/11/2025

P:\2023\23117.02 - Campgrounds Expansion\DWG\DESIGN\23117.02-SHEETSBASE SANITARY.dwg, C:\PWA, 11/11/2025 12:33:12 PM

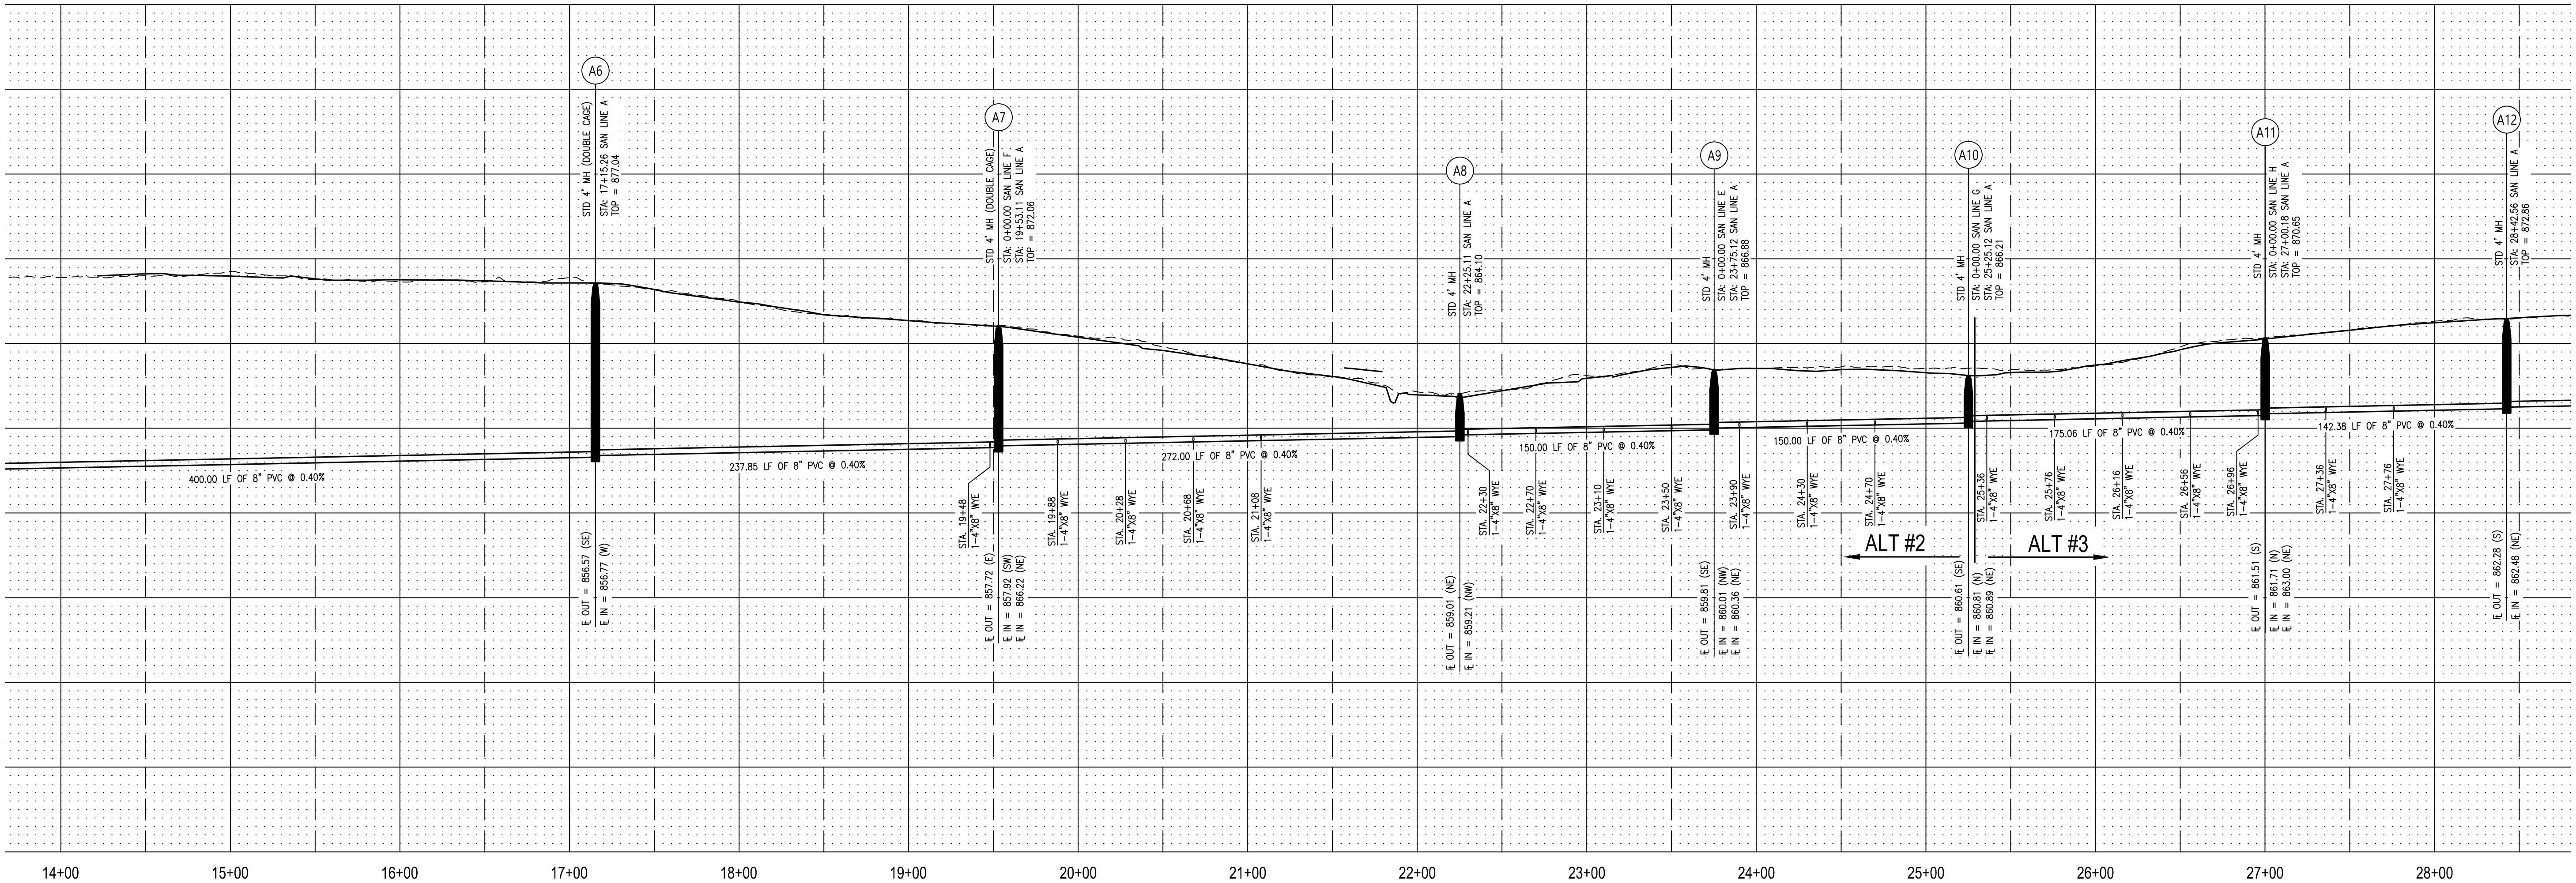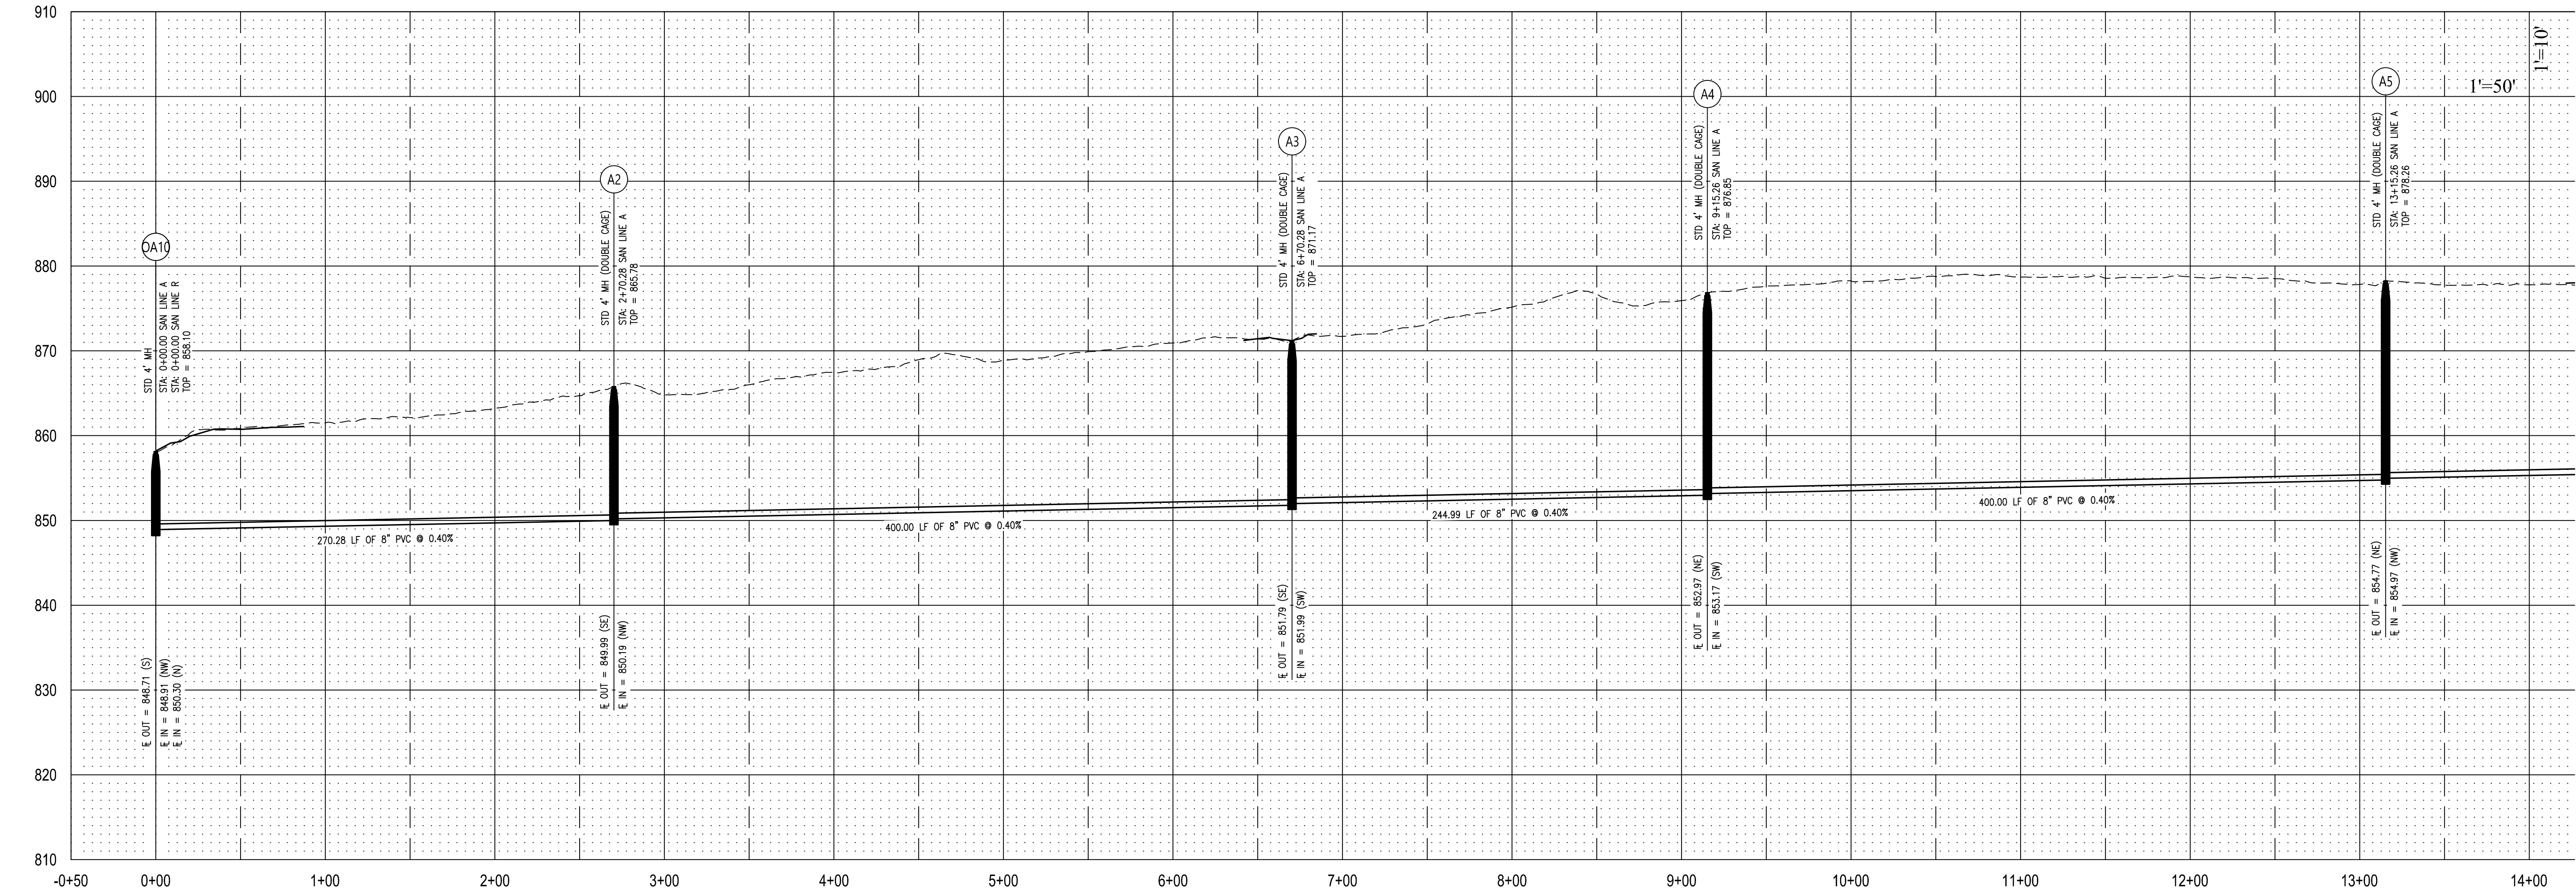

SAN LINE A (ALTERNATE #2, #3 & #4)

STATE OF MISSOURI
MIKE KEHOE,
GOVERNOR

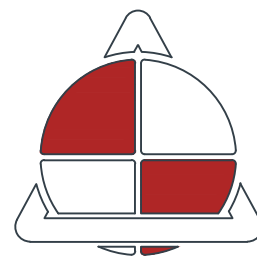

ALLSTATE
CONSULTANTS
allstateconsultants.net
3312 LEMONE INDUSTRIAL BLVD.
COLUMBIA, MO 65201
(573) 875-8799
P.O. BOX 156, 30601 HIGHWAY 5
MARCELINE, MO 64658
(660) 376-2941
410 SE THIRD ST., SUITE 103C
LEE'S SUMMIT, MO 64063
(816) 895-2310
MISSOURI STATE CERTIFICATE
OF AUTHORITY #2007004004
REUSE OF THIS DRAWING IN ANY MANNER IS
STRICTLY PROHIBITED WITHOUT THE WRITTEN
APPROVAL OF
ALLSTATE CONSULTANTS LLC

OFFICE OF ADMINISTRATION
DIVISION OF FACILITIES
MANAGEMENT,
DESIGN AND CONSTRUCTION

MISSOURI
STATE FAIRGROUNDS

NEW CAMPGROUND
CONSTRUCTION PLANS

MISSOURI
STATE FAIRGROUNDS
2503 W 16th STREET
SEDALIA, MO


PROJECT # F2307-01
SITE # 1501
ASSET # 3511501153

REVISION: _____
DATE: _____
REVISION: _____
DATE: _____
REVISION: _____
DATE: _____
ISSUE DATE: 11/11/2025


CAD DWG FILE: 231117.02-SHEETSBASE
DRAWN BY: DEP
CHECKED BY: CWS
DESIGNED BY: BPH

SHEET TITLE:
SANITARY SEWER


SHEET NUMBER:
C-205
16 OF 43
11/11/2025

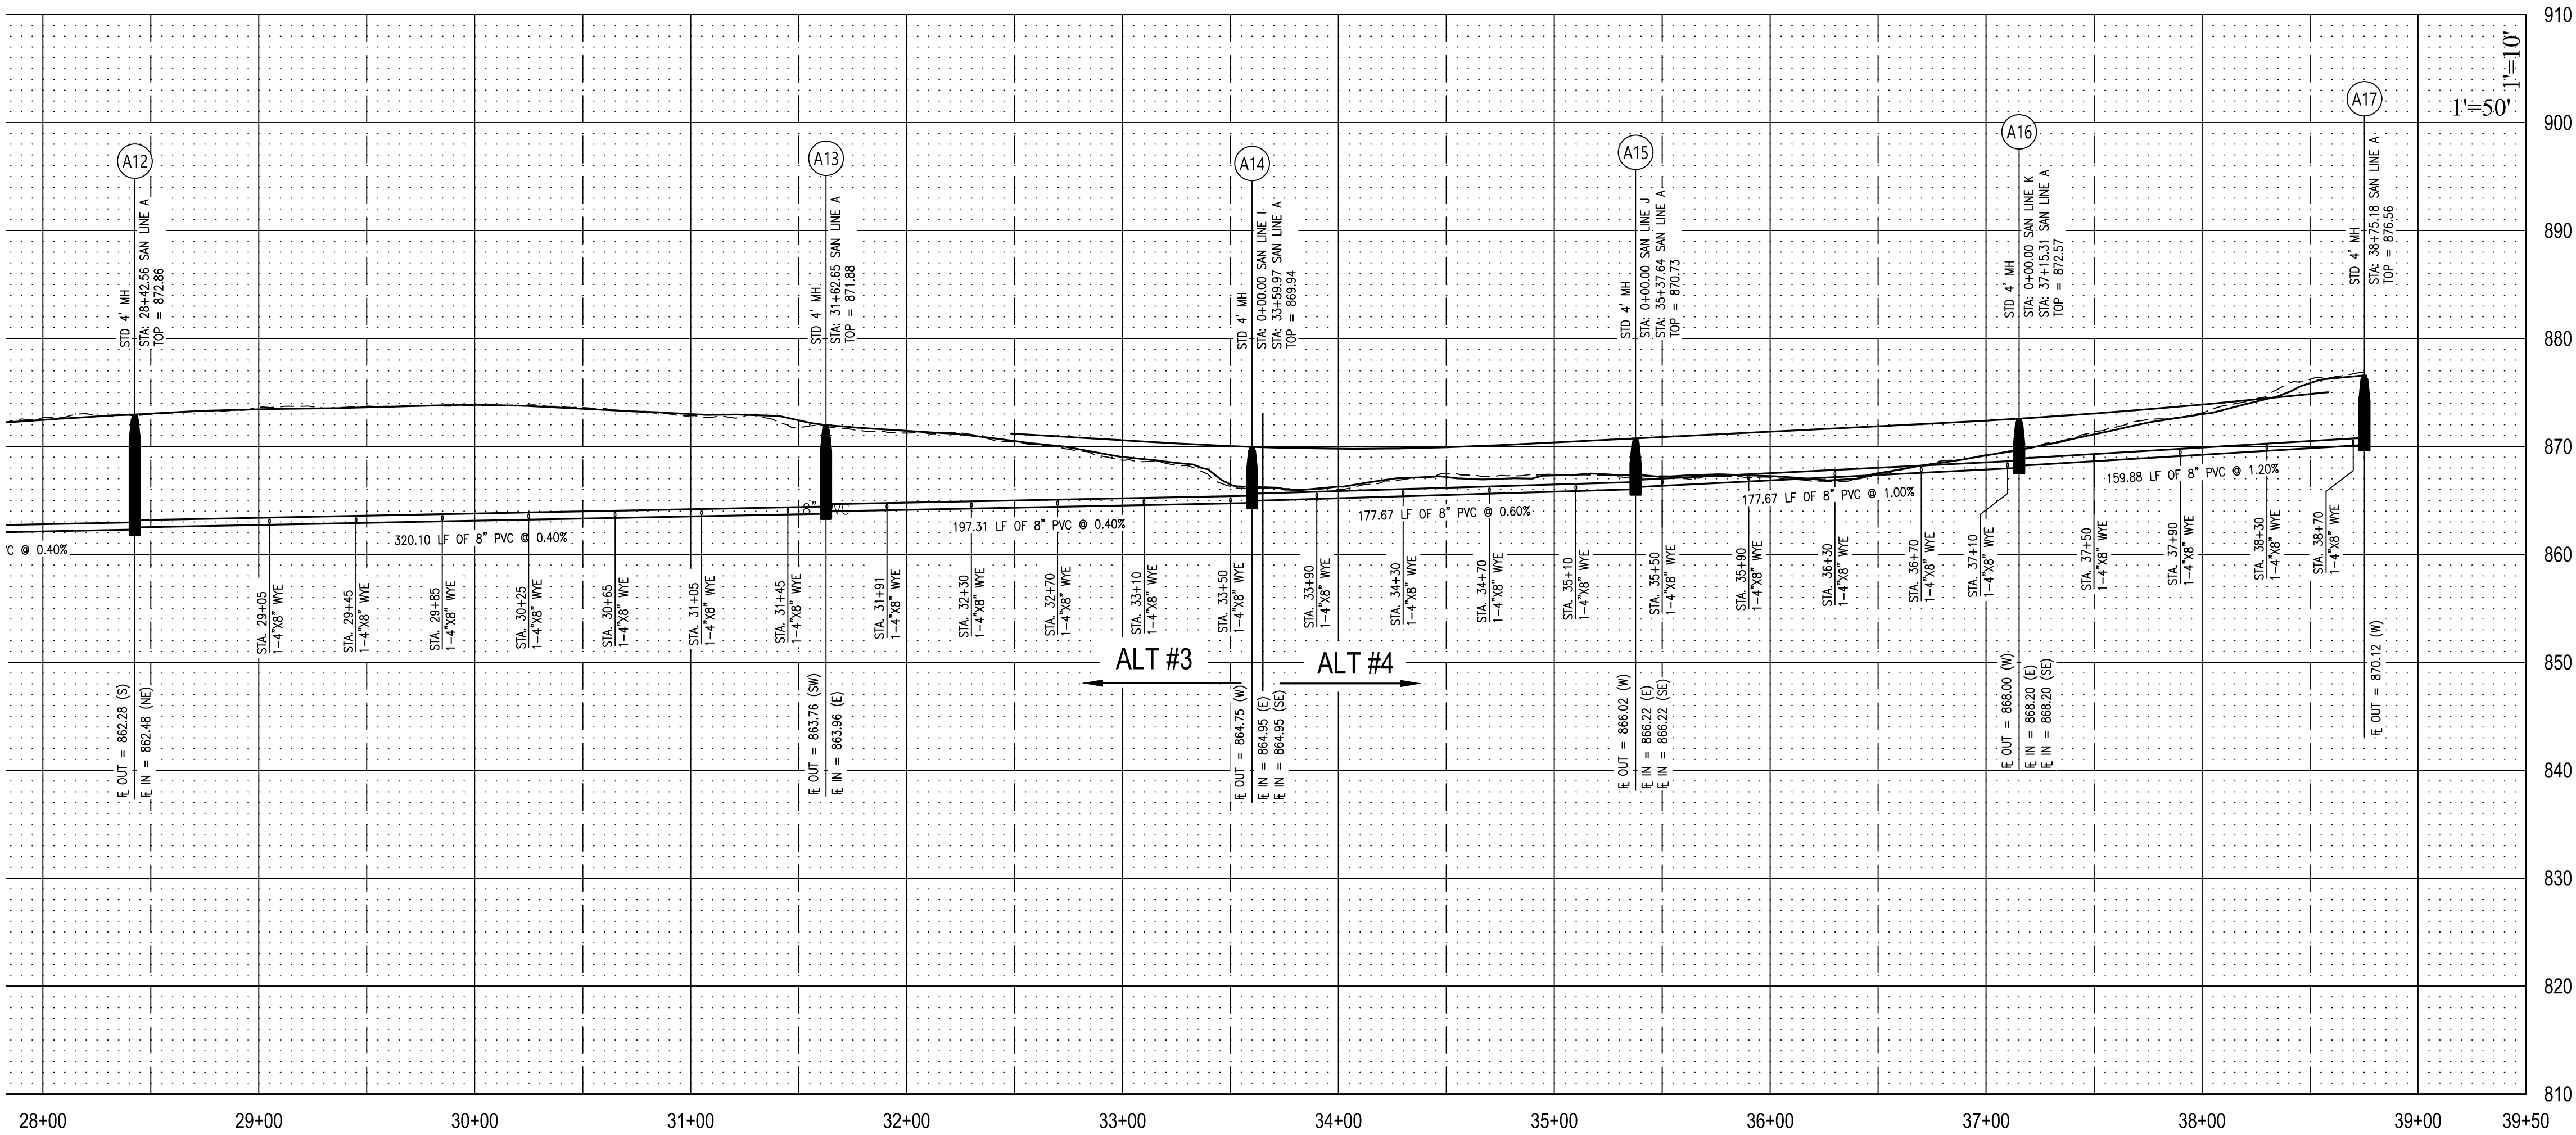

(ALTERNATE #2, #3 & #4)

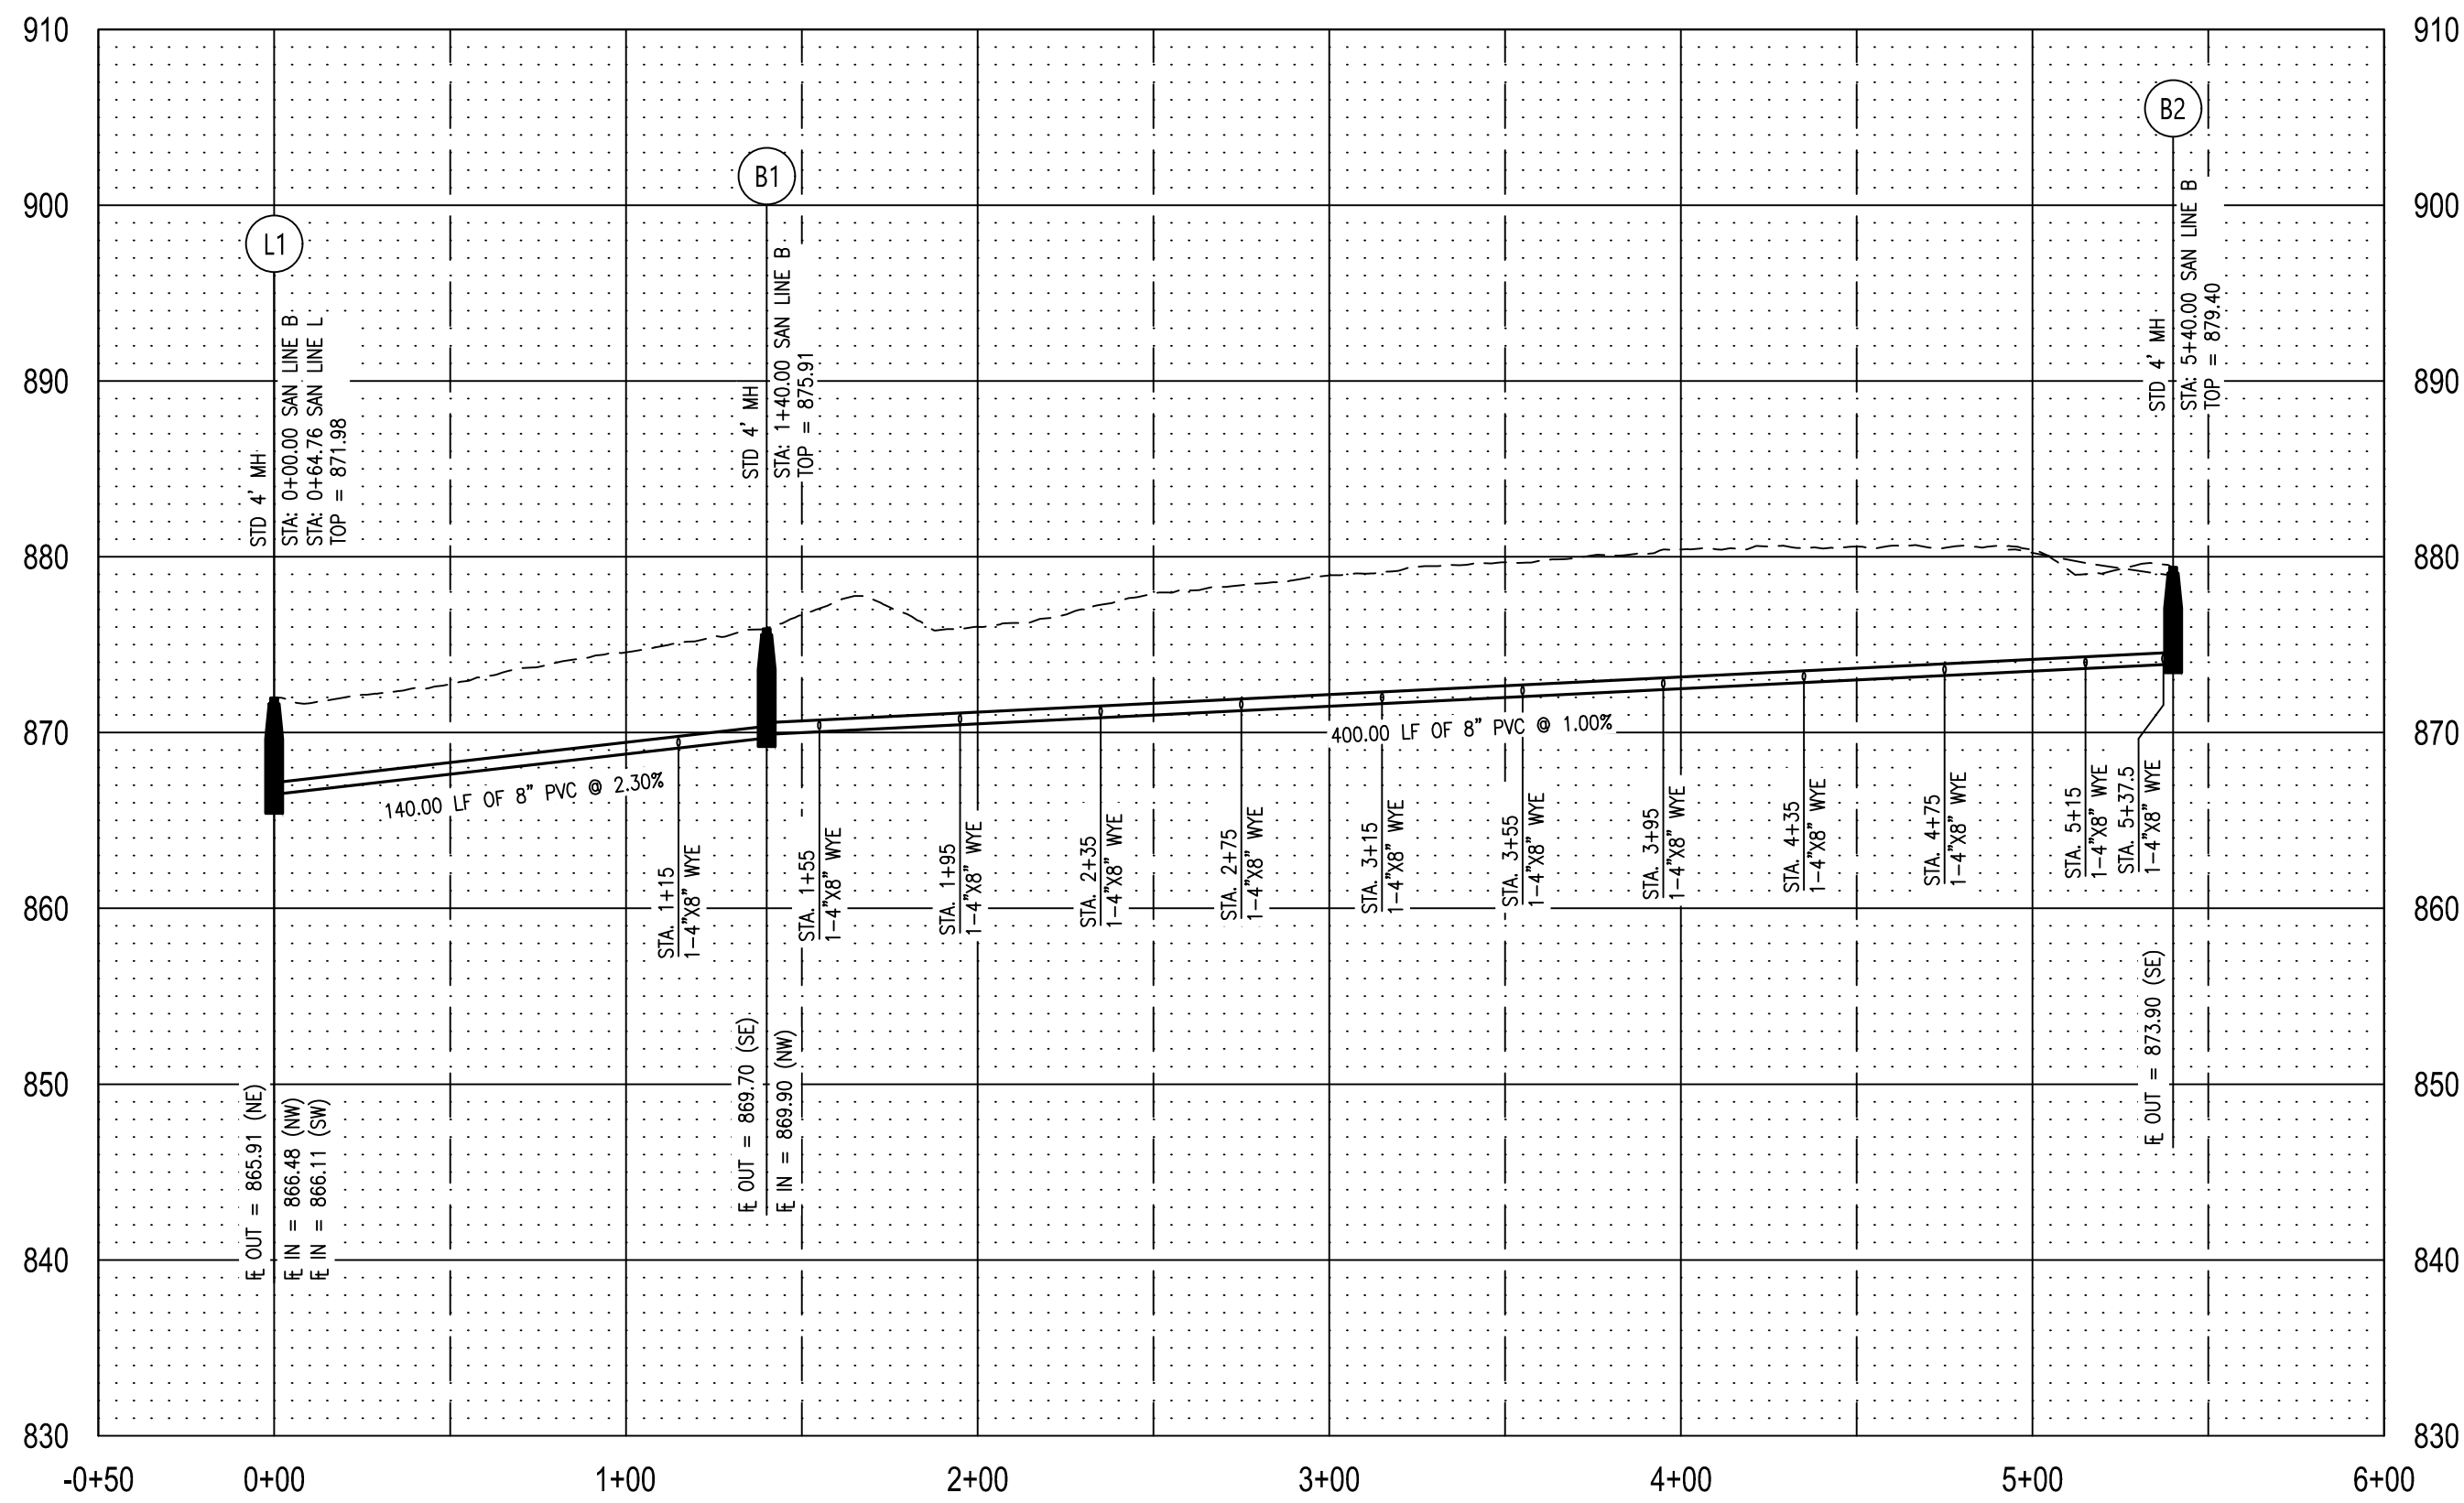


SAN LINE B (BASE BID)

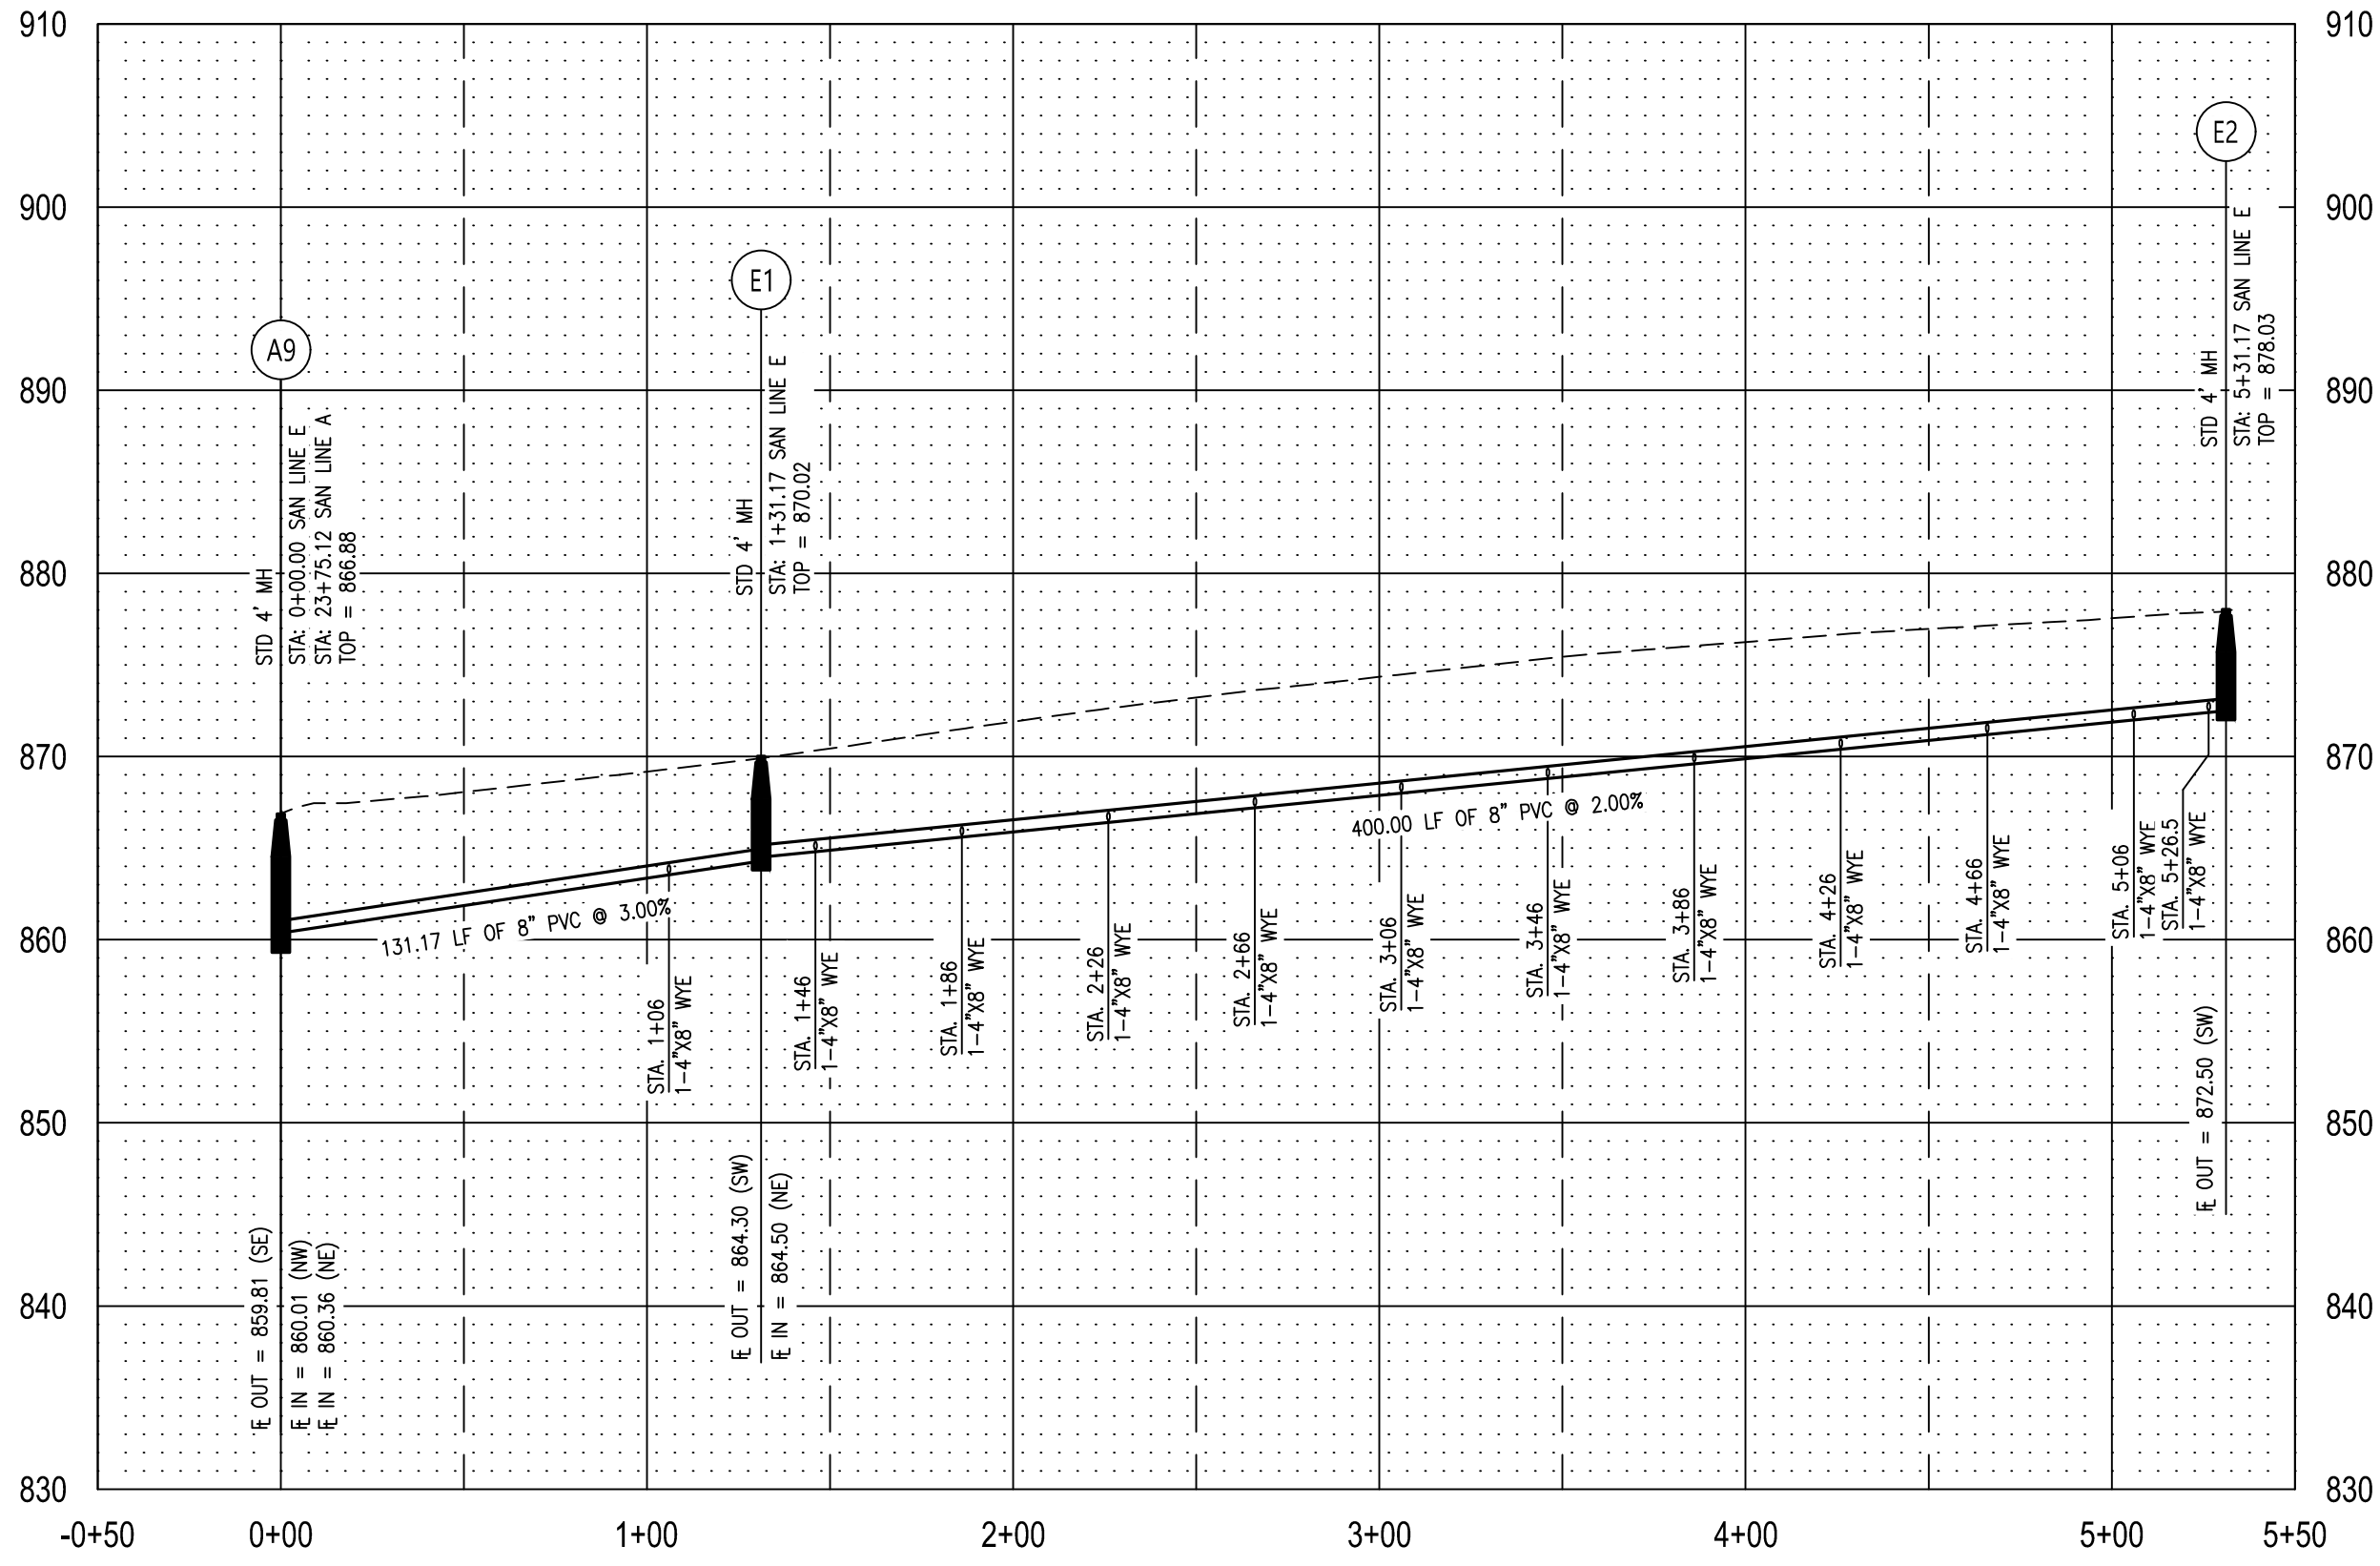

SAN LINE E (ALTERNATE #2)

STATE OF MISSOURI
MIKE KEHOE,
GOVERNOR

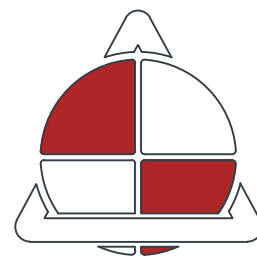

ALLSTATE
CONSULTANTS
allstateconsultants.net

3312 LEMONE INDUSTRIAL BLVD.
COLUMBIA, MO 65201
(573) 875-8799

P.O. BOX 156, 30601 HIGHWAY 5
MARCELINE, MO 64658
(660) 376-2941

410 SE THIRD ST., SUITE 103C
LEE'S SUMMIT, MO 64063
(816) 895-2310

MISSOURI STATE CERTIFICATE
OF AUTHORITY #2007004004
REUSE OF THIS DRAWING IN ANY MANNER IS
STRICTLY PROHIBITED WITHOUT THE WRITTEN
APPROVAL OF
ALLSTATE CONSULTANTS LLC

OFFICE OF ADMINISTRATION
DIVISION OF FACILITIES
MANAGEMENT,
DESIGN AND CONSTRUCTION

MISSOURI
STATE FAIRGROUNDS

NEW CAMPGROUND
CONSTRUCTION PLANS

MISSOURI
STATE FAIRGROUNDS
2503 W 16th STREET
SEDALIA, MO

PROJECT # F2307-01
SITE # 1501
ASSET # 3511501153

REVISION: _____
DATE: _____
REVISION: _____
DATE: _____
REVISION: _____
DATE: _____
ISSUE DATE: 11/11/2025






CAD DWG FILE: 23117.02-SHEETSBASE
DRAWN BY: DEP
CHECKED BY: CWS
DESIGNED BY: BPH

SHEET TITLE:
SANITARY SEWER



SHEET NUMBER:

C-206

17 OF 43
11/11/2025

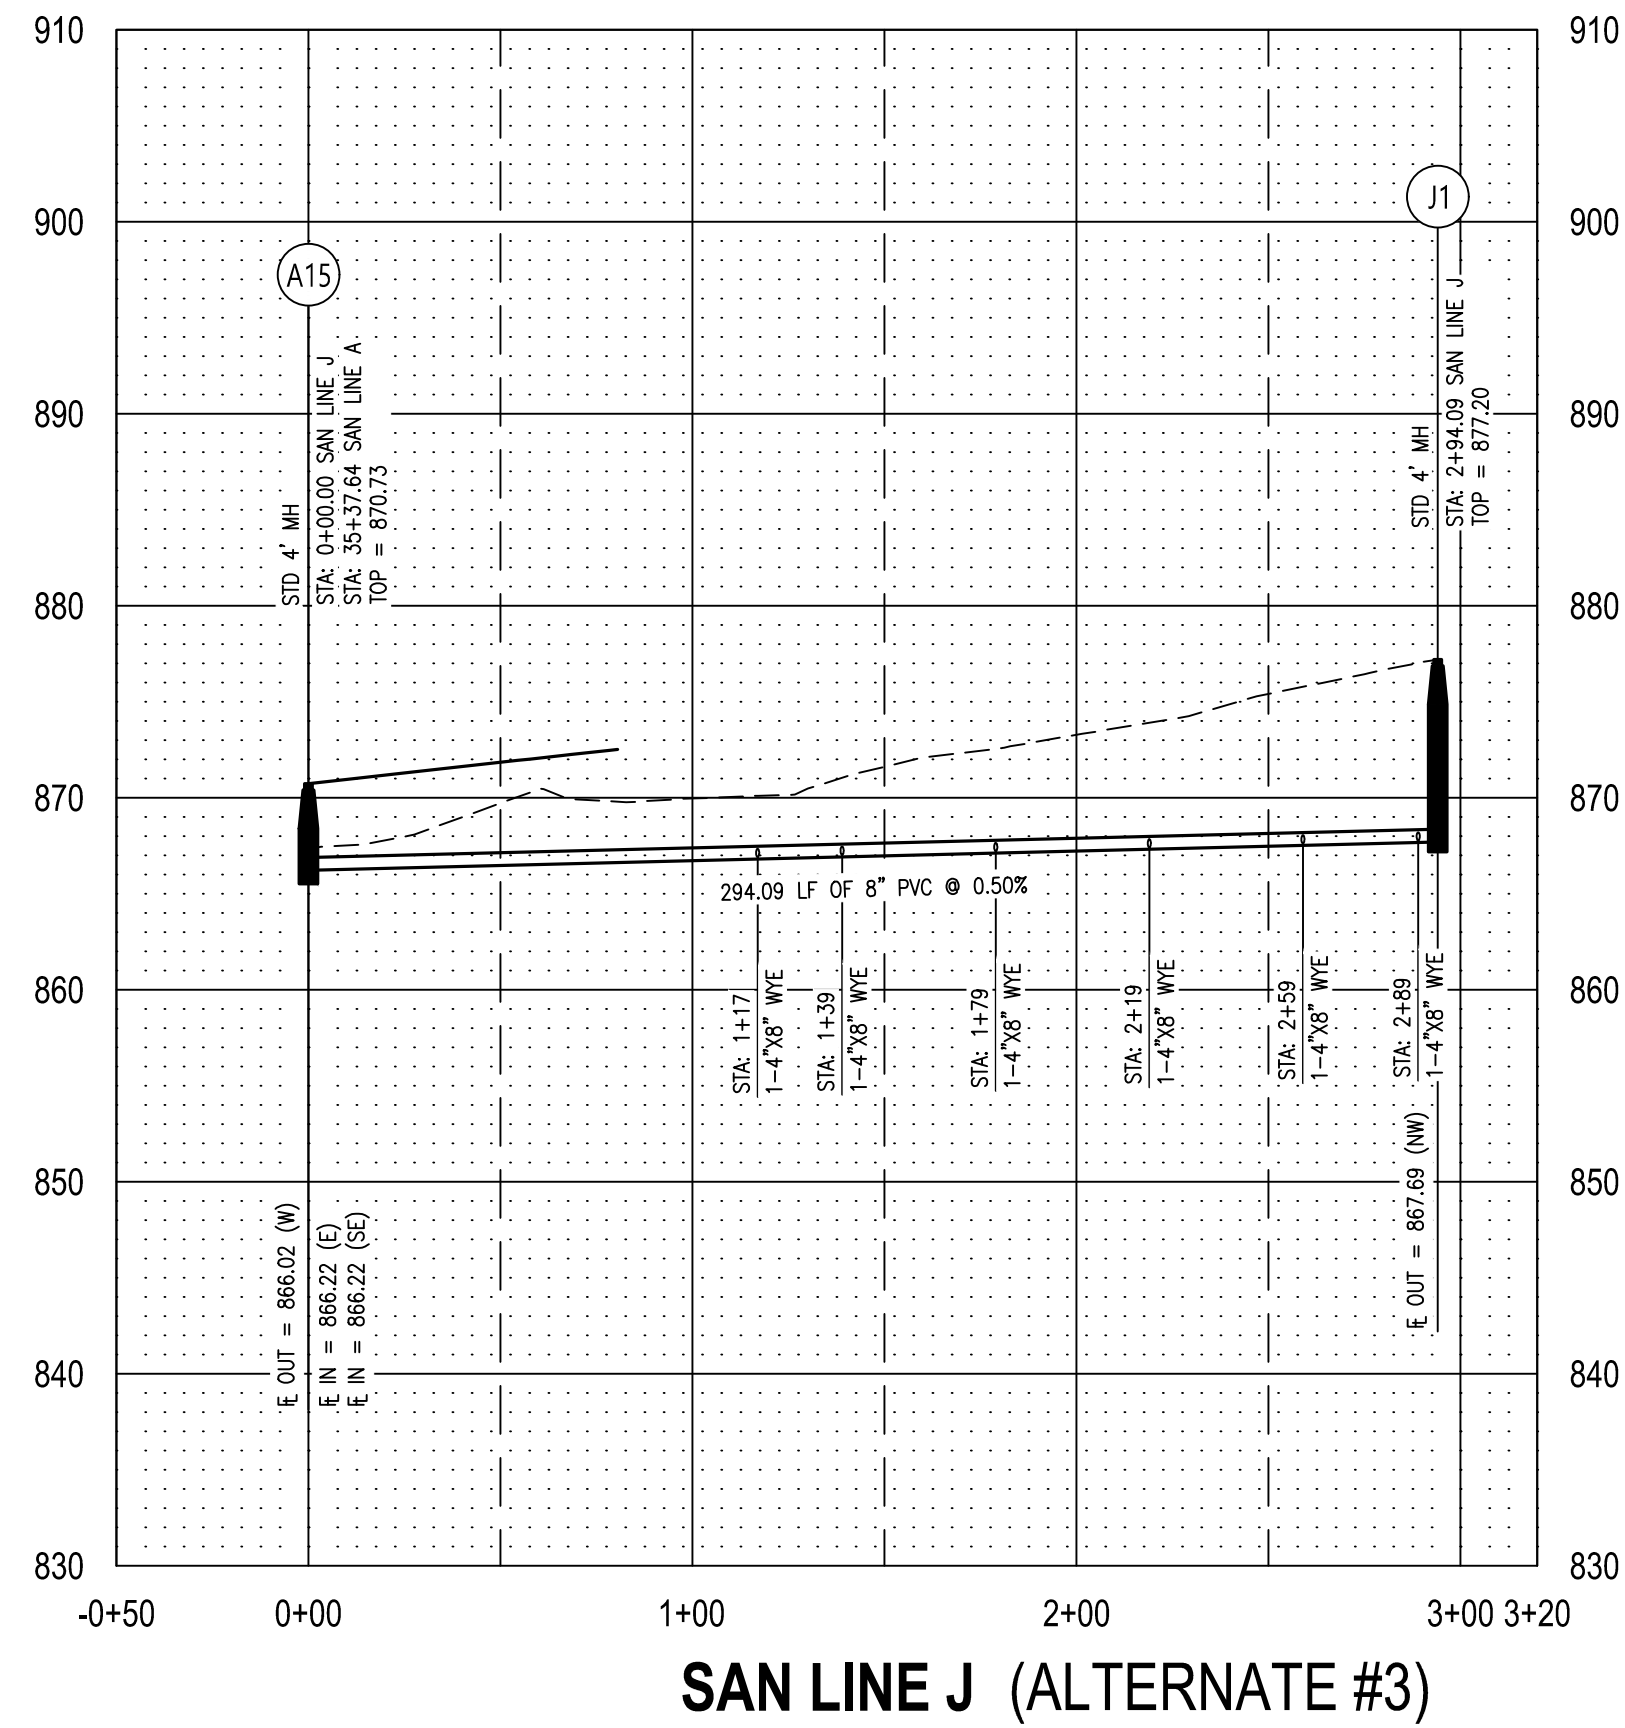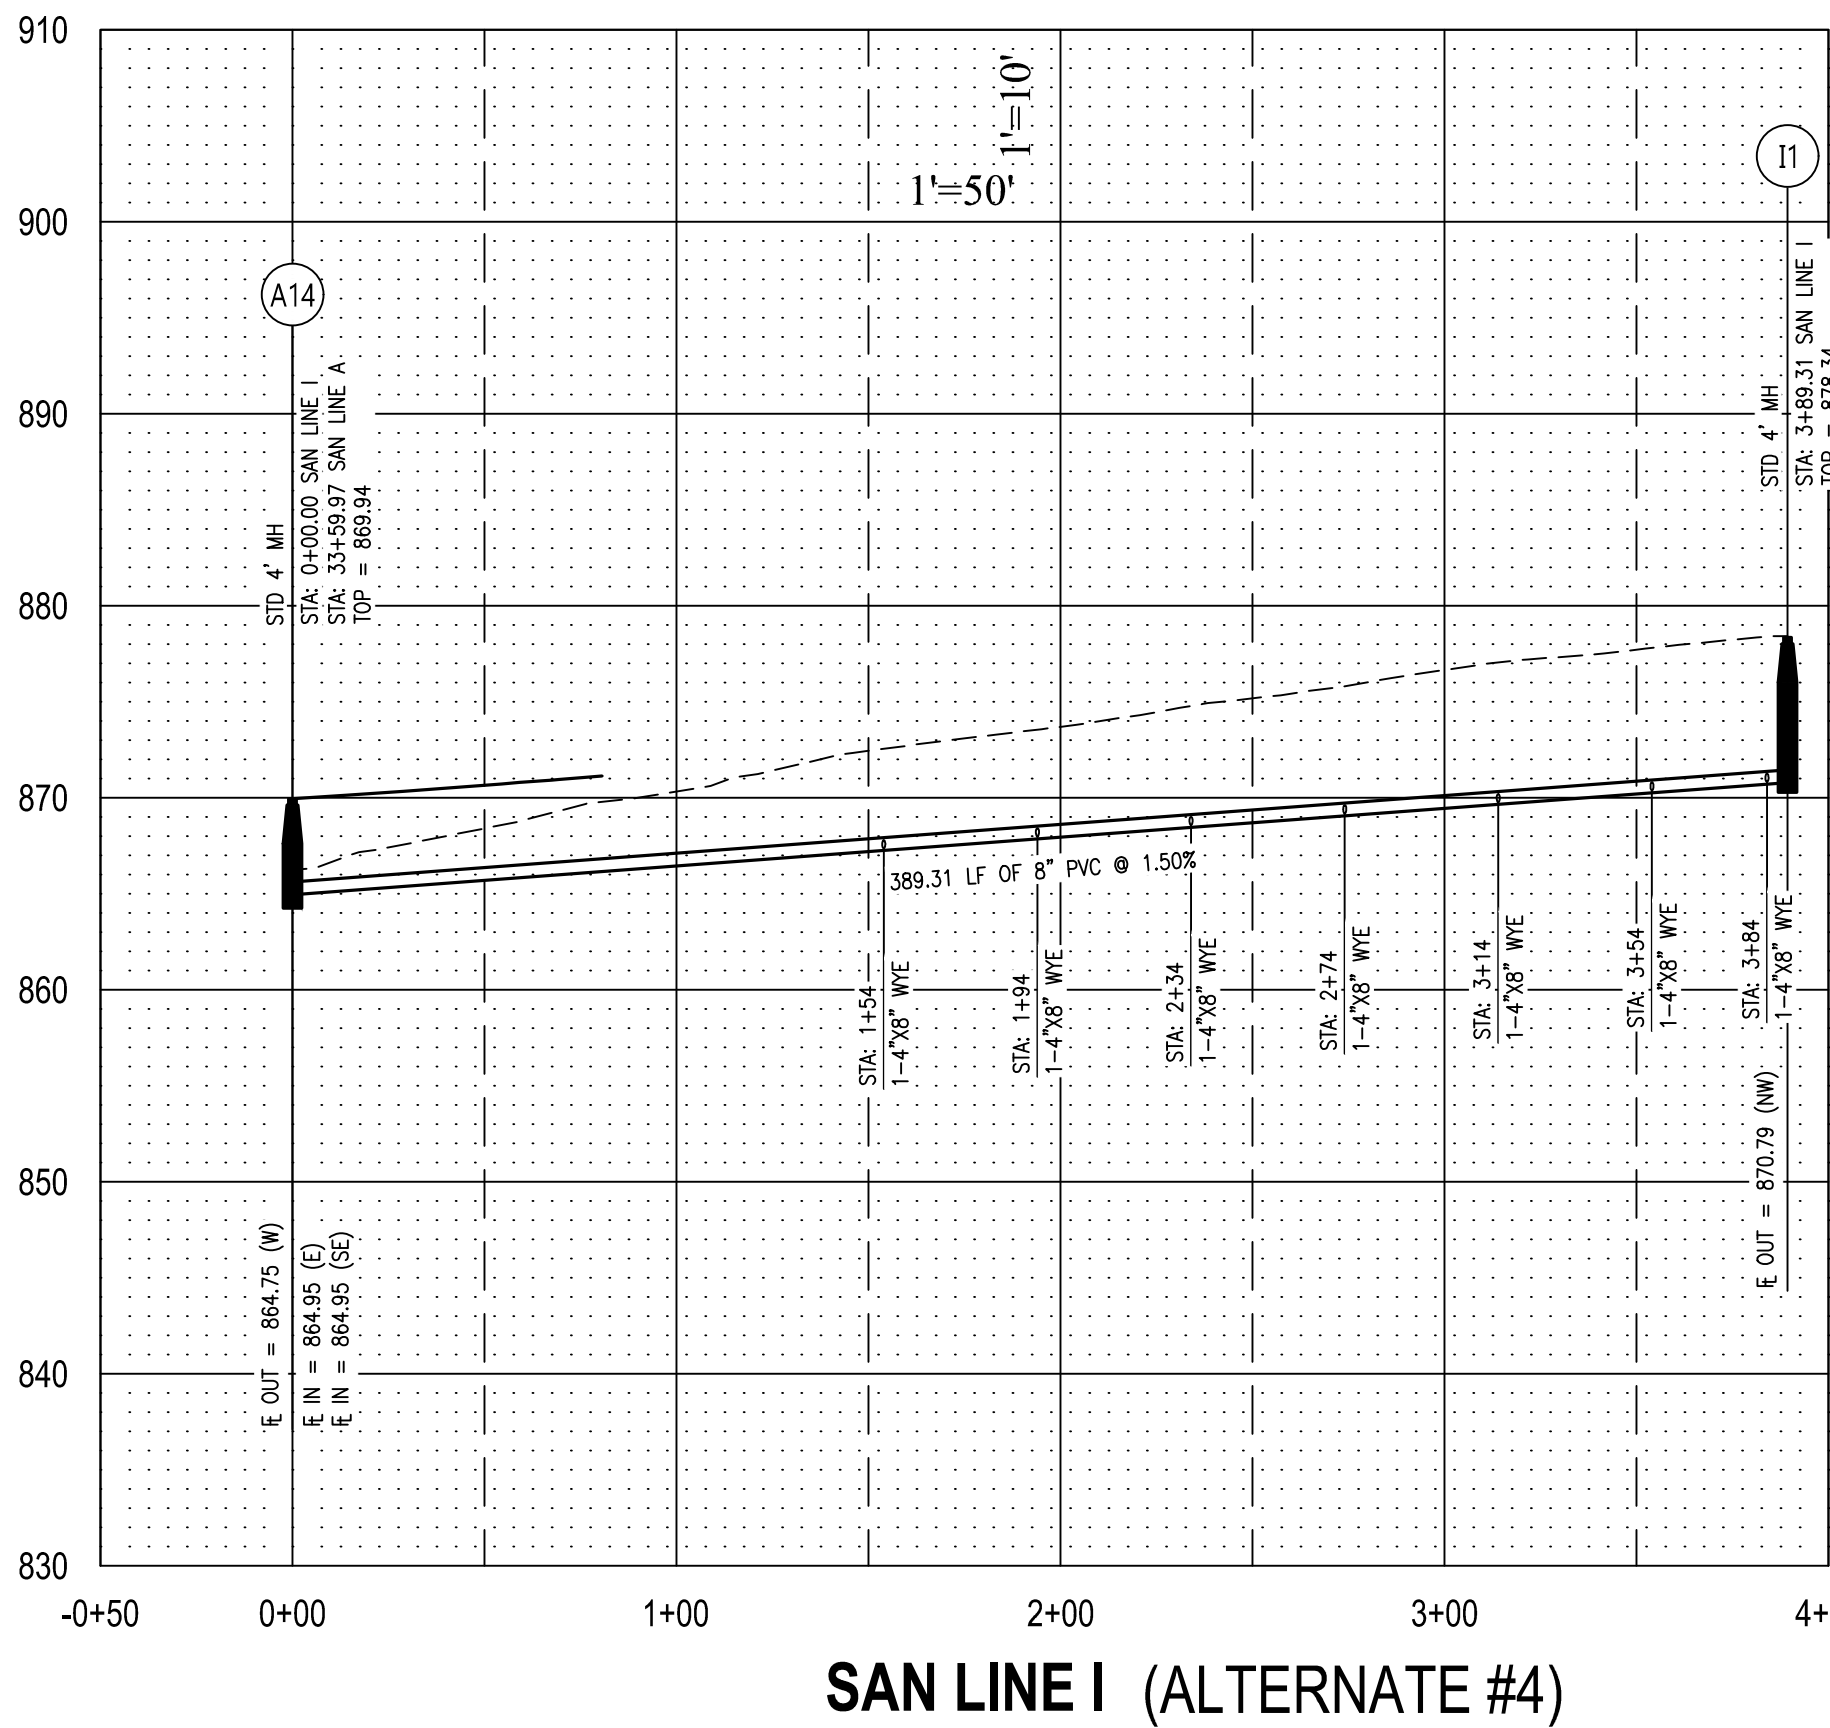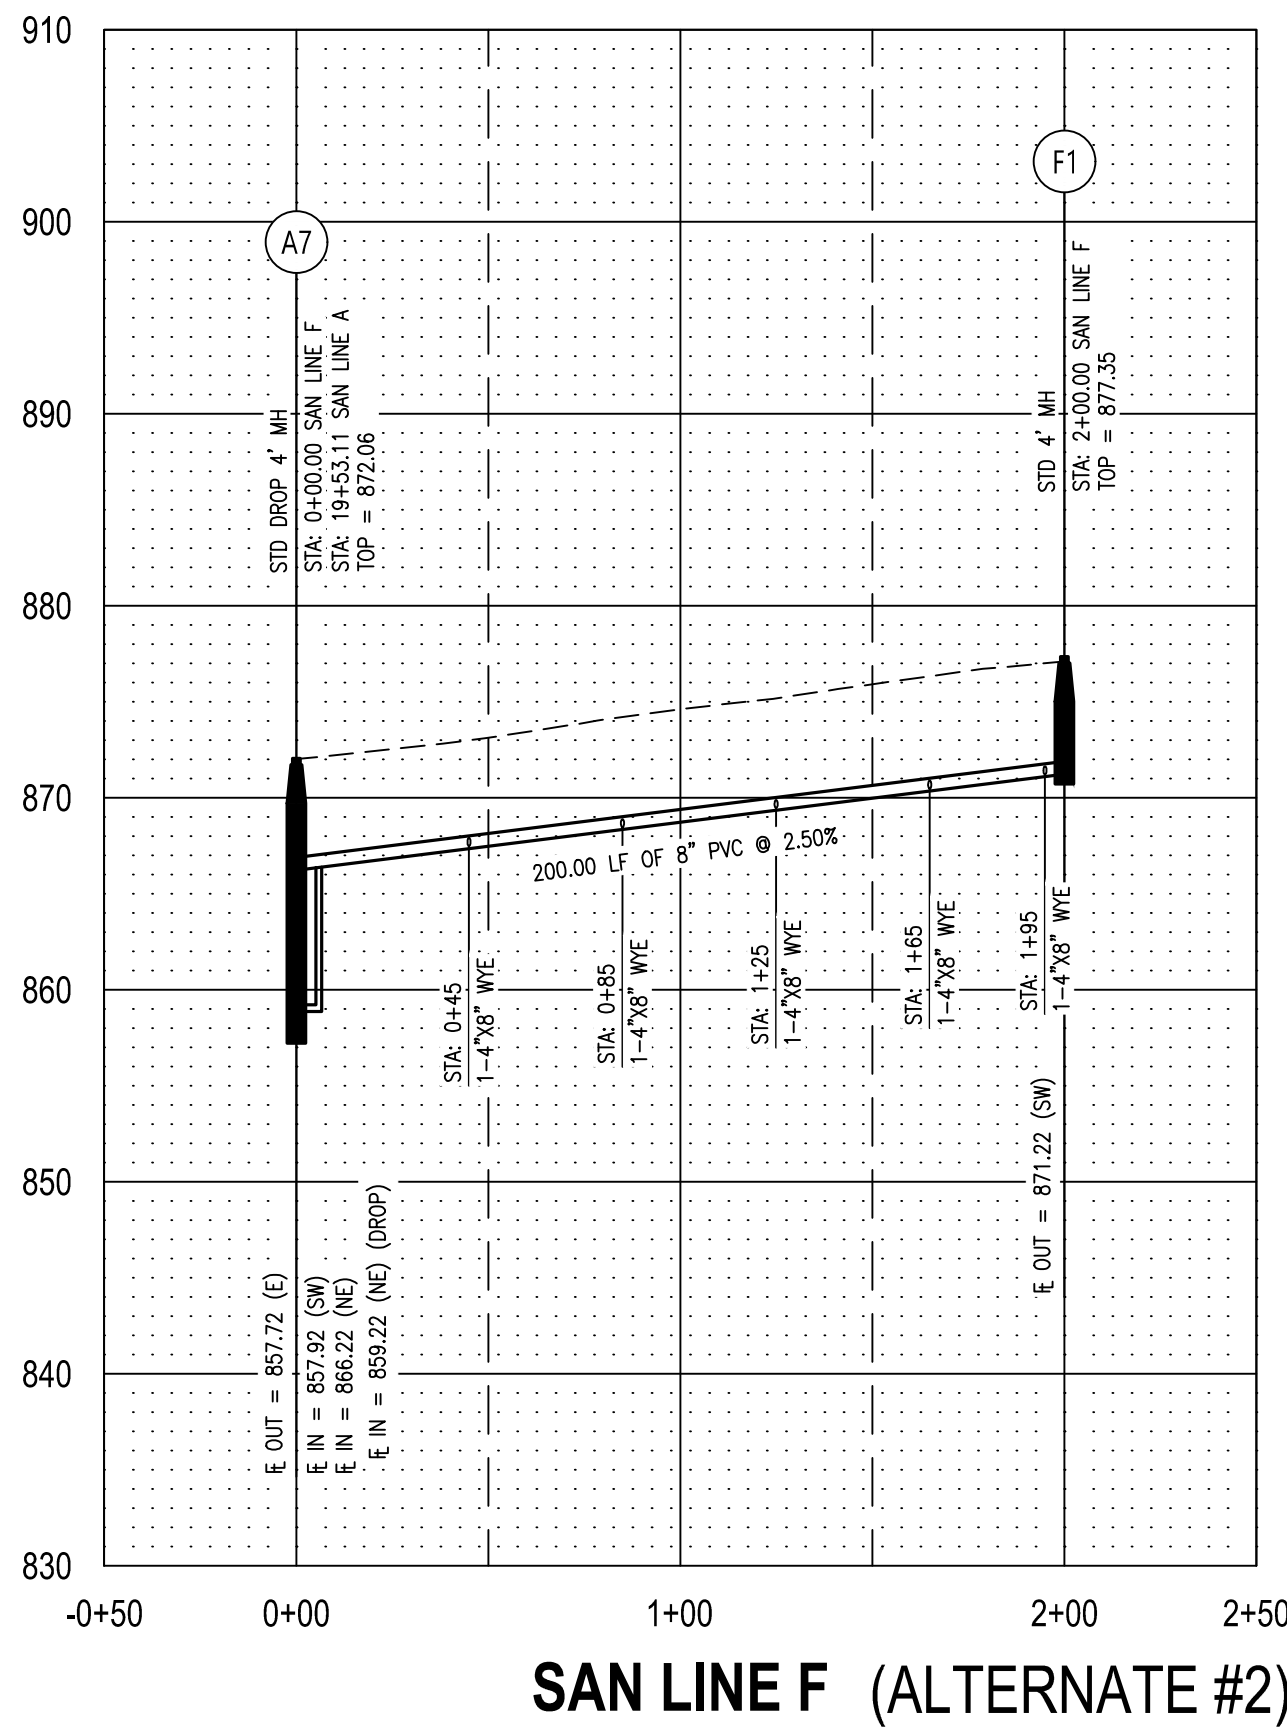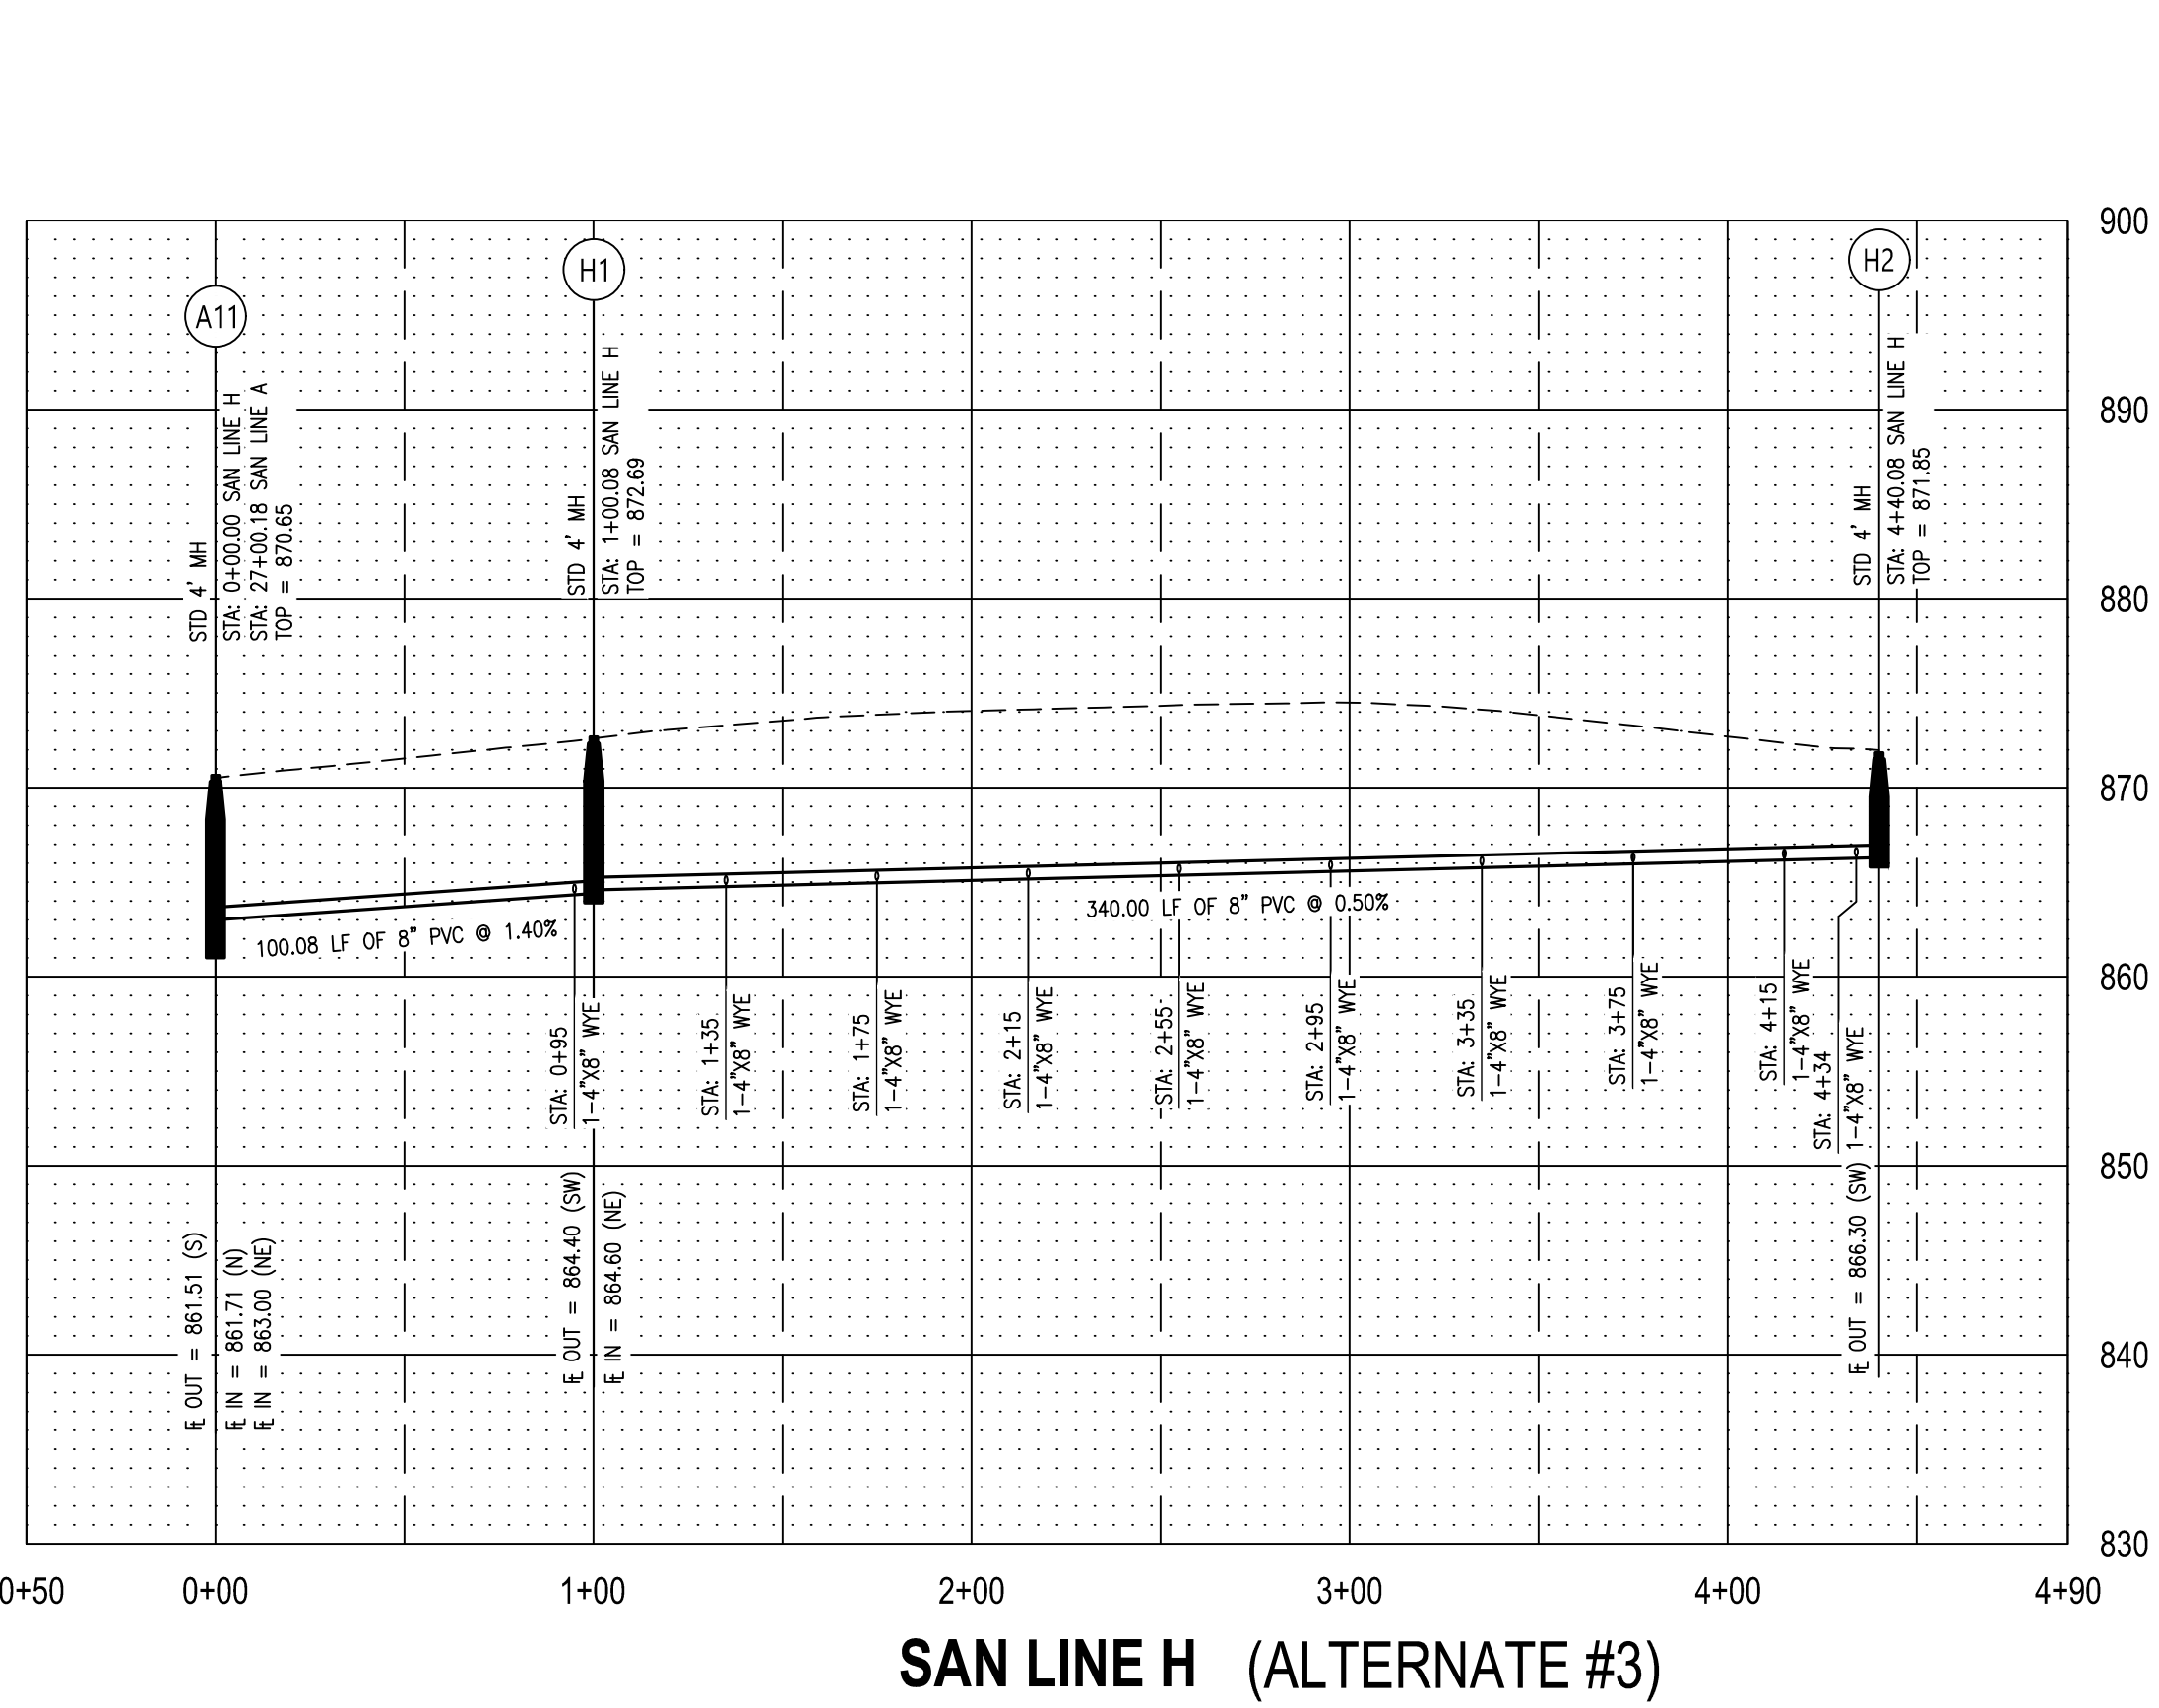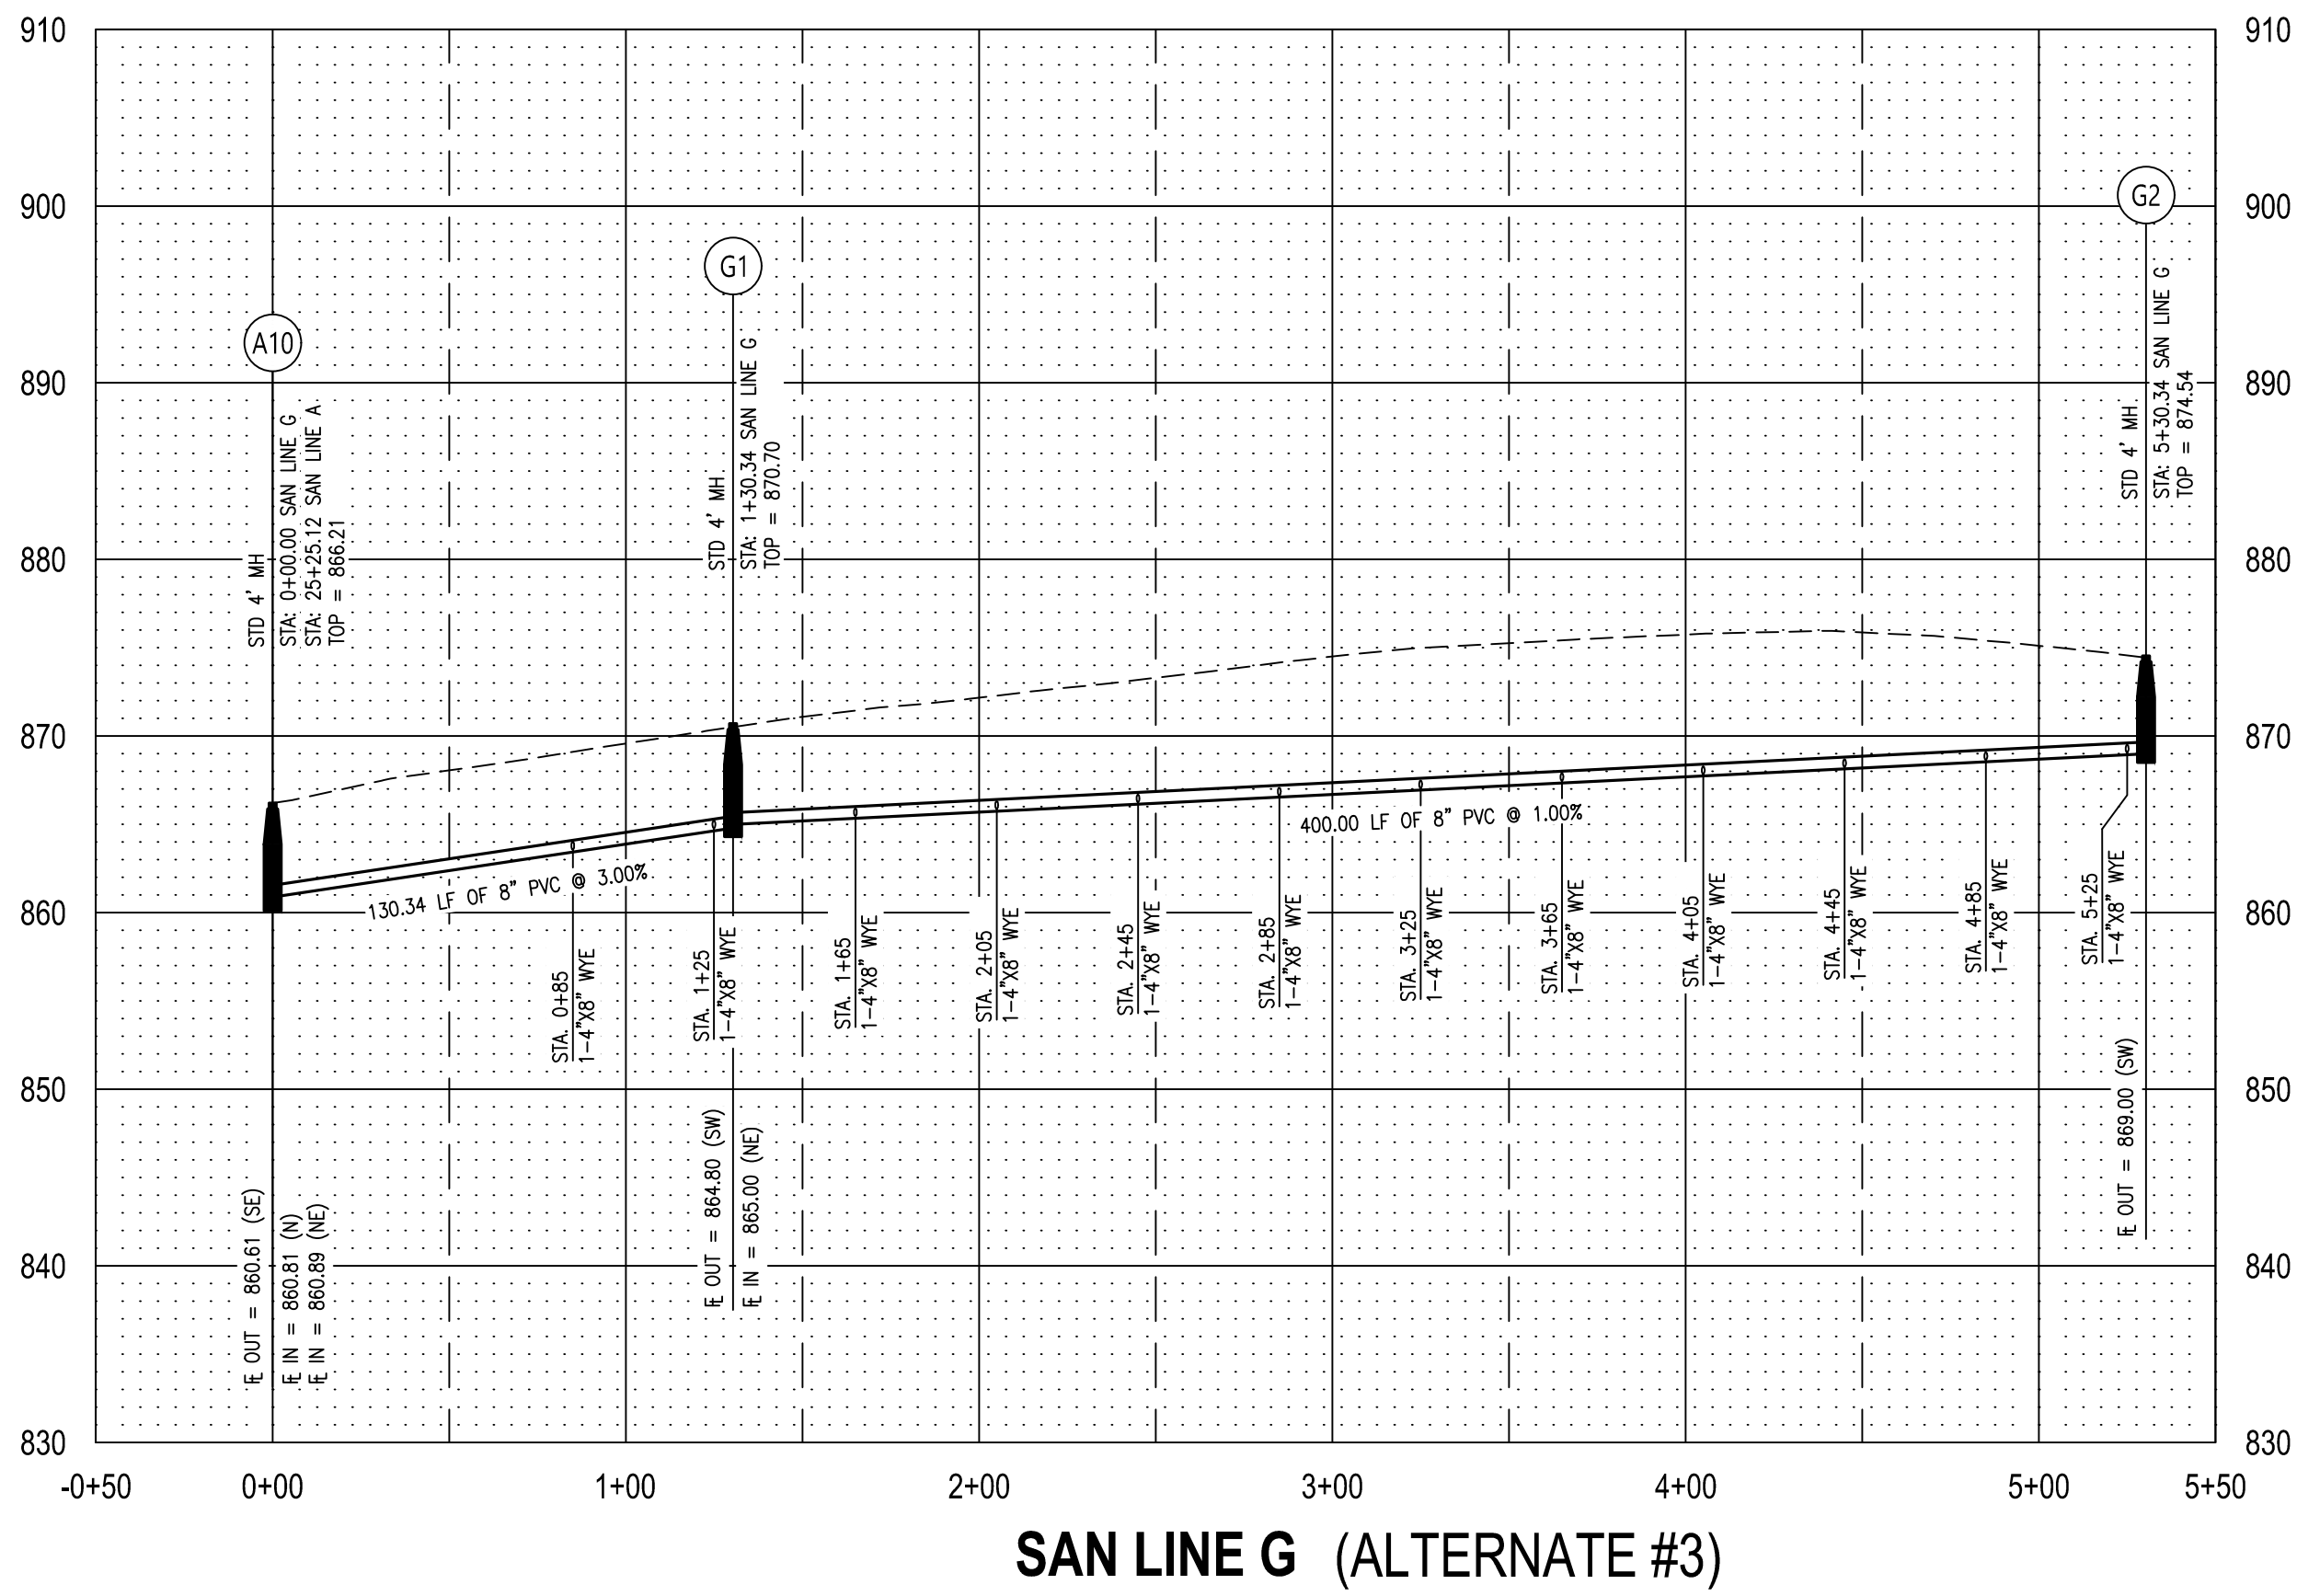

STATE OF MISSOURI
MIKE KEHOE,
GOVERNOR

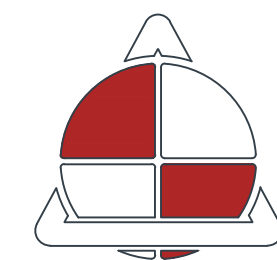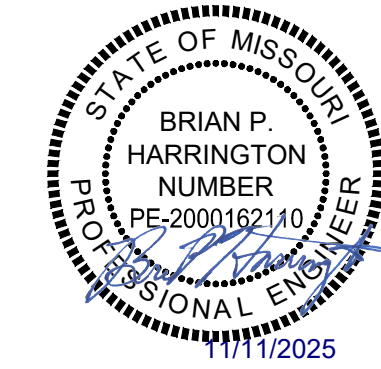

ALLSTATE
CONSULTANTS
allstateconsultants.net
3312 LEMONE INDUSTRIAL BLVD.
COLUMBIA, MO 65201
(573) 875-8799
P.O. BOX 156, 30601 HIGHWAY 5
MARCELINE, MO 64658
(660) 376-2941
410 SE THIRD ST., SUITE 103C
LEE'S SUMMIT, MO 64063
(816) 895-2310

MISSOURI STATE CERTIFICATE
OF AUTHORITY #2007004004
REUSE OF THIS DRAWING IN ANY MANNER IS
STRICTLY PROHIBITED WITHOUT THE WRITTEN
APPROVAL OF
ALLSTATE CONSULTANTS LLC

OFFICE OF ADMINISTRATION
DIVISION OF FACILITIES
MANAGEMENT,
DESIGN AND CONSTRUCTION

MISSOURI
STATE FAIRGROUNDS

NEW CAMPGROUND
CONSTRUCTION PLANS

MISSOURI
STATE FAIRGROUNDS
2503 W 16th STREET
SEDALIA, MO

PROJECT # F2307-01
SITE # 1501
ASSET # 3511501153

REVISION: _____
DATE: _____
REVISION: _____
DATE: _____
REVISION: _____
DATE: _____
ISSUE DATE: 11/11/2025




CAD DWG FILE: 23117.02-SHEETSBASE
DRAWN BY: DEP
CHECKED BY: CWS
DESIGNED BY: BPH

SHEET TITLE:
SANITARY SEWER



SHEET NUMBER:

C-207

18 OF 43
11/11/2025

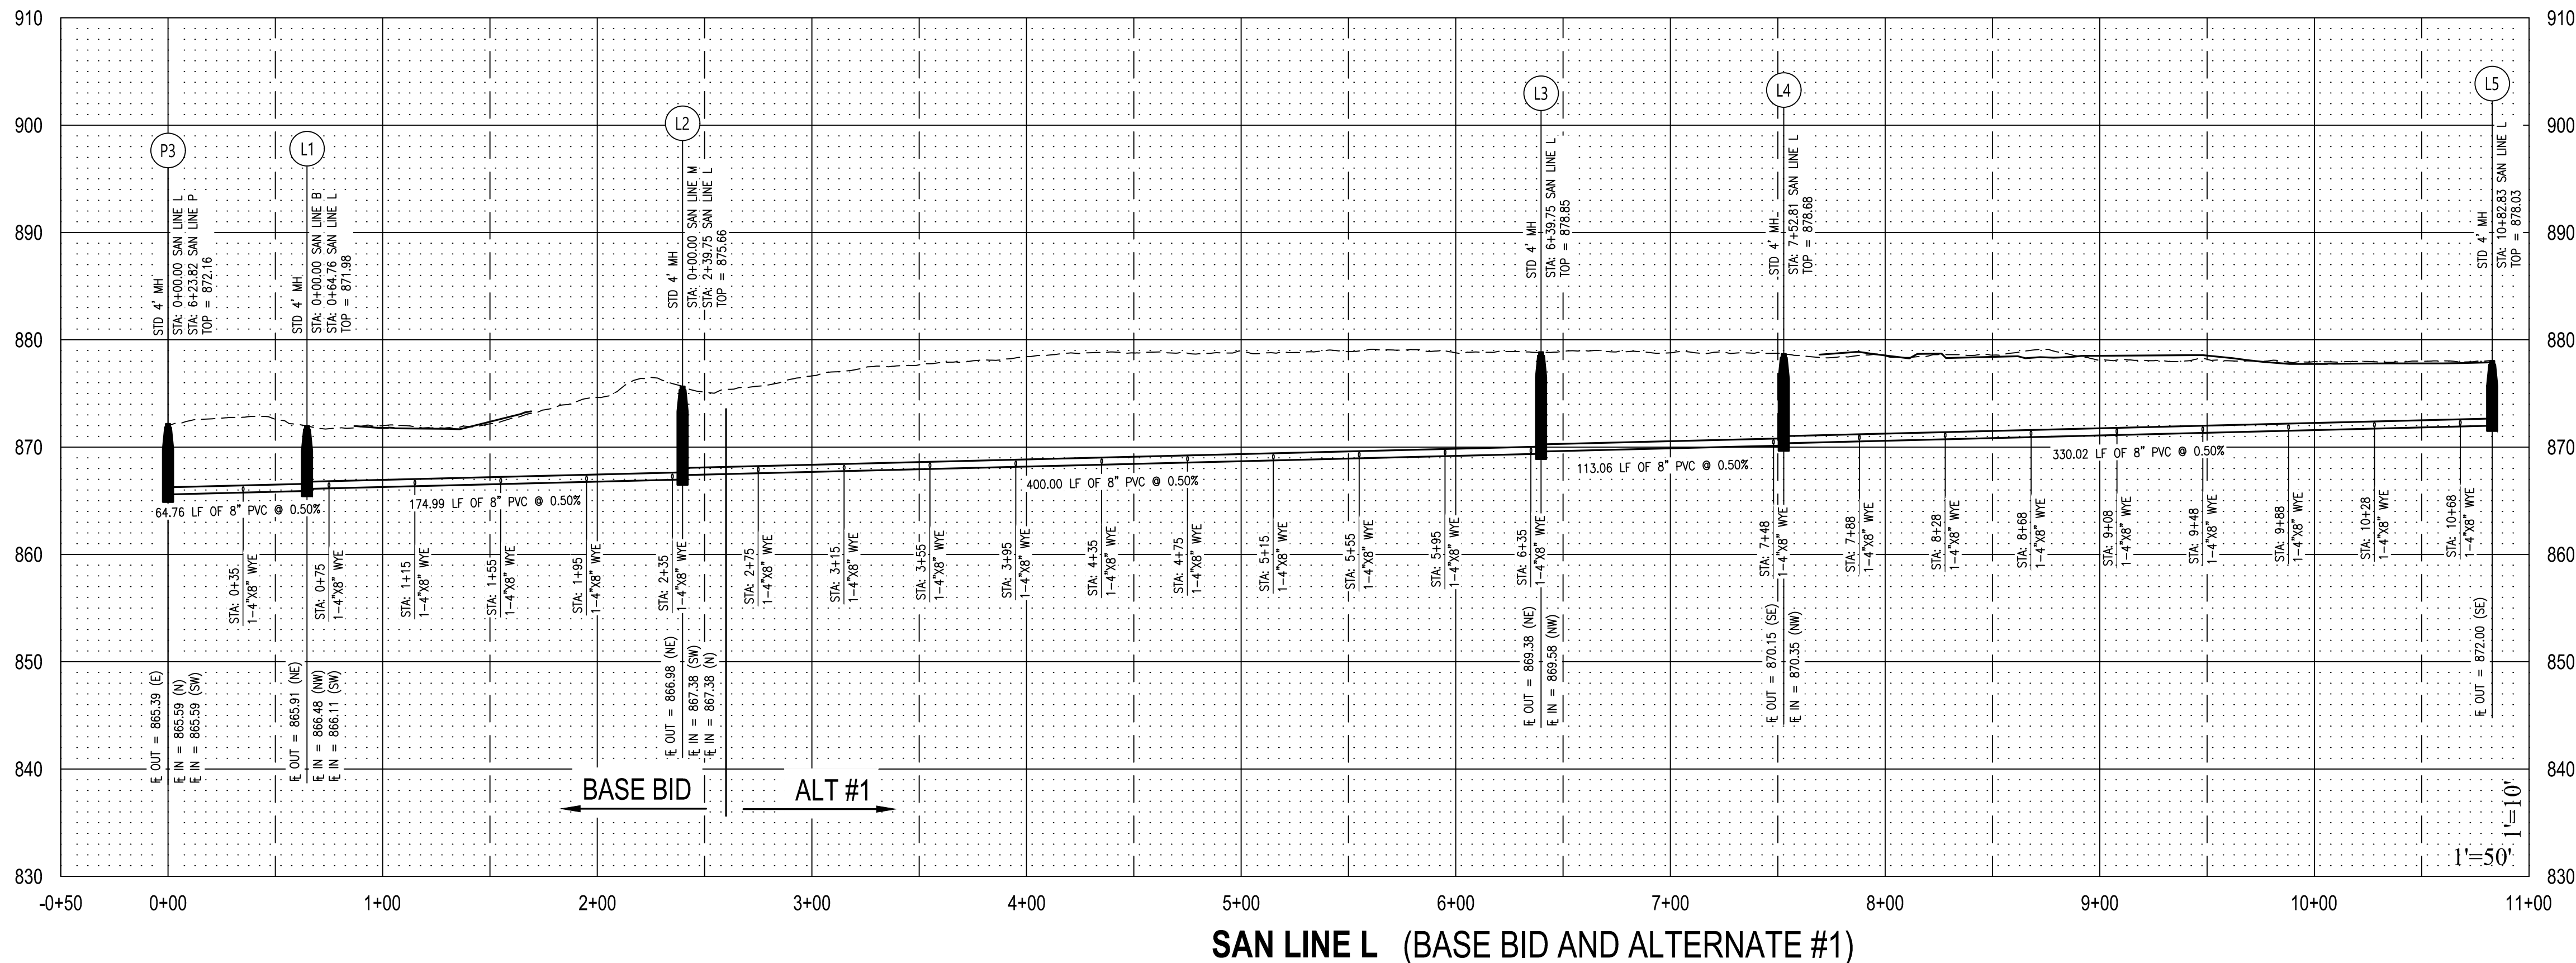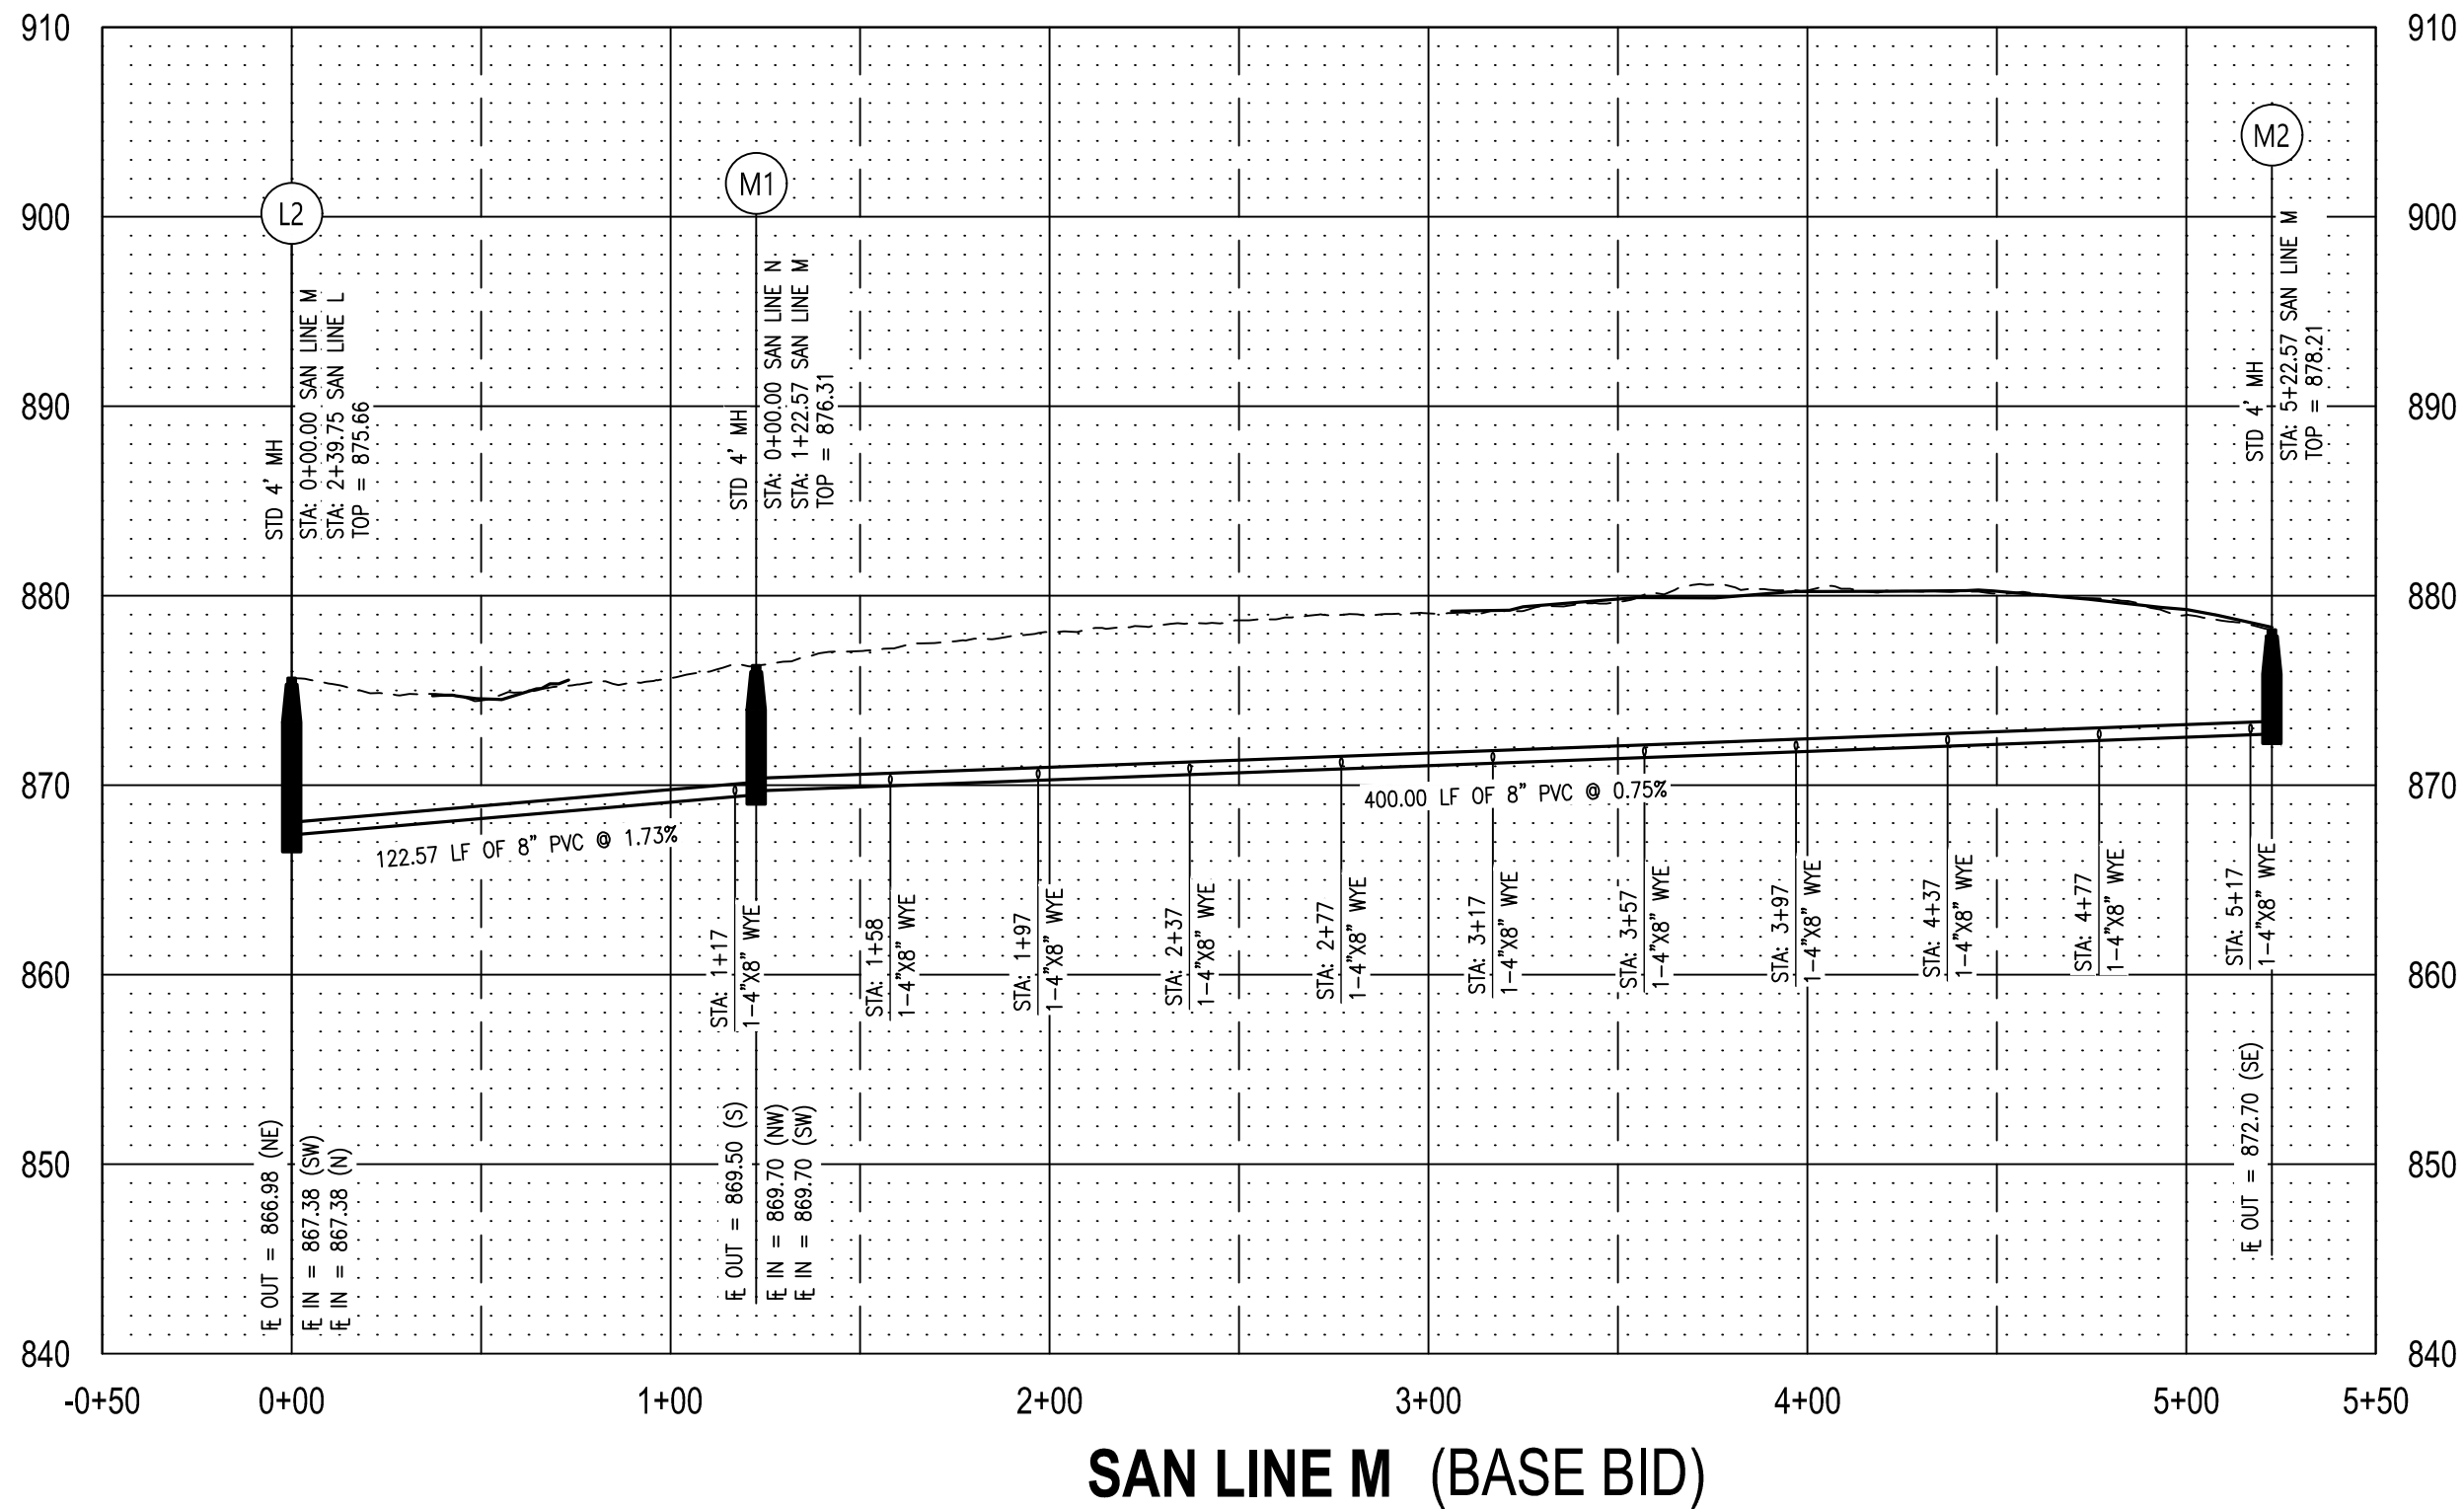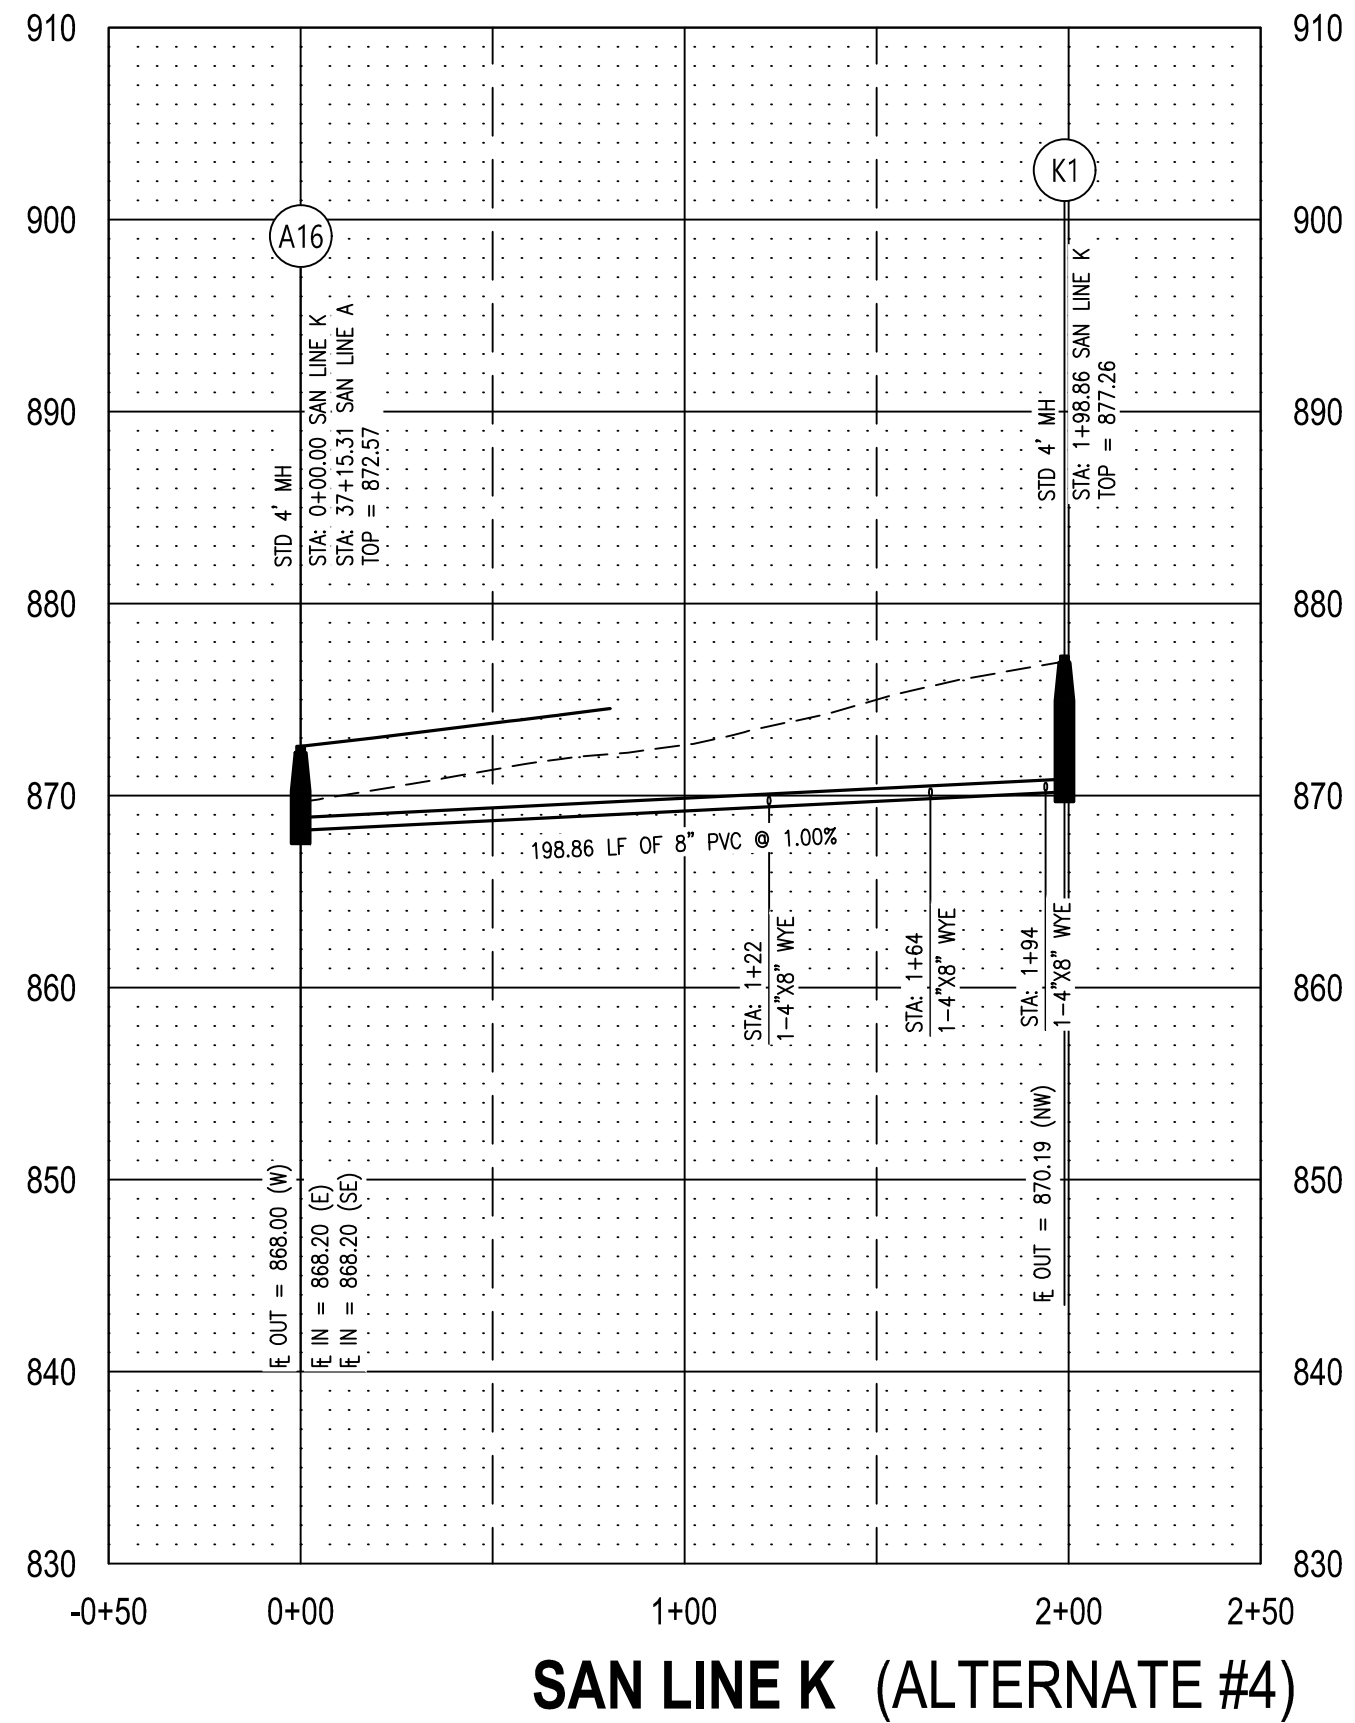

STATE OF MISSOURI
MIKE KEHOE,
GOVERNOR

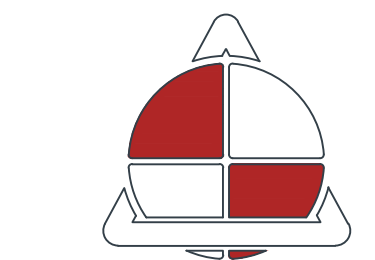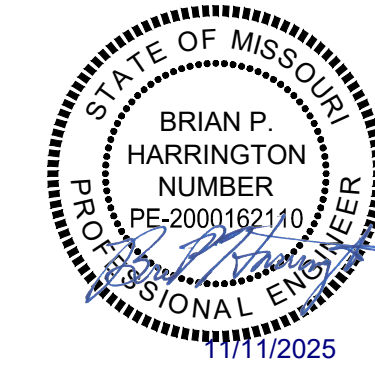

ALLSTATE
CONSULTANTS
allstateconsultants.net
3312 LEMONE INDUSTRIAL BLVD.
COLUMBIA, MO 65201
(573) 875-8799
P.O. BOX 156, 30601 HIGHWAY 5
MARCELINE, MO 64658
(660) 376-2941
410 SE THIRD ST., SUITE 103C
LEE'S SUMMIT, MO 64063
(816) 895-2310

MISSOURI STATE CERTIFICATE
OF AUTHORITY #2007004004
REUSE OF THIS DRAWING IN ANY MANNER IS
STRICTLY PROHIBITED WITHOUT THE WRITTEN
APPROVAL OF
ALLSTATE CONSULTANTS LLC

OFFICE OF ADMINISTRATION
DIVISION OF FACILITIES
MANAGEMENT,
DESIGN AND CONSTRUCTION

MISSOURI
STATE FAIRGROUNDS

NEW CAMPGROUND
CONSTRUCTION PLANS

MISSOURI
STATE FAIRGROUNDS
2503 W 16th STREET
SEDALIA, MO

PROJECT # F2307-01
SITE # 1501
ASSET # 3511501153


REVISION: _____
DATE: _____
REVISION: _____
DATE: _____
REVISION: _____
DATE: _____
ISSUE DATE: 11/11/2025

CAD DWG FILE: 23117.02-SHEETSBASE
DRAWN BY: DEP
CHECKED BY: CWS
DESIGNED BY: BPH

SHEET TITLE:
SANITARY SEWER

SHEET NUMBER:
C-208
19 OF 43
11/11/2025

P:\2023\23117.02 - Campgrounds Expansion\DWG\DESIGN\23117.02-SHEETSBASE_SANITARY.dwg, C-208, 11/11/2025 12:38:53 PM

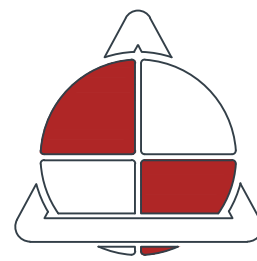

**ALLSTATE
CONSULTANTS**

allstateconsultants.net

3312 LEMONE INDUSTRIAL BLVD.
COLUMBIA, MO 65201
(573) 875-8799

P.O. BOX 156, 30601 HIGHWAY 5
MARCELINE, MO 64658
(660) 376-2941

410 SE THIRD ST., SUITE 103C
LEE'S SUMMIT, MO 64063
(816) 895-2310

MISSOURI STATE CERTIFICATE
OF AUTHORITY #2007004004
REUSE OF THIS DRAWING IN ANY MANNER IS
STRICTLY PROHIBITED WITHOUT THE WRITTEN
APPROVAL OF
ALLSTATE CONSULTANTS LLC

OFFICE OF ADMINISTRATION
DIVISION OF FACILITIES
MANAGEMENT,
DESIGN AND CONSTRUCTION

MISSOURI
STATE FAIRGROUNDS

NEW CAMPGROUND
CONSTRUCTION PLANS

MISSOURI
STATE FAIRGROUNDS
2503 W 16th STREET
SEDALIA, MO

PROJECT # F2307-01
SITE # 1501
ASSET # 3511501153

REVISION: _____
DATE: _____
REVISION: _____
DATE: _____
REVISION: _____
DATE: _____
ISSUE DATE: 11/11/2025

CAD DWG FILE: 23117.02-SHEETSBASE
DRAWN BY: DEP
CHECKED BY: CWS
DESIGNED BY: BPH




SHEET TITLE:

SANITARY SEWER

SHEET NUMBER:

C-209

20 OF 43
11/11/2025

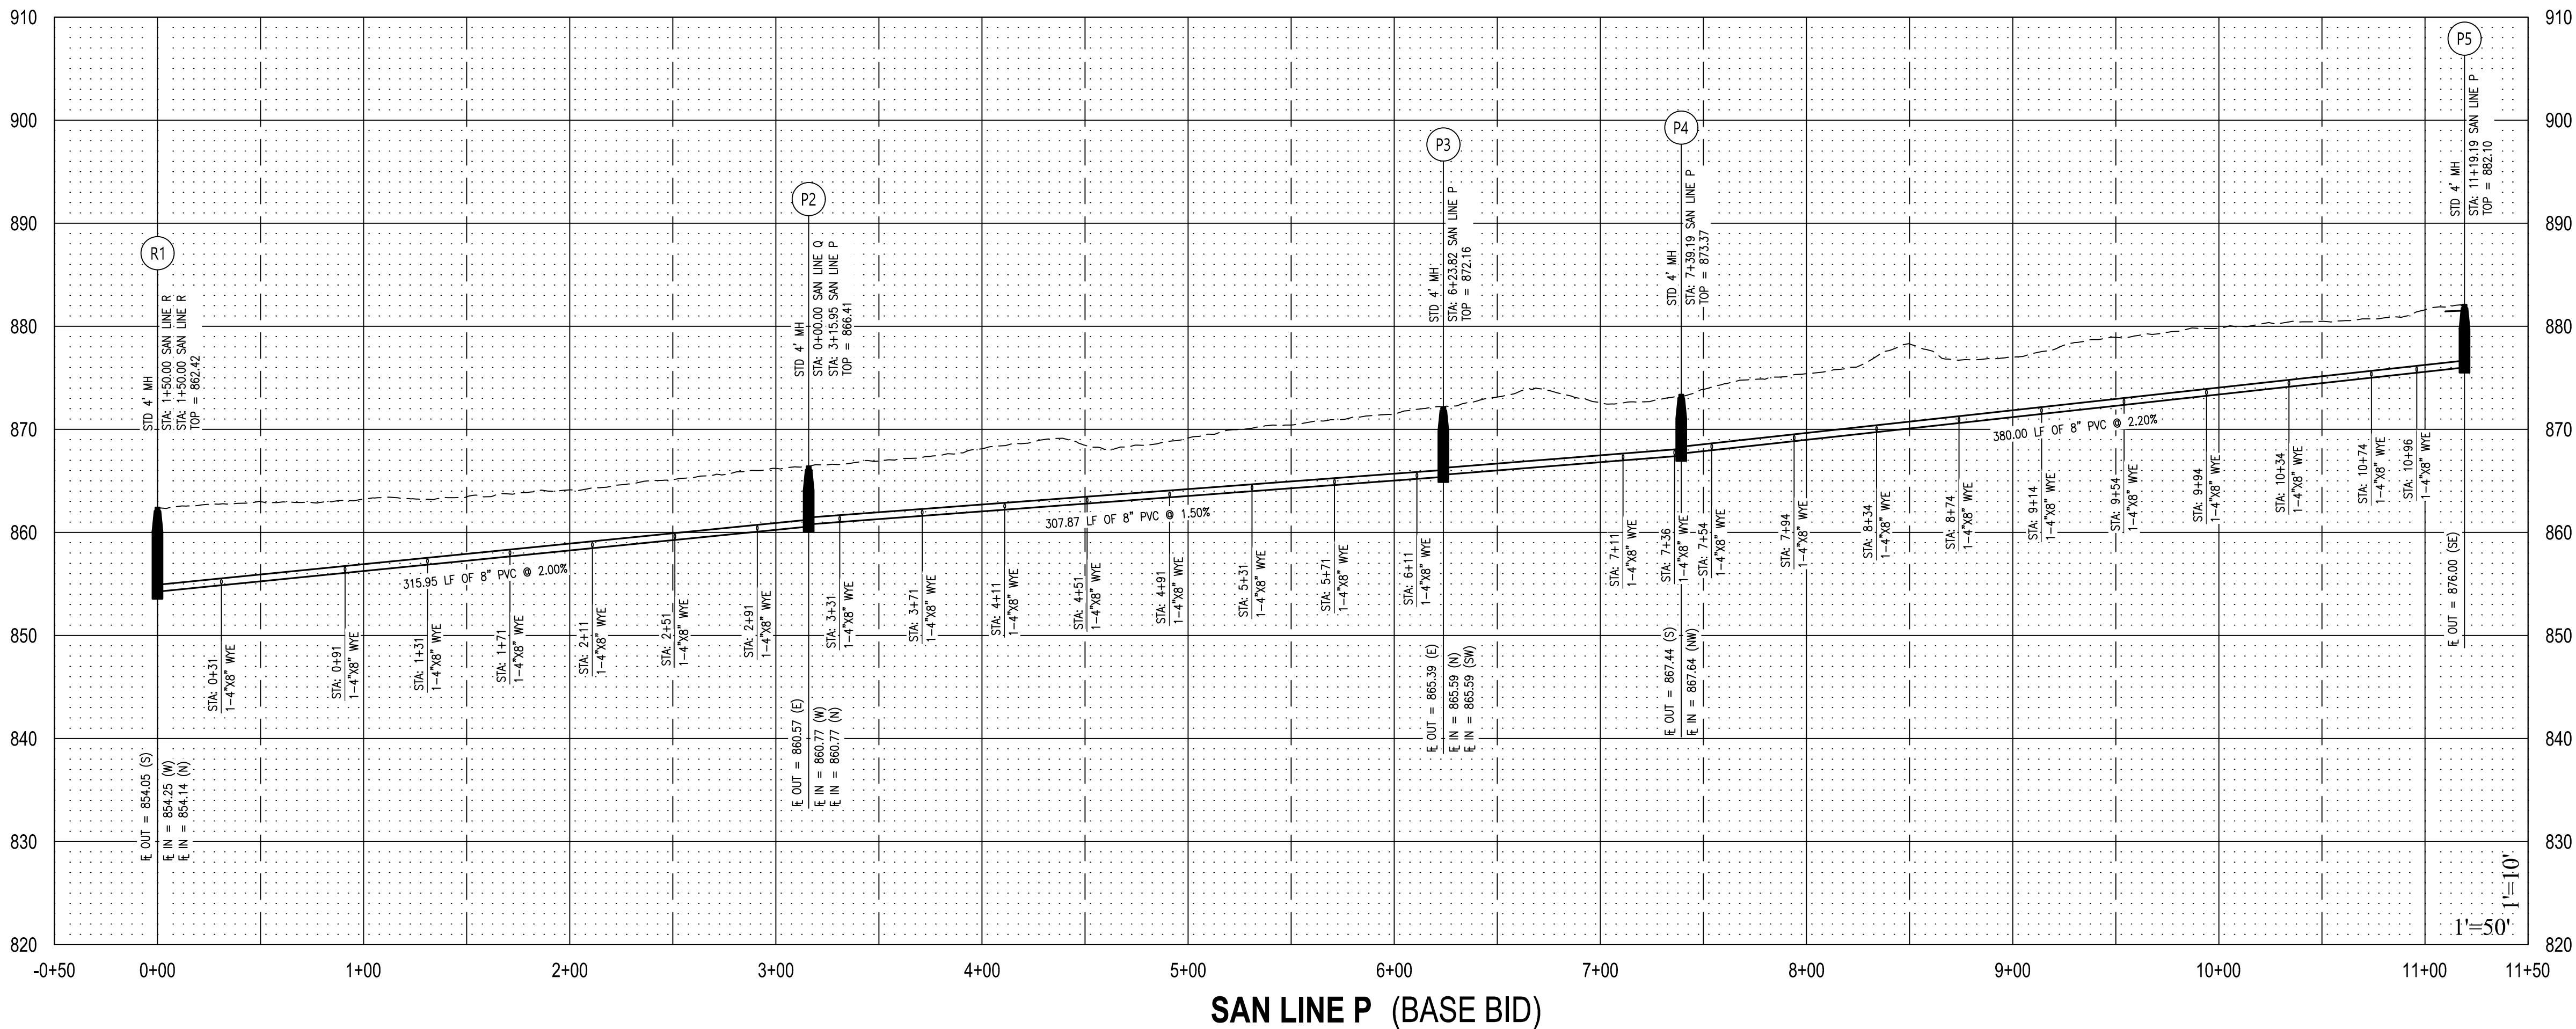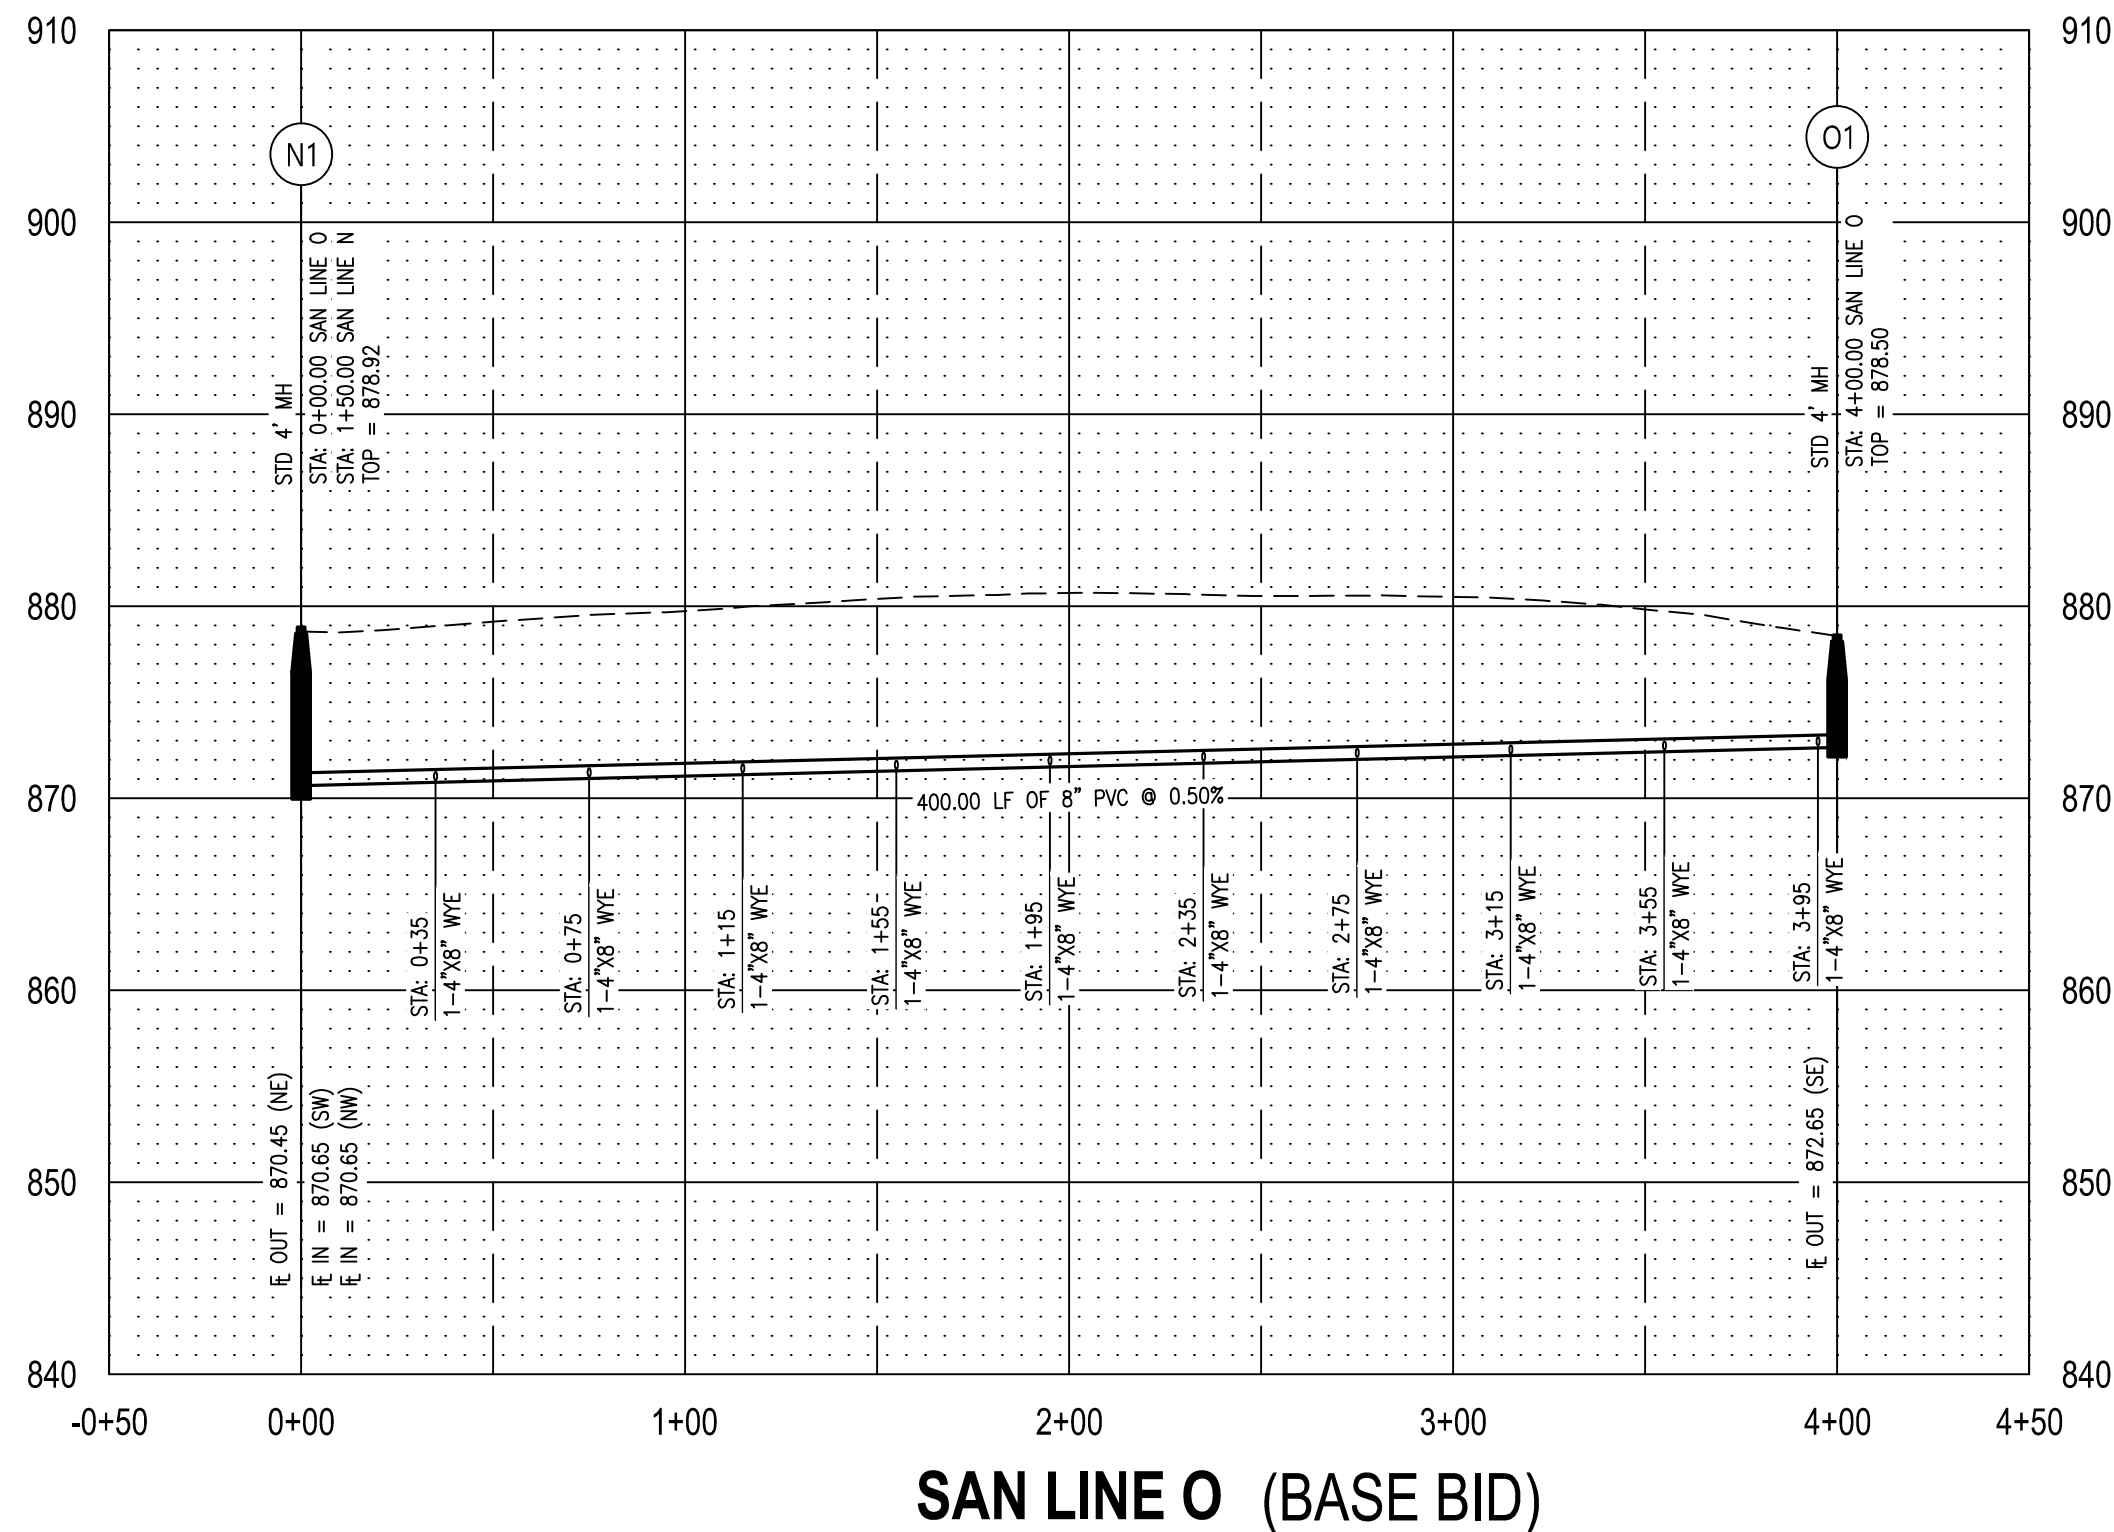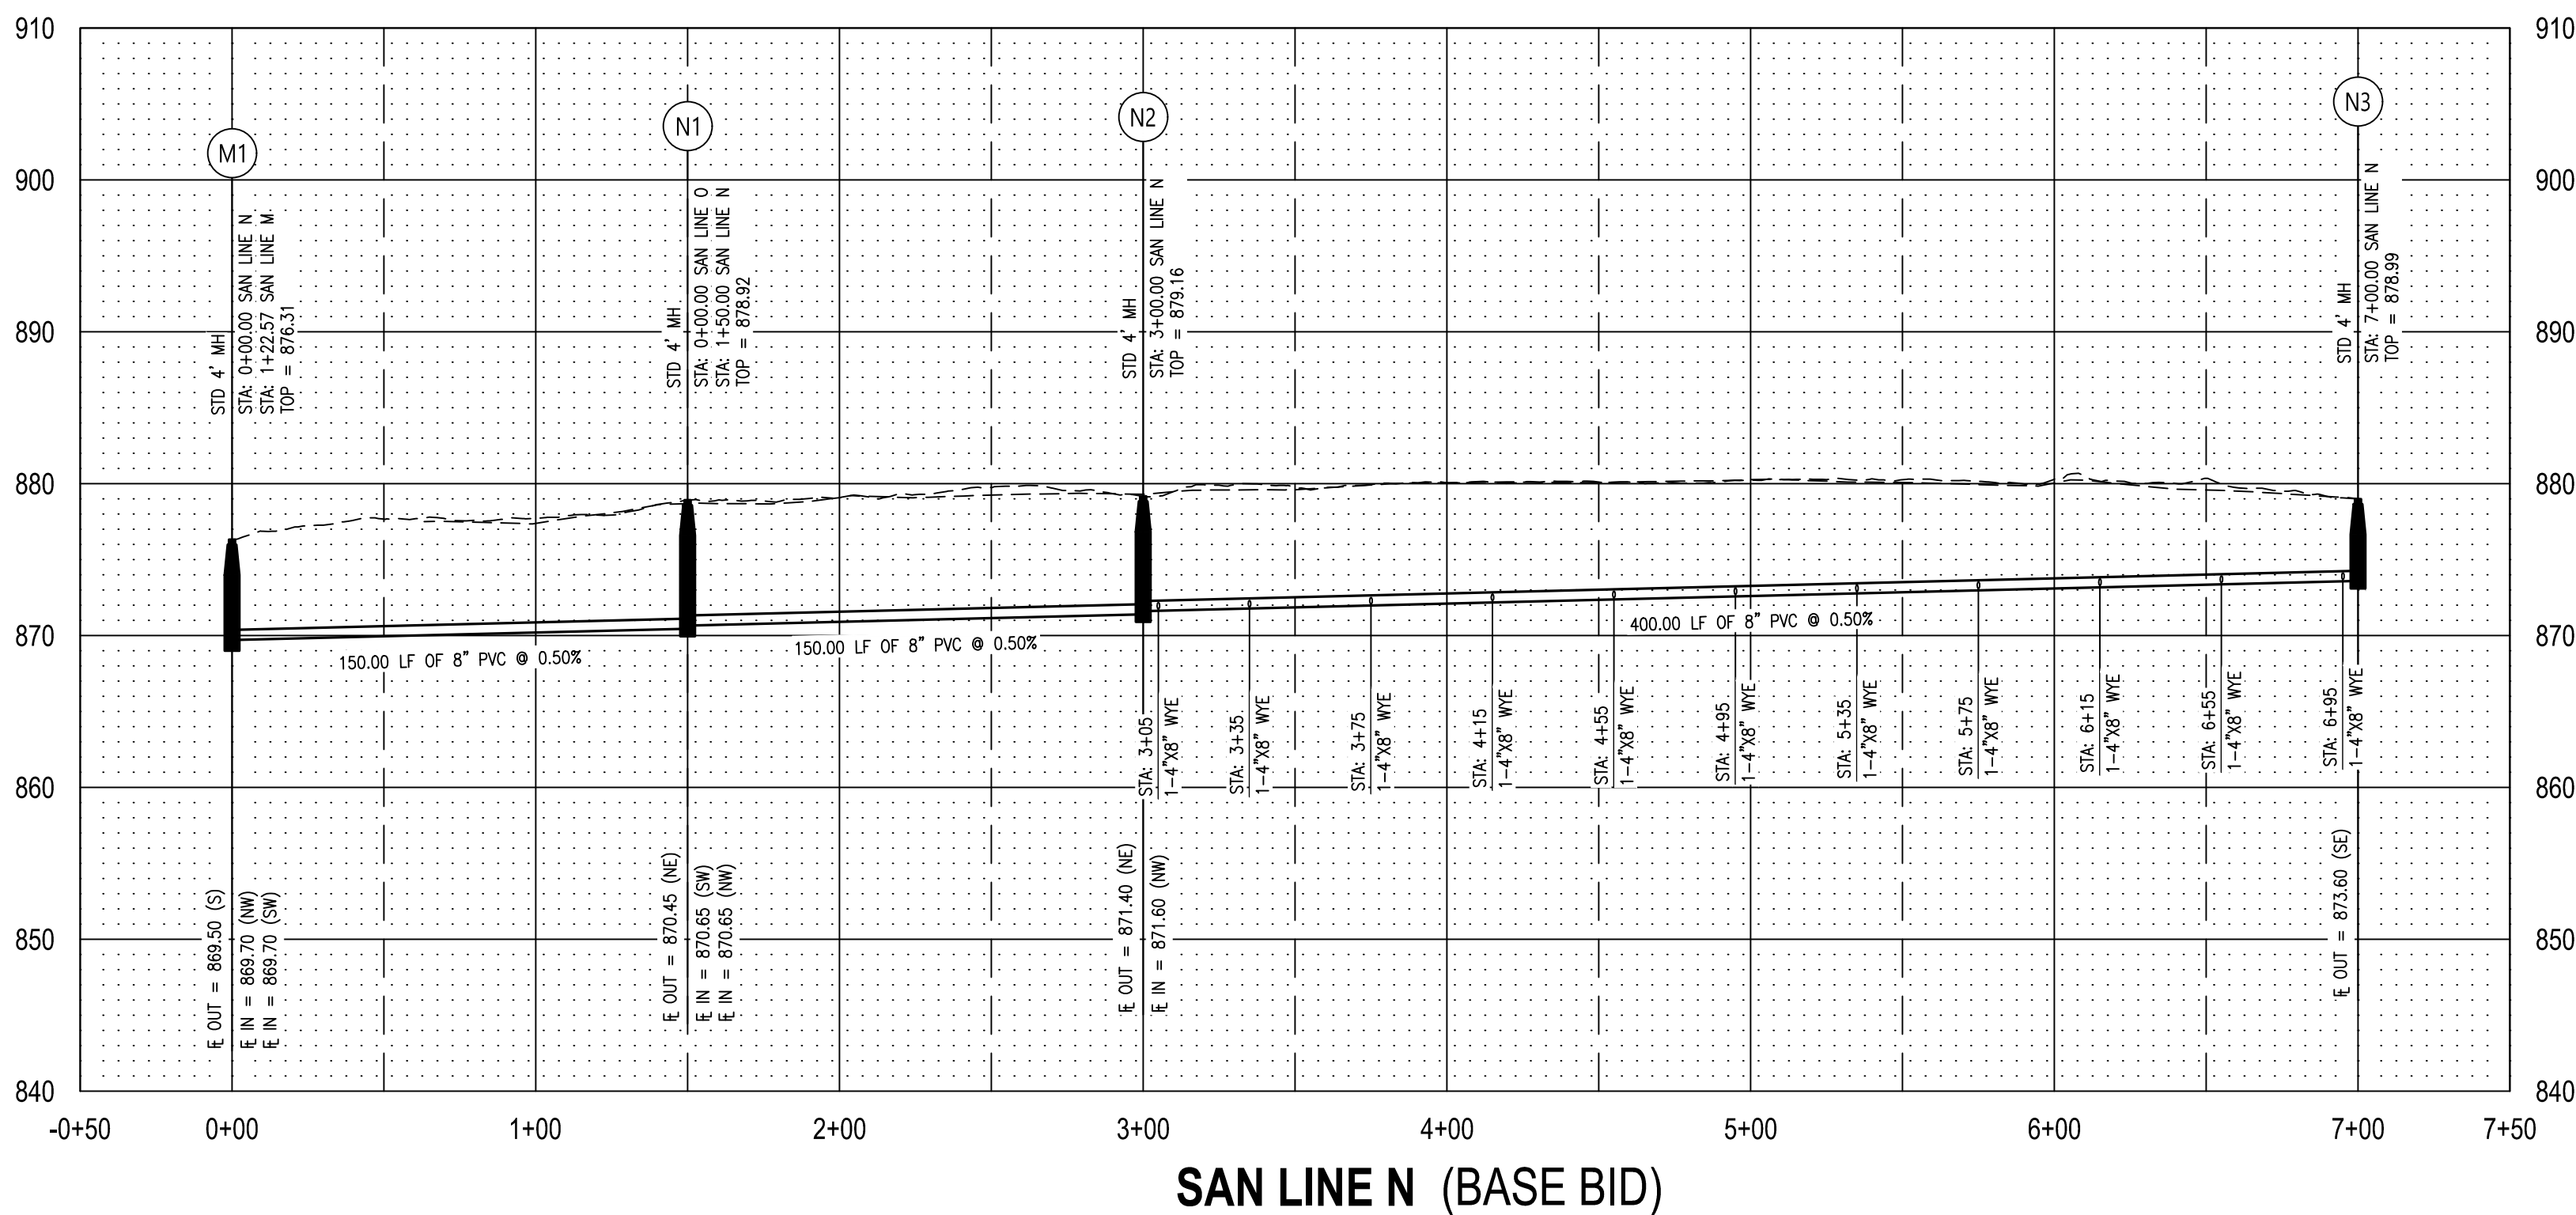



REUSE OF THIS DRAWING IN ANY MANNER IS
STRICTLY PROHIBITED WITHOUT THE WRITTEN
APPROVAL OF
ALLSTATE CONSULTANTS LLC



MISSOURI
STATE FAIRGROUNDS



PROJECT # F2307-01
SITE # 1501
ASSET # 3511501153

CAD DWG FILE: 23117.02-SHEETSBASE
DRAWN BY: DEP
CHECKED BY: CWS
DESIGNED BY: BPH



SHEET NUMBER:

21 OF 43
11/11/2025

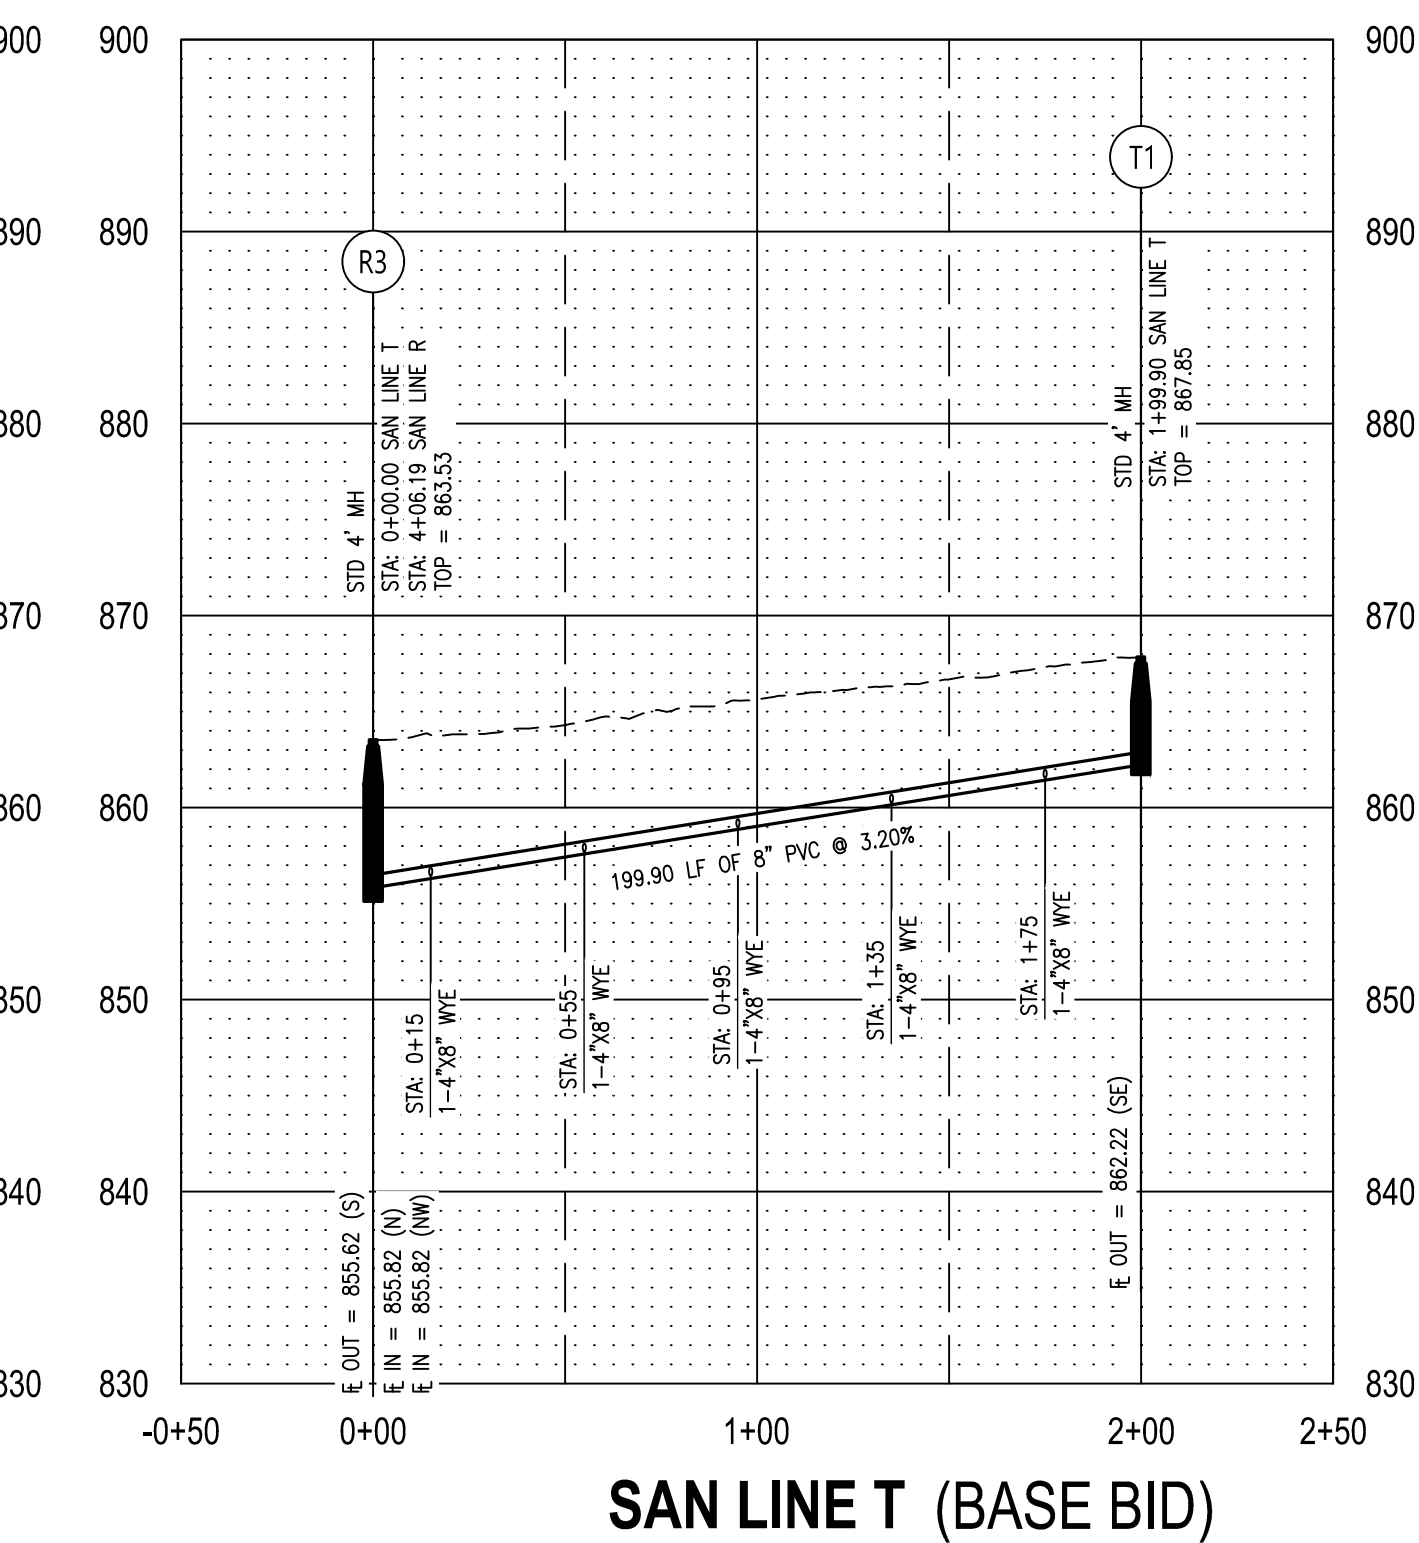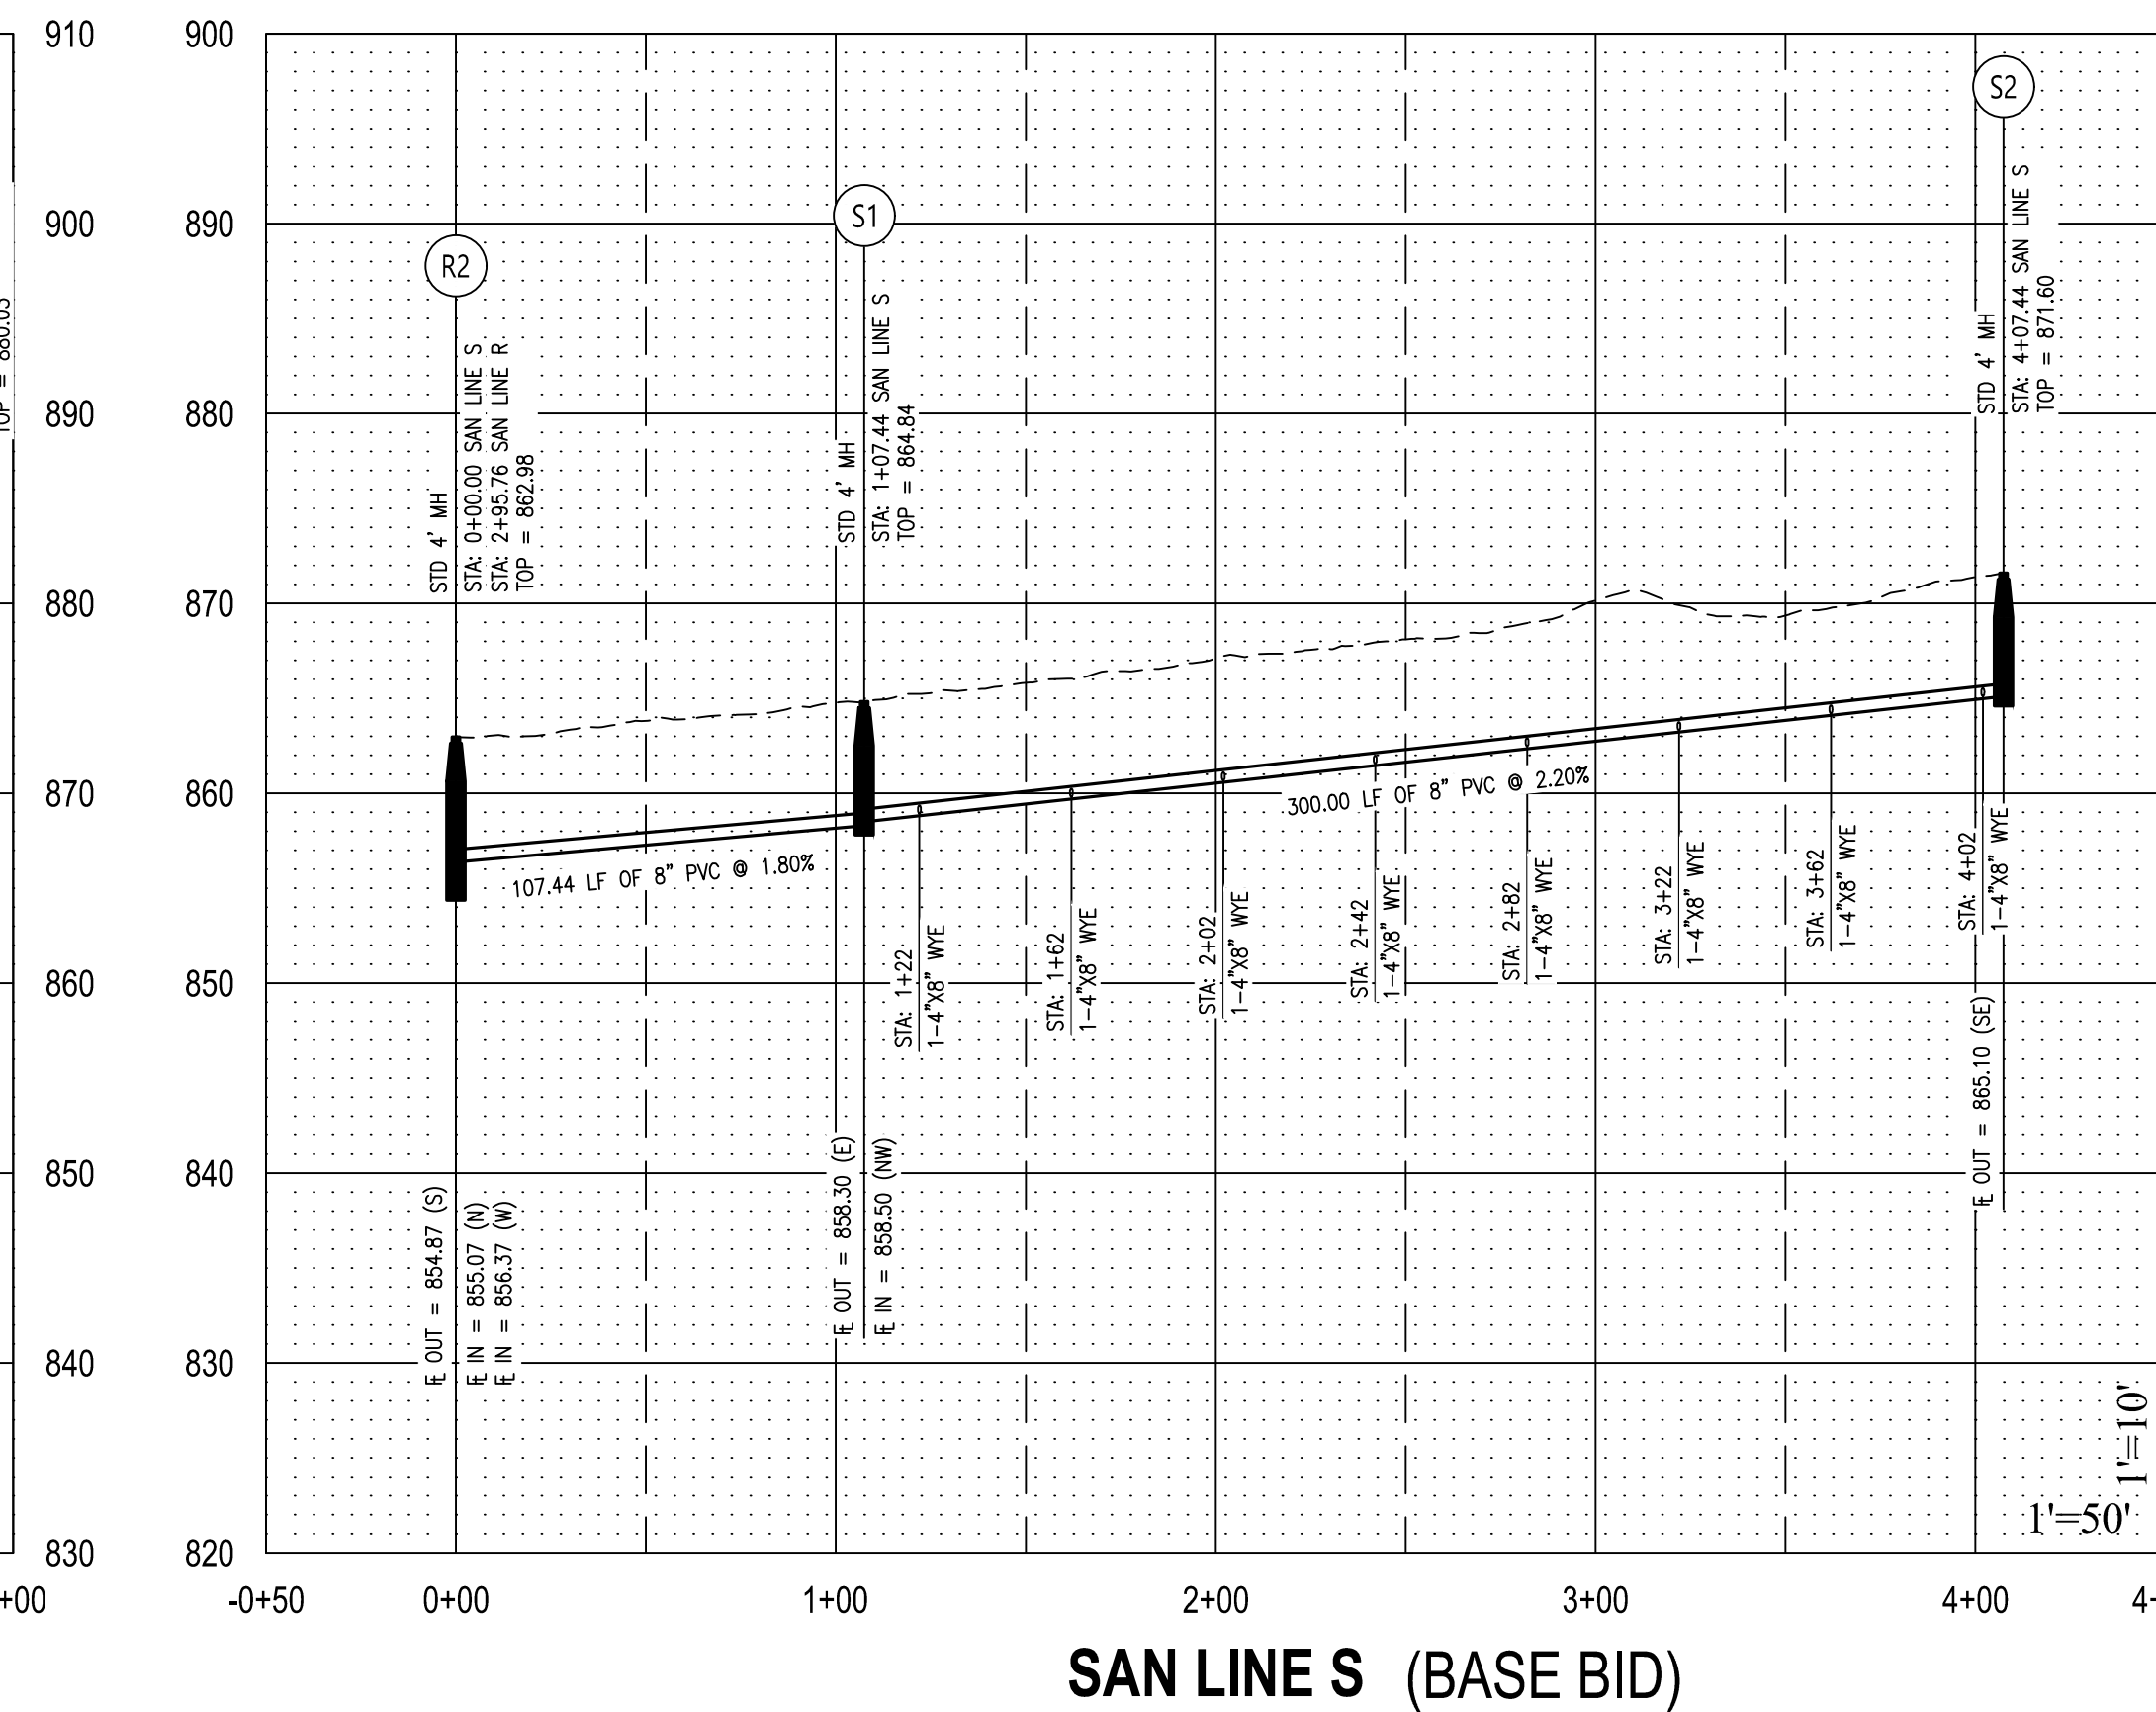

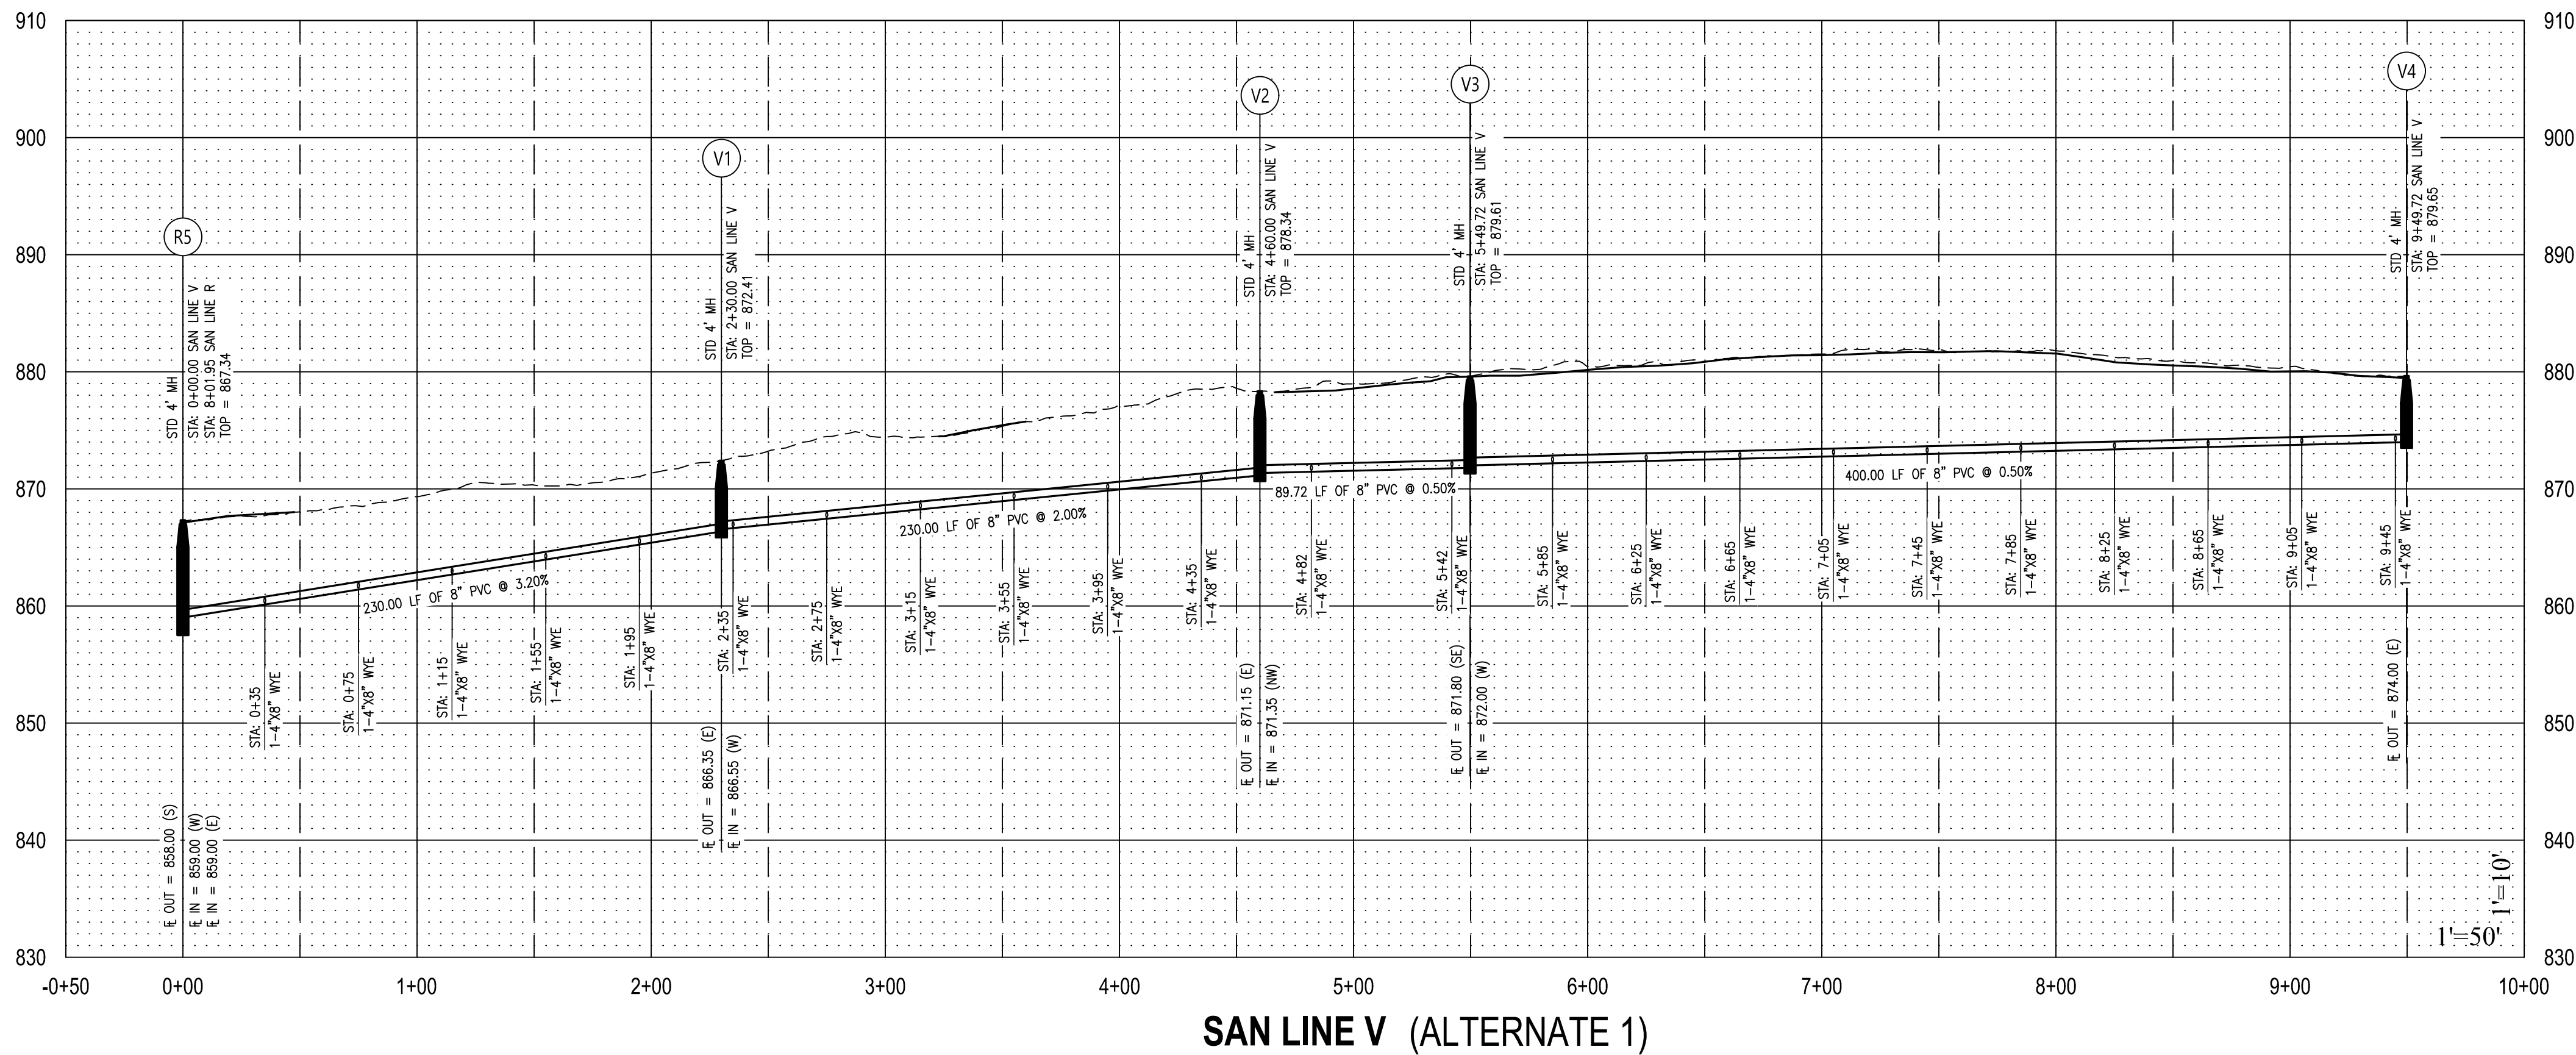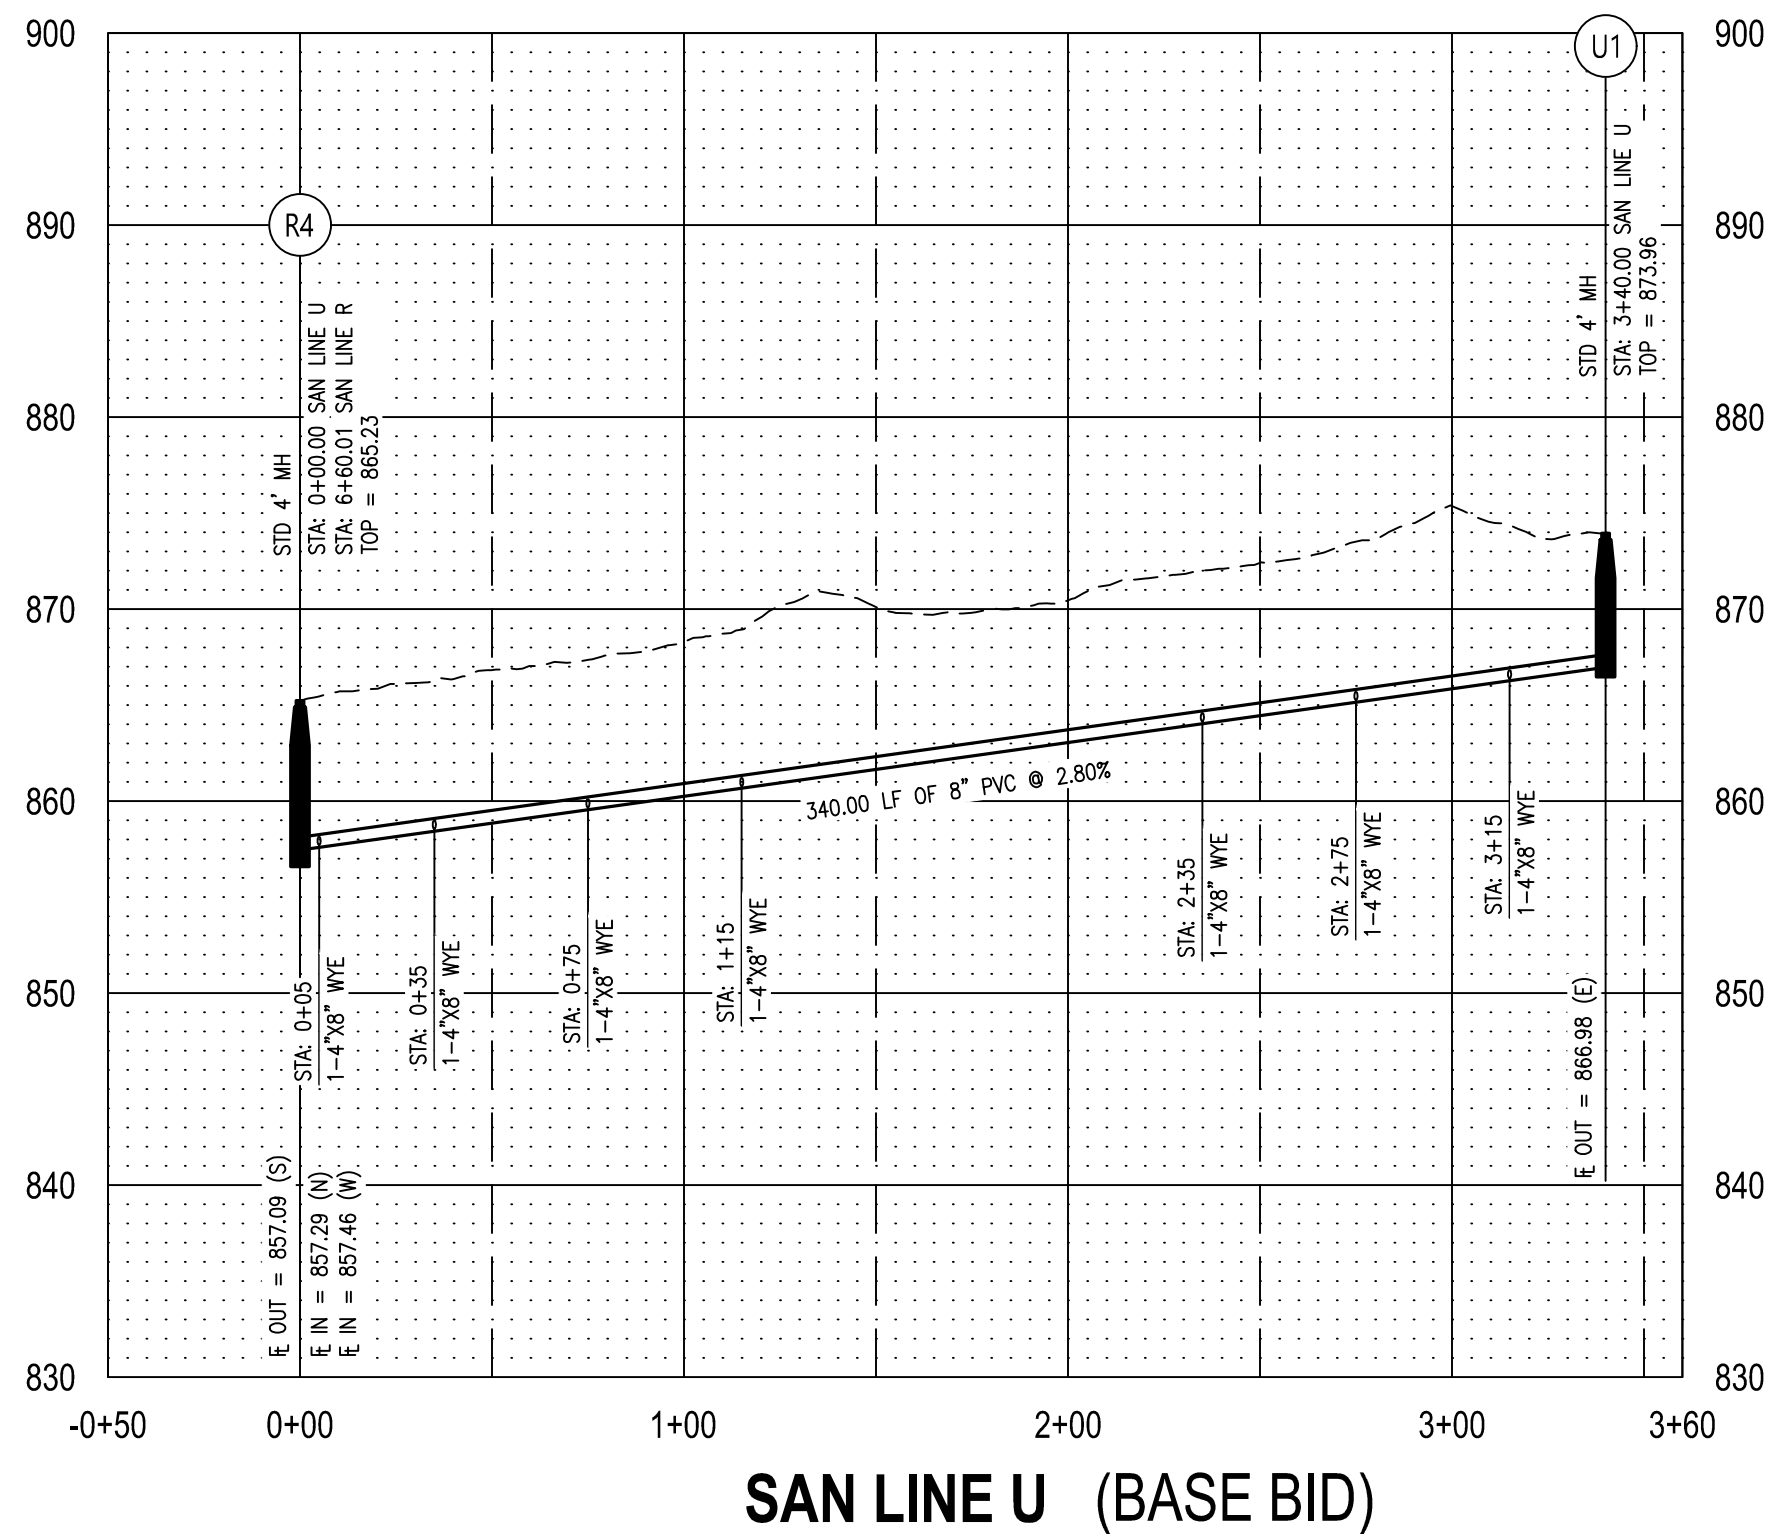

STATE OF MISSOURI
MIKE KEHOE,
GOVERNOR

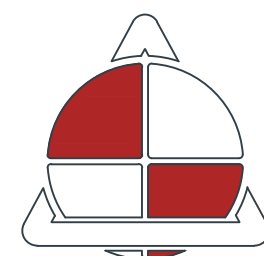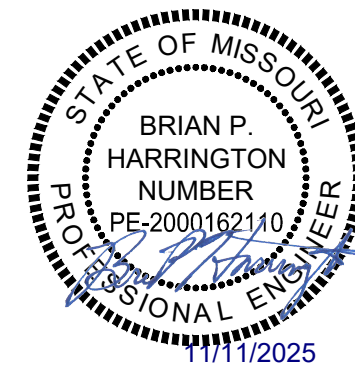

ALLSTATE
CONSULTANTS
allstateconsultants.net
3312 LEMONE INDUSTRIAL BLVD.
COLUMBIA, MO 65201
(573) 875-8799
P.O. BOX 156, 30601 HIGHWAY 5
MARCELINE, MO 64658
(660) 376-2941
410 SE THIRD ST., SUITE 103C
LEE'S SUMMIT, MO 64063
(816) 895-2310
MISSOURI STATE CERTIFICATE
OF AUTHORITY #2007004004
REUSE OF THIS DRAWING IN ANY MANNER IS
STRICTLY PROHIBITED WITHOUT THE WRITTEN
APPROVAL OF
ALLSTATE CONSULTANTS LLC

OFFICE OF ADMINISTRATION
DIVISION OF FACILITIES
MANAGEMENT,
DESIGN AND CONSTRUCTION

MISSOURI
STATE FAIRGROUNDS

NEW CAMPGROUND
CONSTRUCTION PLANS

MISSOURI
STATE FAIRGROUNDS
2503 W 16th STREET
SEDALIA, MO

PROJECT # F2307-01
SITE # 1501
ASSET # 3511501153

REVISION: _____
DATE: _____
REVISION: _____
DATE: _____
REVISION: _____
DATE: _____
ISSUE DATE: 11/11/2025




CAD DWG FILE: 23117.02-SHEETSBASE
DRAWN BY: DEP
CHECKED BY: CWS
DESIGNED BY: BPH

SHEET TITLE:
SANITARY SEWER

SHEET NUMBER:

C-211

22 OF 43
11/11/2025

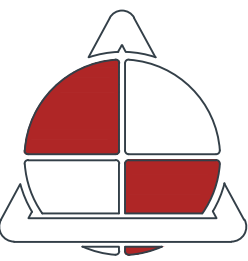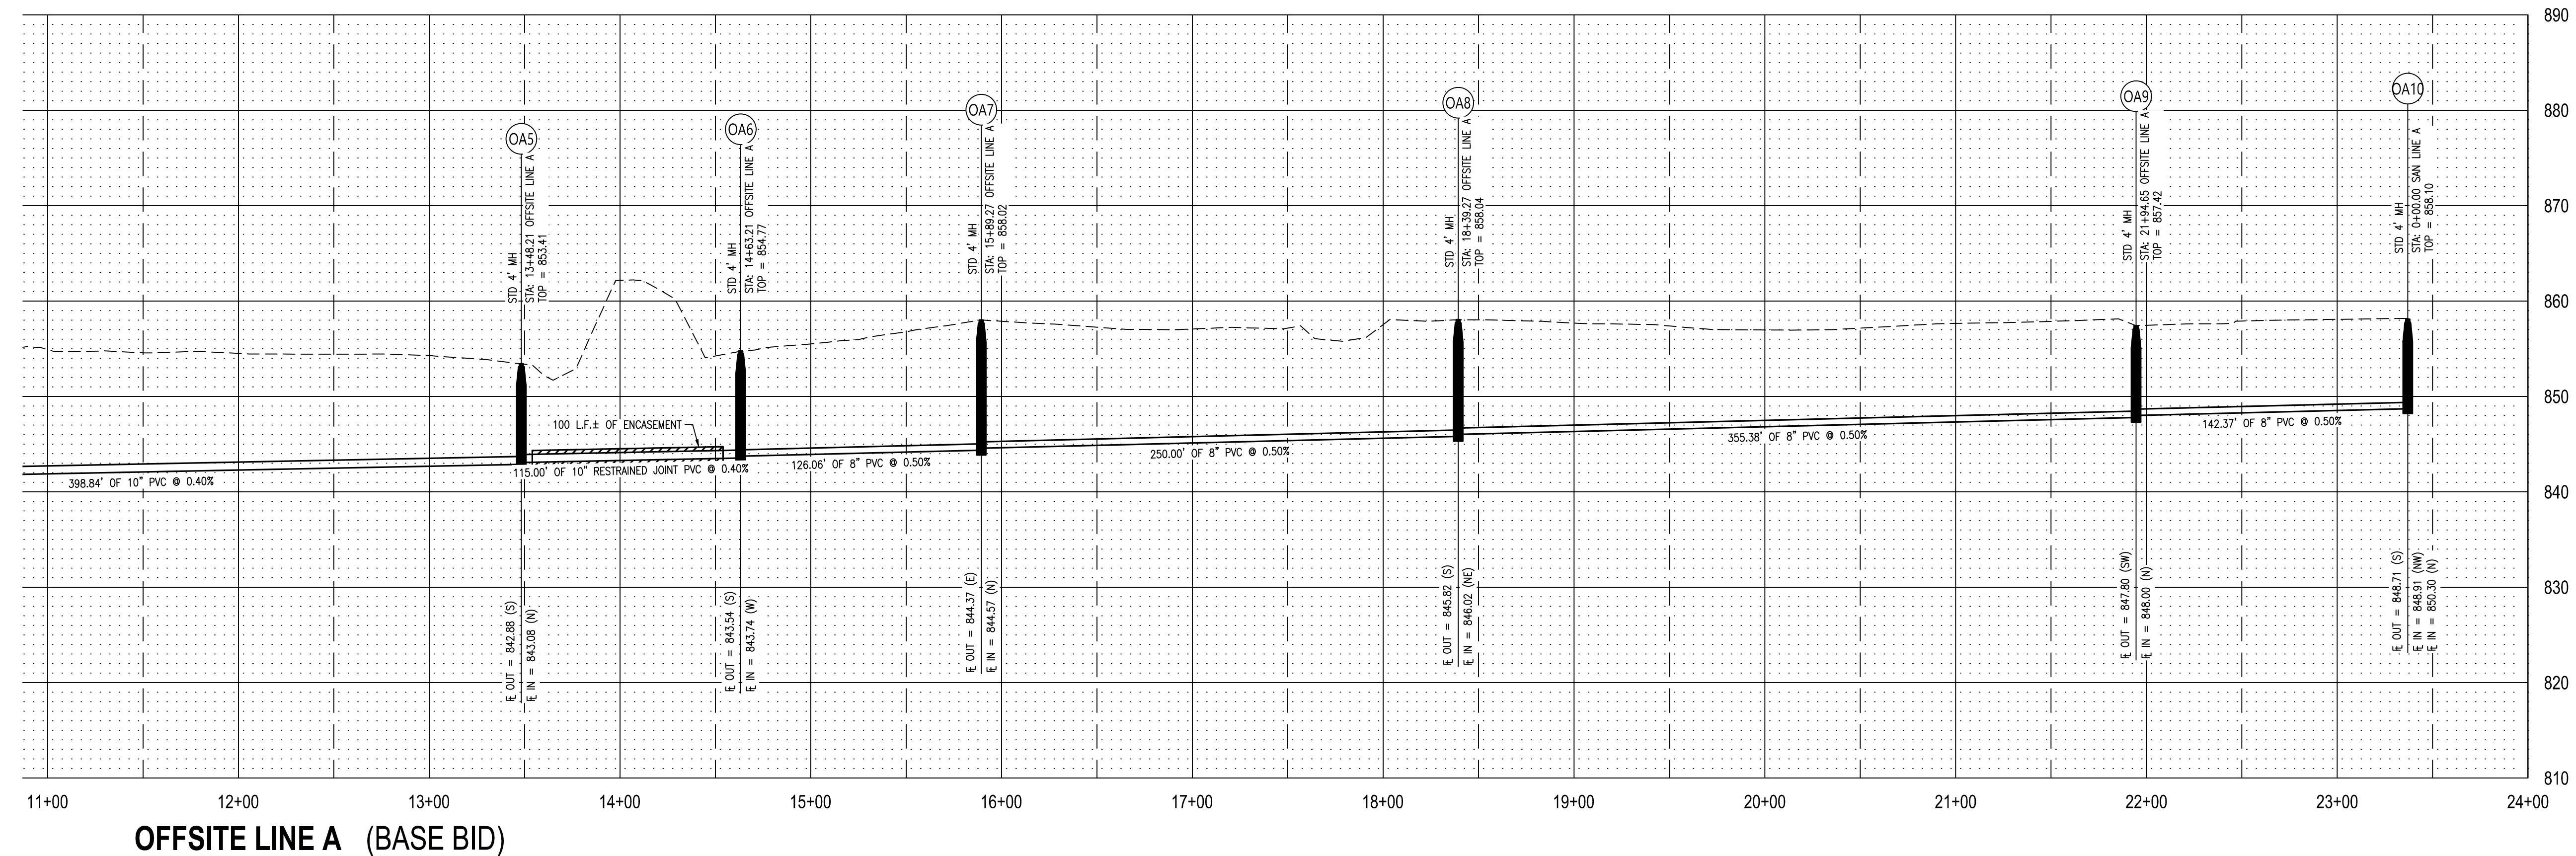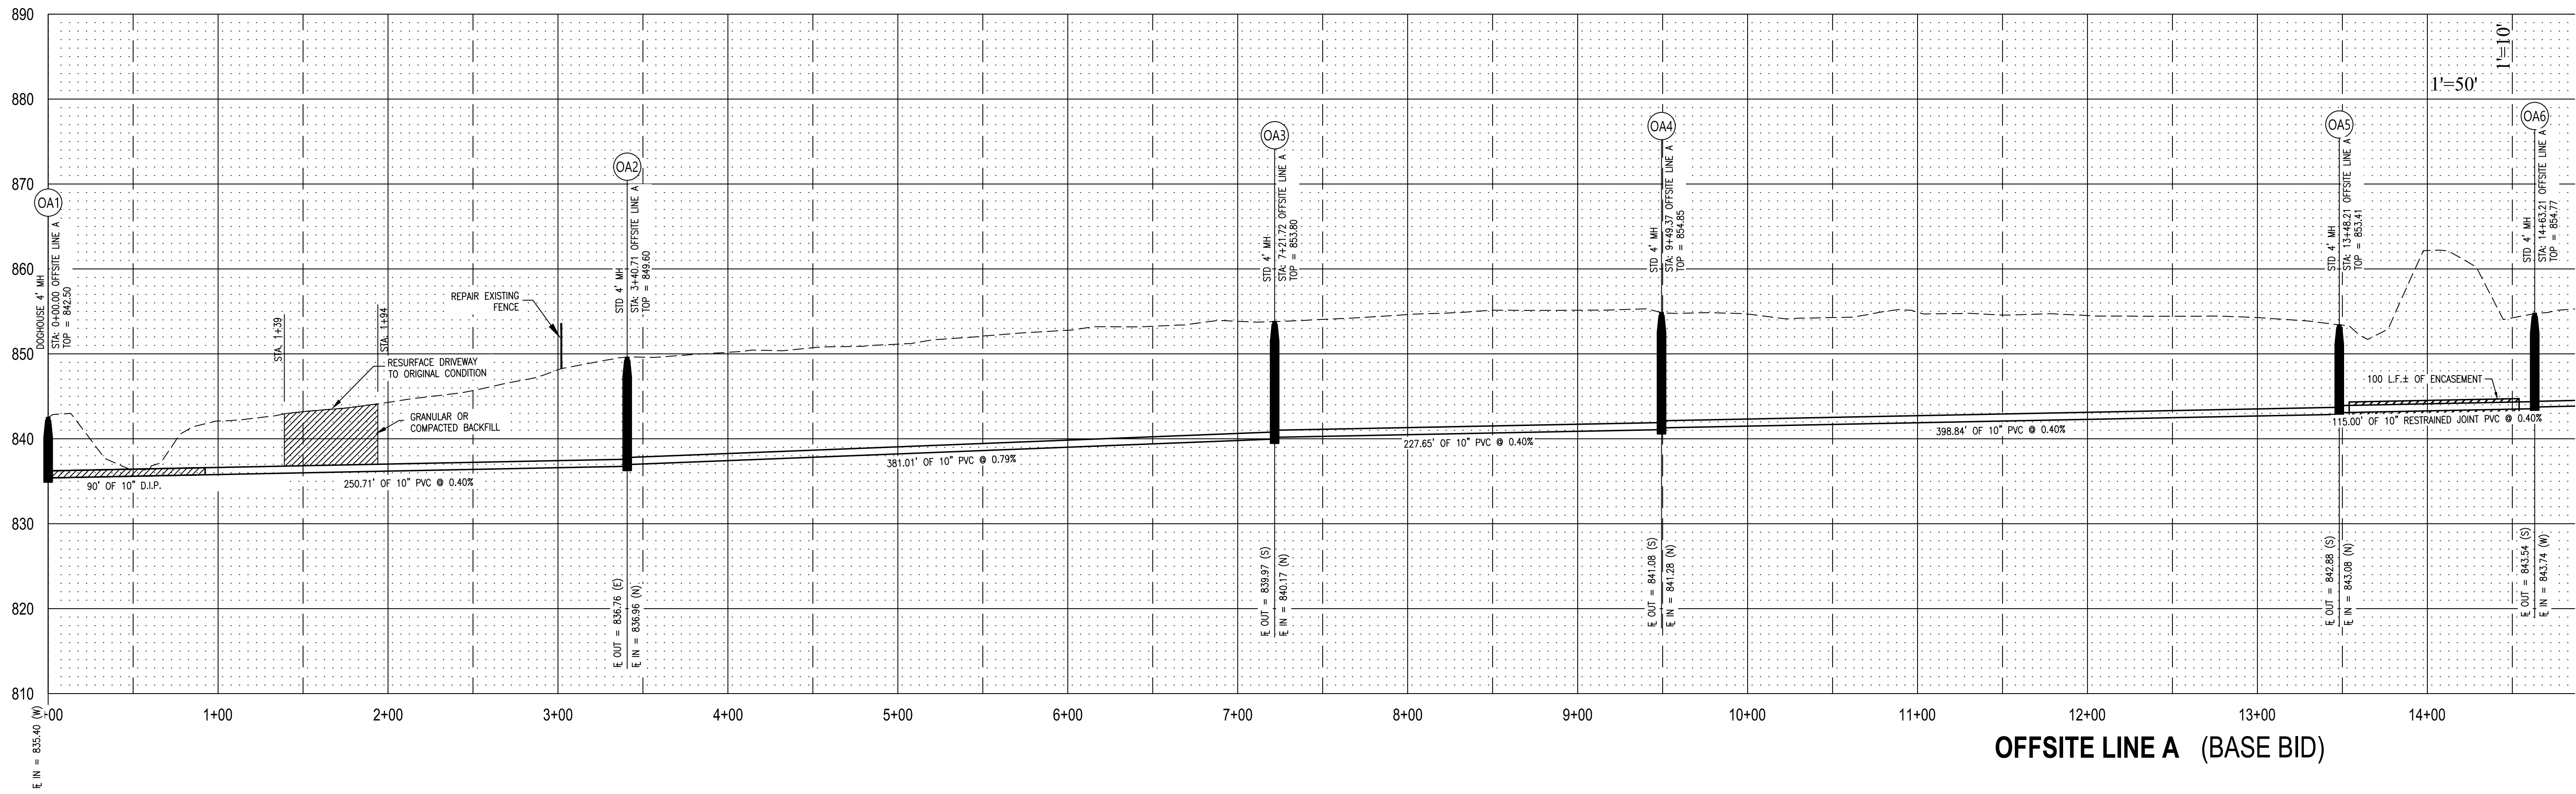

ALLSTATE
CONSULTANTS

allstateconsultants.net

3312 LEMONE INDUSTRIAL BLVD.
COLUMBIA, MO 65201
(573) 875-8799

P.O. BOX 156, 30601 HIGHWAY 5
MARCELINE, MO 64658
(660) 376-2941

410 SE THIRD ST., SUITE 103C
LEE'S SUMMIT, MO 64063
(816) 895-2310

MISSOURI STATE CERTIFICATE
OF AUTHORITY #2007004004
REUSE OF THIS DRAWING IN ANY MANNER IS
STRICTLY PROHIBITED WITHOUT THE WRITTEN
APPROVAL OF
ALLSTATE CONSULTANTS LLC

OFFICE OF ADMINISTRATION
DIVISION OF FACILITIES
MANAGEMENT,
DESIGN AND CONSTRUCTION

MISSOURI
STATE FAIRGROUNDS

NEW CAMPGROUND
CONSTRUCTION PLANS

MISSOURI
STATE FAIRGROUNDS
2503 W 16th STREET
SEDALIA, MO

PROJECT # F2307-01
SITE # 1501
ASSET # 3511501153

REVISION: _____
DATE: _____
REVISION: _____
DATE: _____
REVISION: _____
DATE: _____
ISSUE DATE: 11/11/2025


CAD DWG FILE: 23117.02-SHEETSBASE
DRAWN BY: DEP
CHECKED BY: CWS
DESIGNED BY: BPH

SHEET TITLE:
SANITARY SEWER


SHEET NUMBER:

C-212


23 OF 43
11/11/2025

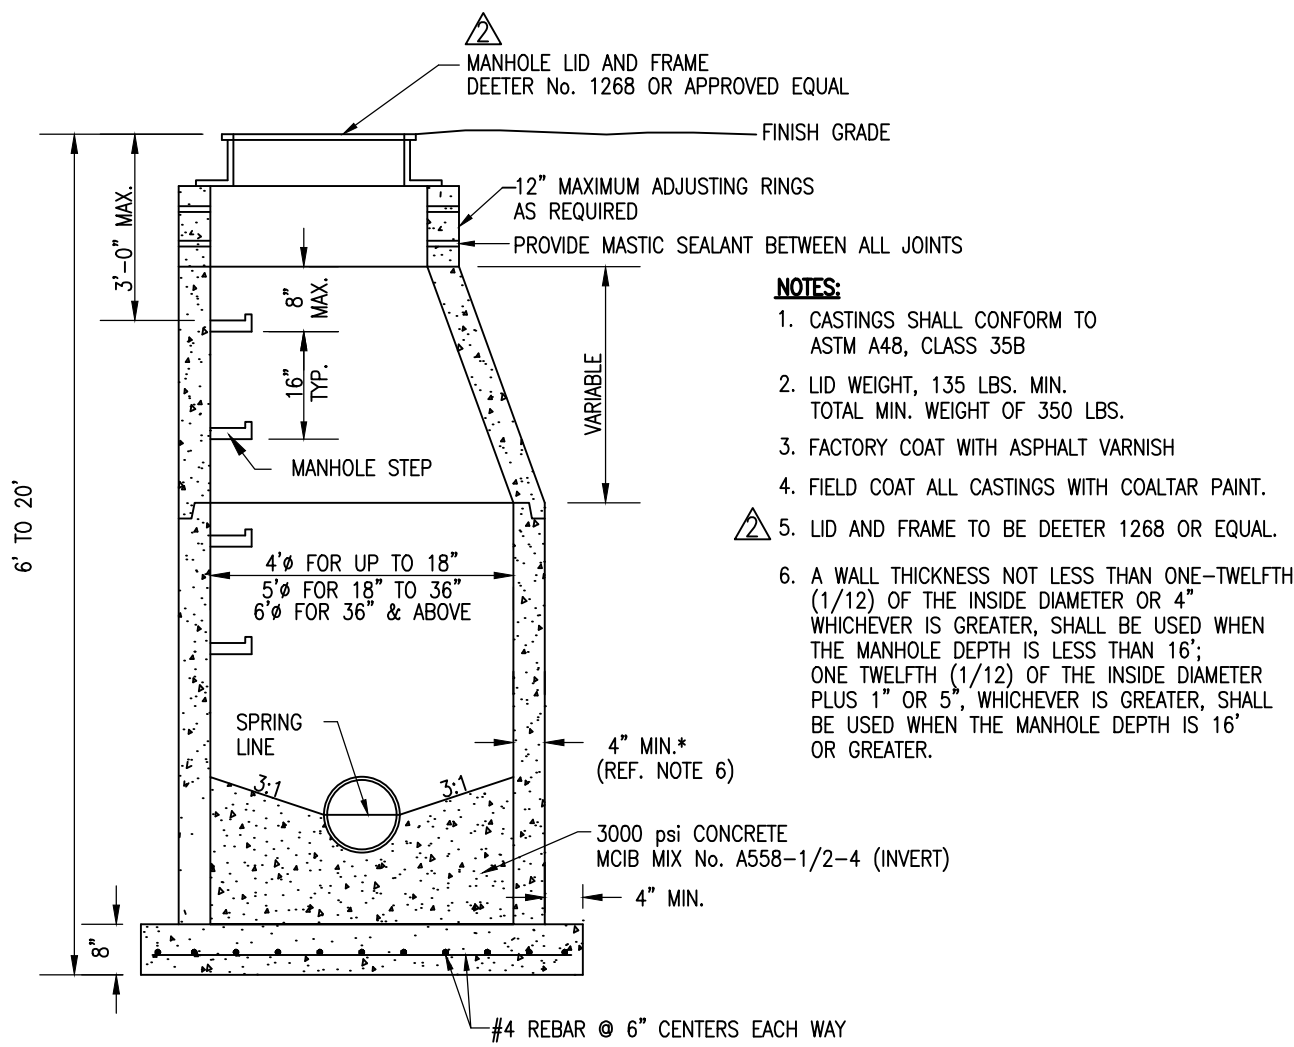


STANDARD MANHOLE

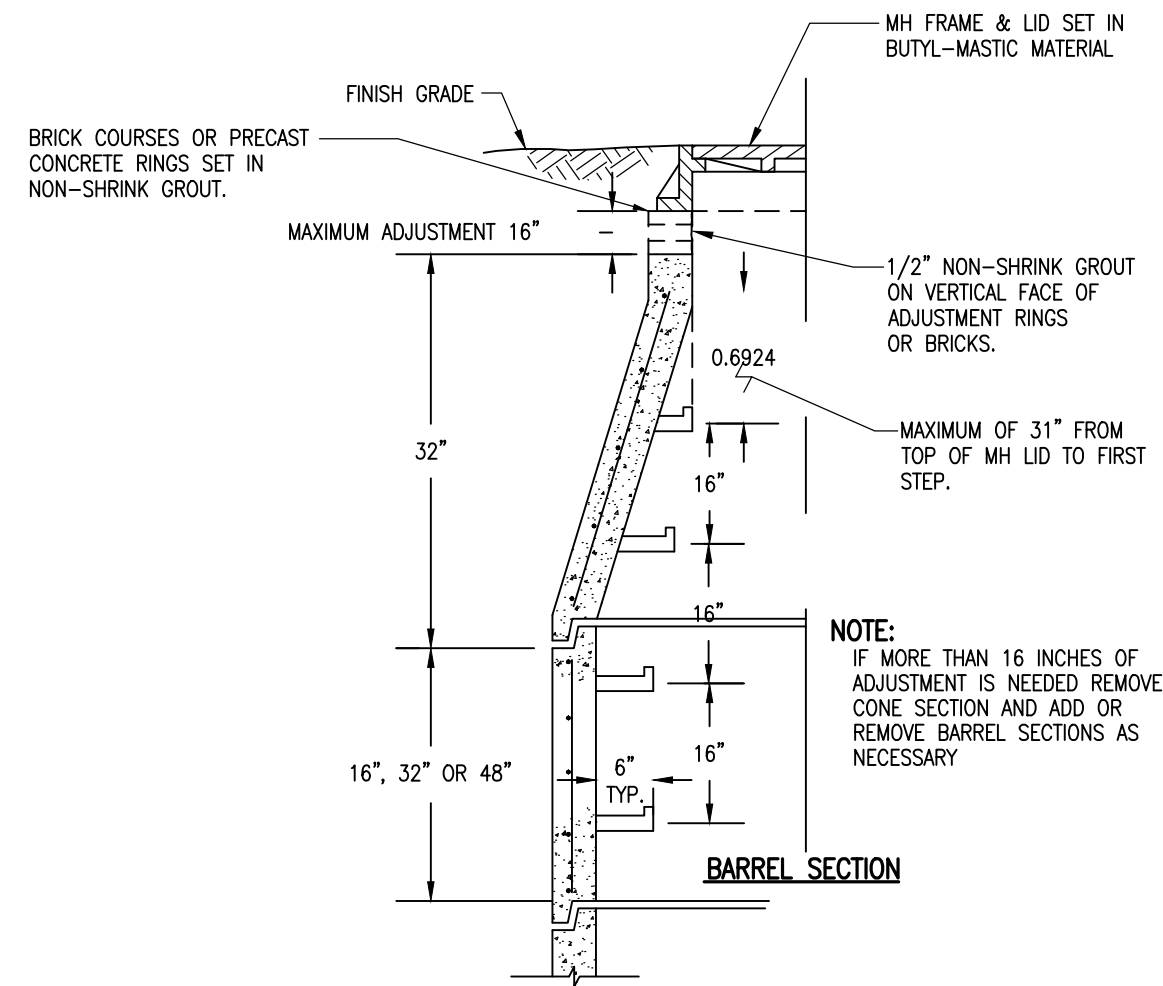

MANHOLE ADJUSTMENT

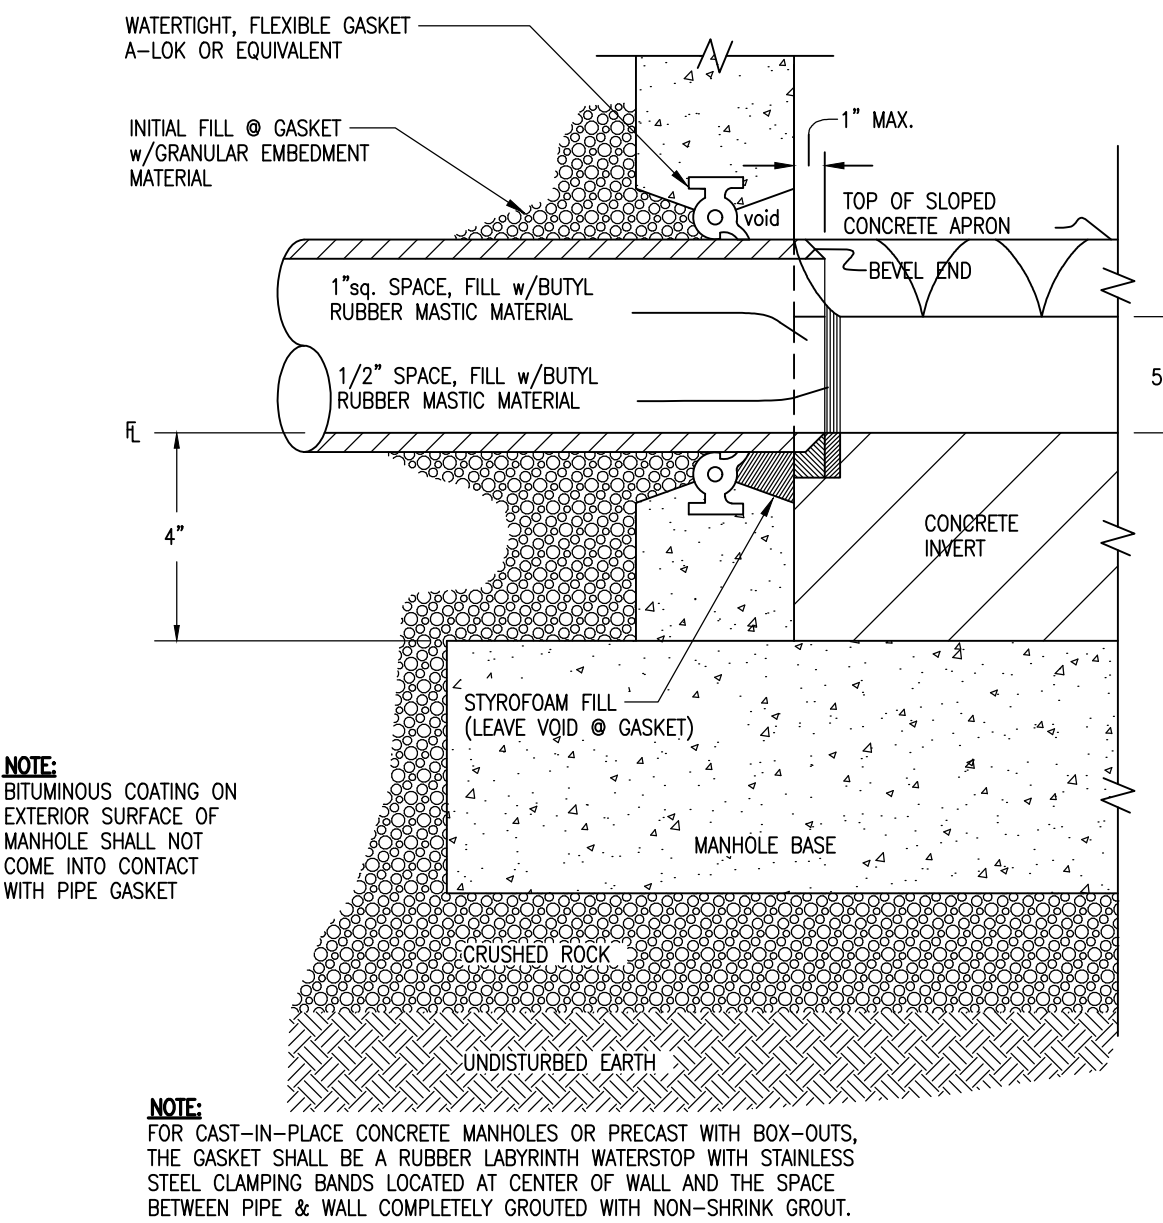


MANHOLE GASKET

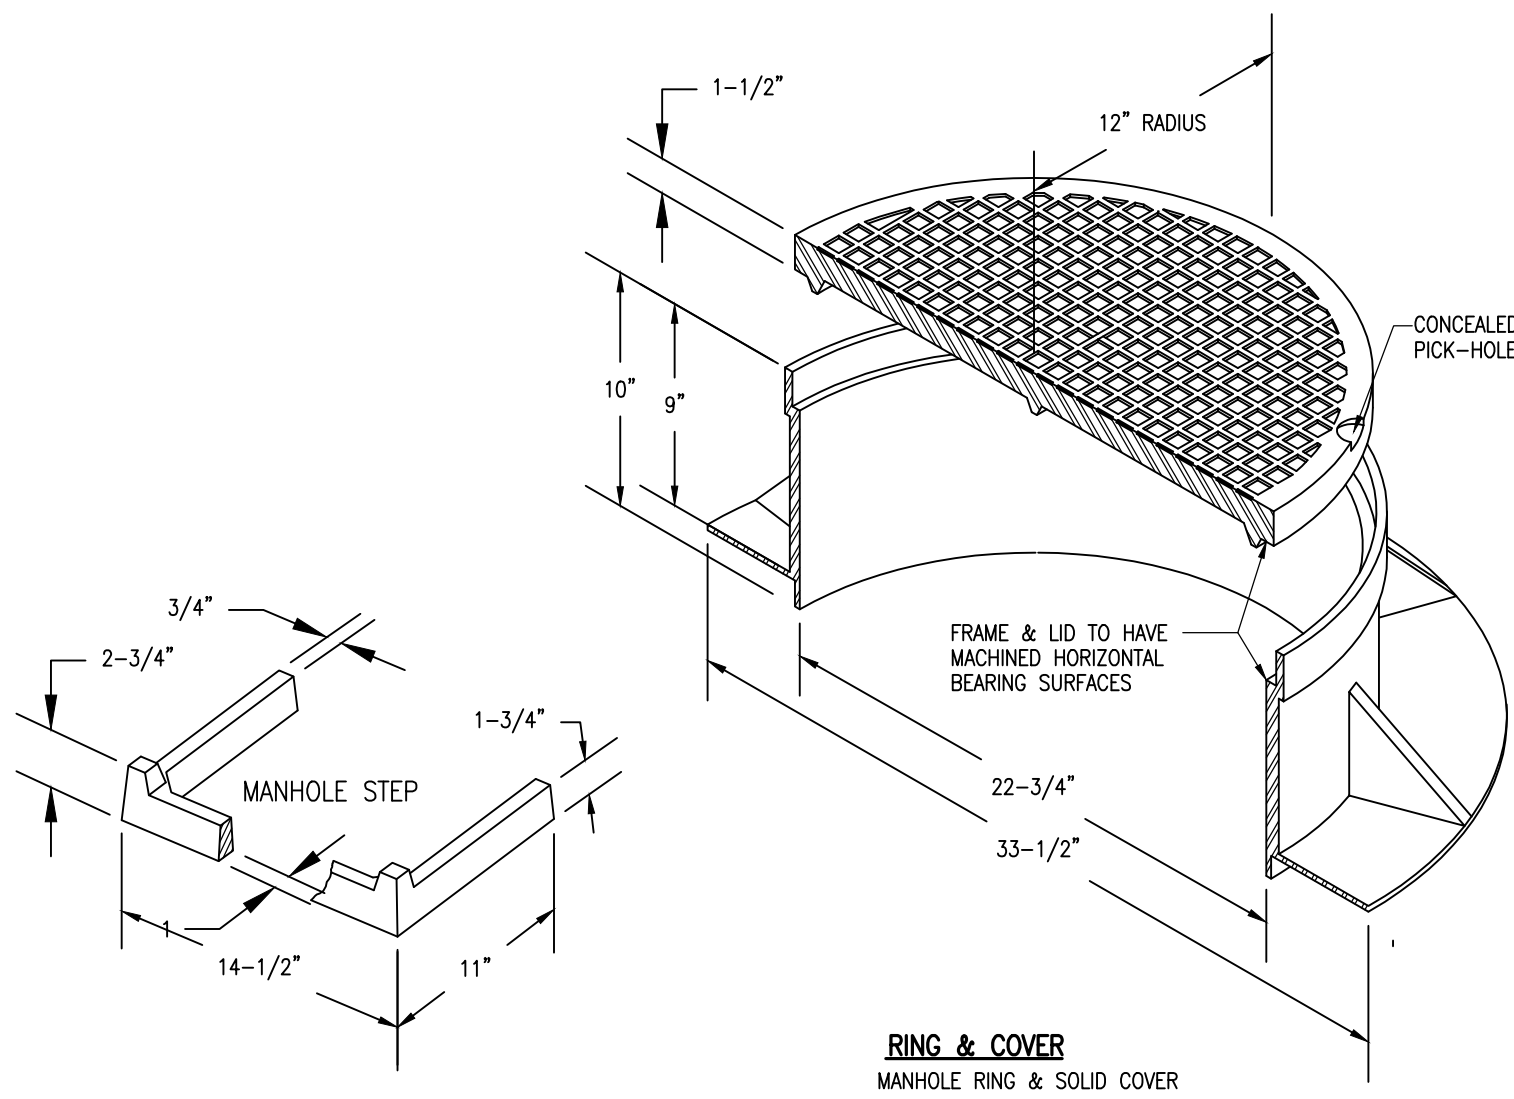


MANHOLE STEP

MANHOLE CASTINGS

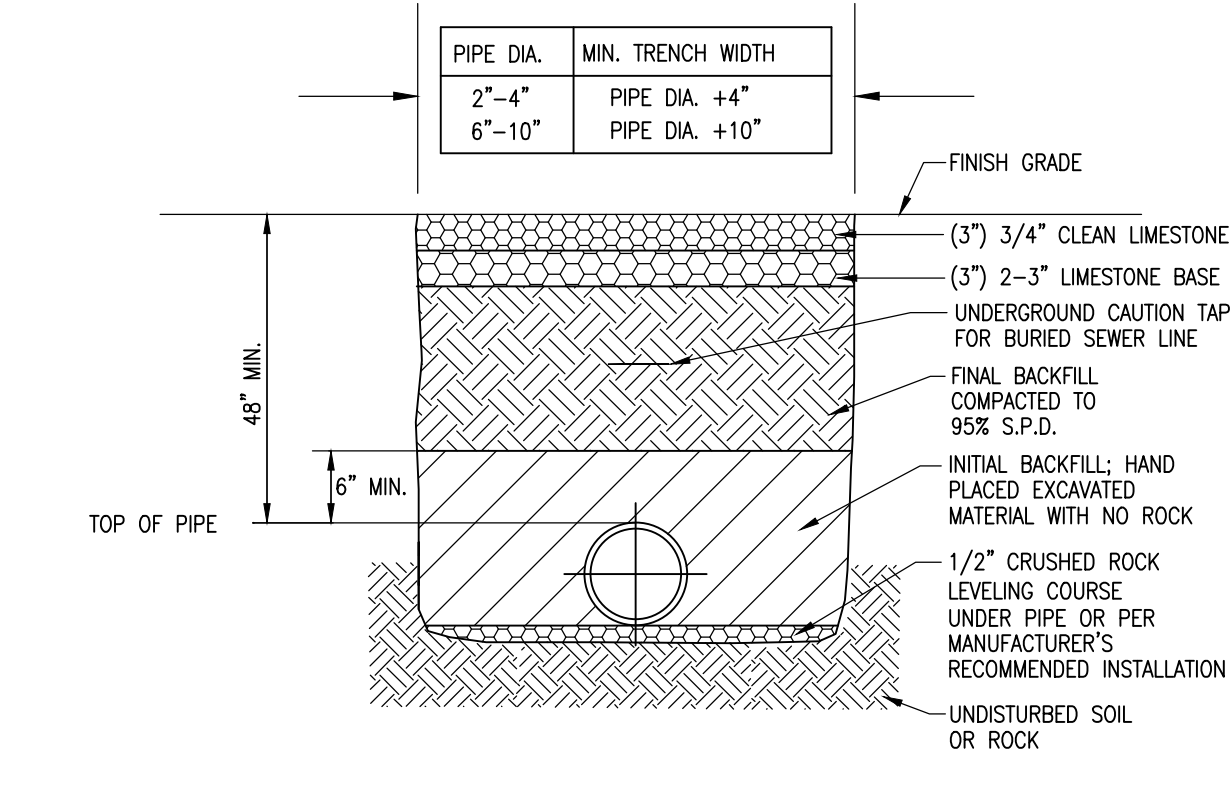


PVC & DUCTILE IRON PIPE EMBEDMENT LOCATED UNDER AGGREGATE SURFACES

TYPICAL EMBEDMENT DETAIL FOR ALL DUCTILE IRON AND PVC PIPING LOCATED UNDER AGGREGATE SURFACES.

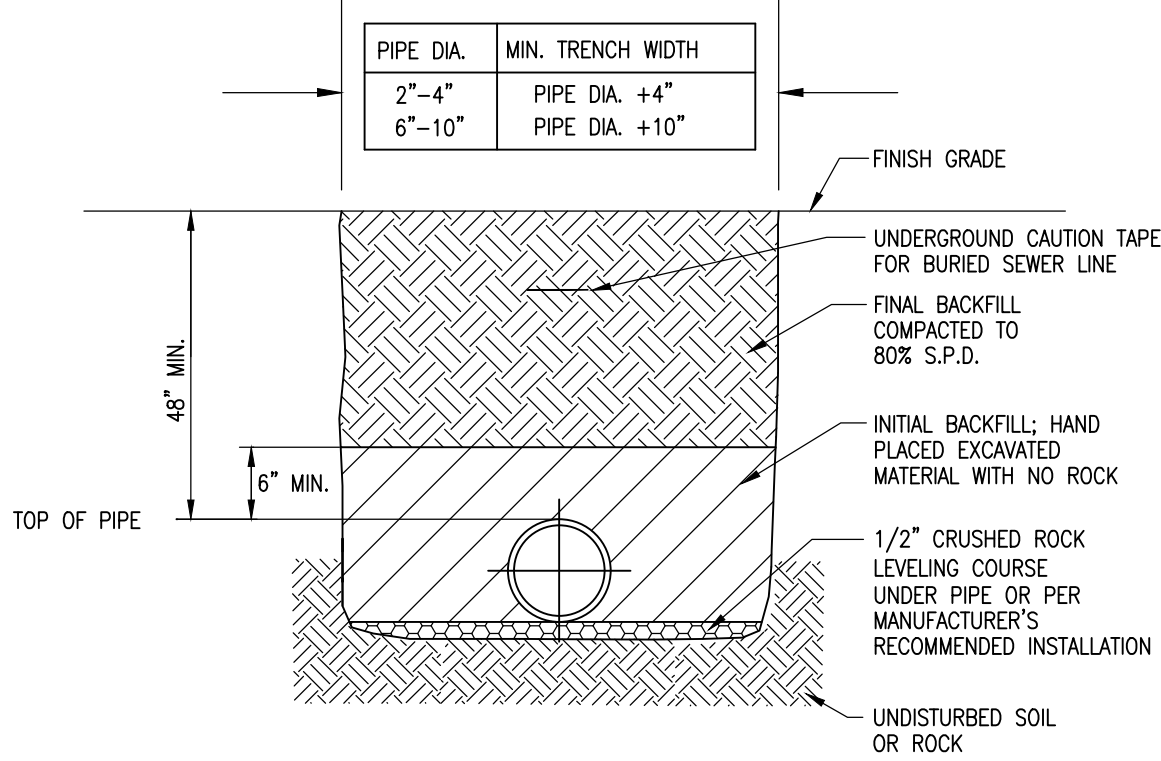


PVC & DUCTILE IRON PIPE w/o GRANULAR EMBEDMENT

TYPICAL EMBEDMENT DETAIL FOR ALL DUCTILE IRON AND PVC PIPING NOT LOCATED UNDER PAVED OR AGGREGATE SURFACES.

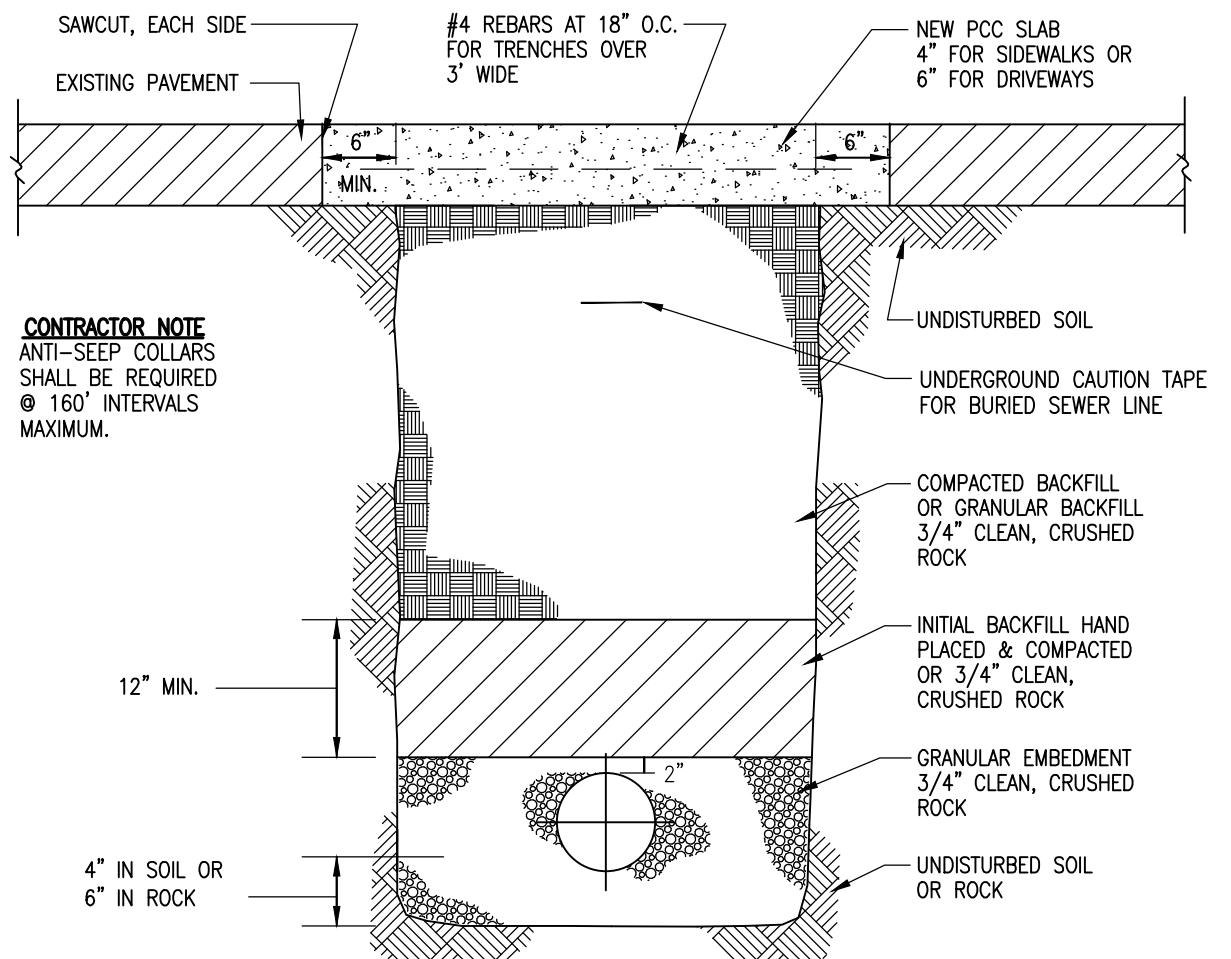

PAVEMENT REPLACEMENT

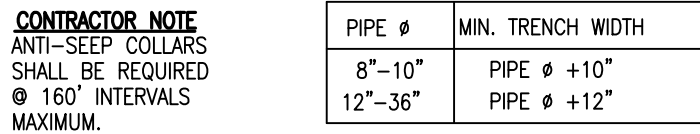


PVC & DUCTILE IRON PIPE w/ GRANULAR EMBEDMENT

TYPICAL EMBEDMENT DETAIL FOR ALL DUCTILE IRON AND PVC PIPING NOT LOCATED UNDER PAVED OR AGGREGATE SURFACES.

NOTES:

- BACKFILL SHALL BE JOB EXCAVATED MATERIAL FREE FROM DEBRIS AND STONES COMPACTED TO 90% OF STANDARD PROCTOR DENSITY AT OPTIMUM MOISTURE CONTENT AS DETERMINED BY ASTM D698. FOR BACKFILL UNDER PAVEMENT (EXISTING OR PROPOSED) SEE SD-9 AND SD-11.
- BEDDING MATERIAL SHALL BE 1/2" TO 3/4" CLEAN CRUSHED ROCK.
- TRENCH BANKS WILL BE CUT BACK ON SLOPES IN ACCORDANCE WITH CURRENT OSHA REGULATIONS. SLOPES MUST NOT EXTEND BELOW TOP OF BEDDING.
- MINIMUM AND MAXIMUM WIDTHS SHALL BE IN ACCORDANCE WITH PIPE MANUFACTURER'S RECOMMENDATION AS APPROVED ON ENGINEERING PLANS.

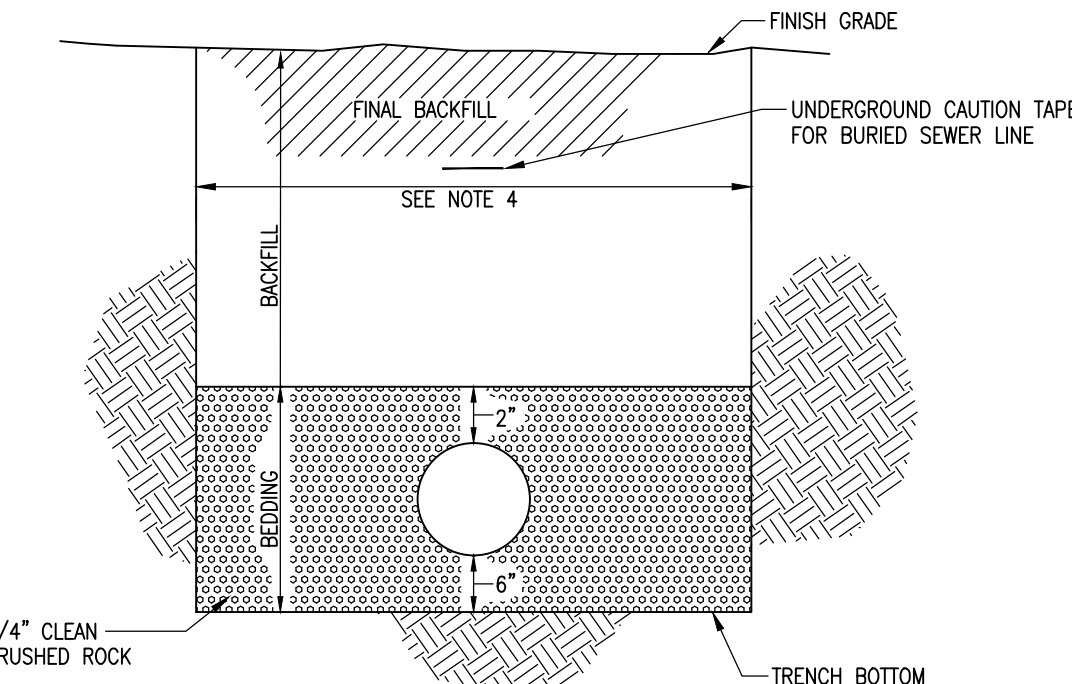

TYPICAL SECTION

TYPICAL SECTION

SANITARY SEWERS SPECIFICATIONS


SEWER PIPE

- Reinforced Concrete Pipe – Reinforced concrete pipe and fittings shall conform to the requirements of ASTM C76. Gaskets shall be neoprene or other synthetic rubber. Natural rubber gaskets will not be acceptable.
- Ductile Iron Pipe – Ductile iron pipe shall conform to AWWA C151, Class 51 minimum. Joints shall be mechanical or push-on joints and conform to the current specification AWWA C111. Gaskets shall be neoprene or synthetic rubber material. Natural rubber gaskets will not be acceptable.
- Fittings shall conform to the current AWWA specifications C110 and C153 and shall have a pressure rating of not less than that specified for the pipe.
- Polyvinyl Chloride Pipe (PVC)
 - Gravity Sewer: Polyvinyl chloride pipe shall conform to ASTM D-3034, Type PSM. The minimum wall thickness shall conform to SDR 35 (minimum).
 - ServiceLines: Polyvinyl chloride pipe shall be SDR 26 (minimum).
 - Pressure ForceMain: Polyvinyl chloride pipe shall conform to ASTM D-2241. The minimum wall thickness shall conform to SDR 21 (minimum) for pipe size 2" in diameter or larger. For pipe size smaller than 2" in diameter the pipe shall conform to Schedule 40 (minimum).
- Flexible gasketed joints shall be compression-type with an integral bell. The integral bell shall have an elastomeric gasket ring conforming to the requirements of ASTM D-3139 (Pressure Pipe), ASTM D-3212 (Drain and Sewer), and ASTM F477. Gaskets shall be neoprene or other material. Natural rubber gaskets will not be acceptable.
- For sewer pipe with depth of cover exceeding 15 feet, the Engineer shall make earth loading analysis to determine if increased pipe strength is required in accordance with manufacturer specifications.

MANHOLES SPECIFICATIONS

Manholes shall be provided/installed complete with ring and cover, steps, fittings, and other appurtenances, in accordance with the following criteria and standard details, and manufacturers recommendations.

- Concrete – 4000 PSI MCIB Mix No. A558-1-2
3000 PSI MCIB Mix No. A535-1/2-4
- Precast Sections – Circular precast concrete shall meet the requirements of ASTM C478. The exterior of all joints shall be sealed with 6" Hamilton-Kent "Kent Seal" tape or approved equal.
- Dimensions – As shown, or per manufacturers recommendations.
- Flexible Joint – Hamilton-Kent "Kent Seal", Bidco Sealants, Inc. "Bidco C56", or approved equal. The minimum bead dimensions shall be one square inch.
- Coal Tar Paint – Koppers "Bitumastic Super Service Black", Tnemec "46-450 Heavy Tnemecol", Porter "Tar Mastic 100", or approved equal.
- Flexible Gaskets – Flexible gaskets shall be Press-wedge, PSX (Press Seal Gasket Corporation), A-Lok (A-Lok Products, Inc.), or approved equal.
- Portland Cement – Portland Cement shall conform to ASTM C150, Type II or IV. When high early strength is required, Type IV can be used.
- Fine Aggregate – Fine aggregate shall meet the requirements of ASTM C33.
- Coarse Aggregate – Coarse aggregate shall meet the requirements of ASTM C33.
- Mortar – One part Portland Cement, Type II, three parts sand, one-fourth part Hydrated lime, conforming to ASTM C207.
- Lifting Eyes – All manholes shall be cast with proper lifting eyes on all precast manhole sections.
- Reinforcing Steel – ASTM A615, Grade 40 or Grade 60.
- Precast concrete manholes shall conform to ASTM C478 except as modified by the specifications.
- Bases not built monolithic with bottom section shall be poured of 4000 PSI concrete. Monolithic bases shall not interfere w/pipe installation.
- Manhole may be transitioned to 4'0" diameter, 8' above F.L. of outfall for 5'0" and 6'0" manholes.
- The bottom section of all precast manholes not built monolithic with the base shall be set into a steel-reinforced poured concrete base a minimum of 4". (#4@6"E.W.)
- Waterproofing will be required on the outside of manholes. The bitumen shall consist of two (2) six (6) mil coats of coal tar paint.
- The compressive strength of concrete used in the construction of precast reinforced concrete manholes shall be not less than 4000 PSI.
- Only eccentric manhole cones will be allowed unless otherwise approved by the City Engineer.
- Plastic manhole steps shall be provided, spaced at 1'-4" O.C., where inlet or manhole depth is greater than 4'-0". Steps shall be M.A. Ind., Inc. model PS-2-PF or approved equal. Steps shall be cast-in-place unless otherwise approved by the Engineer.
- The fill concrete flow channel for side branches shall be placed to provide a smooth transition into the line flow.
- Manholes shall not be constructed within limits of stream banks.
- Flexible gaskets shall be Press-Wedge, PSX (Press Wedge Corp.), A-Lok (A-Lok Products Inc.), or approved equal. Gaskets shall be installed according to product manufacturer. Manhole manufacturer shall be responsible for extra reinf. steel and concrete placement on manholes.

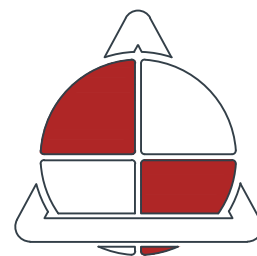

ALLSTATE
CONSULTANTS

allstateconsultants.net

3312 LEMONE INDUSTRIAL BLVD.

COLUMBIA, MO 65201

(573) 875-8799

P.O. BOX 156, 30601 HIGHWAY 5

MARCELINE, MO 64658

(660) 376-2941

410 SE THIRD ST., SUITE 103C

LEE'S SUMMIT, MO 64063

(816) 895-2310

MISSOURI STATE CERTIFICATE

OF AUTHORITY #2007004004

RELEASE OF THIS DRAWING IN ANY MANNER IS

STRICTLY PROHIBITED WITHOUT THE WRITTEN

APPROVAL OF

ALLSTATE CONSULTANTS LLC

OFFICE OF ADMINISTRATION
DIVISION OF FACILITIES
MANAGEMENT,
DESIGN AND CONSTRUCTION

MISSOURI
STATE FAIRGROUNDS

NEW CAMPGROUND
CONSTRUCTION PLANS

MISSOURI
STATE FAIRGROUNDS
2503 W 16th STREET

SEDALIA, MO

PROJECT # F2307-01

SITE # 1501

ASSET # 3511501153

REVISION: _____

DATE: _____

REVISION: _____

DATE: _____

REVISION: _____

DATE: _____

ISSUE DATE: 11/11/2025

CAD DWG FILE:23117.02-SHEETSBASE

DRAWN BY: DEP

CHECKED BY: CWS

DESIGNED BY: BPH

SHEET TITLE:

SANITARY
DETAILS

SHEET NUMBER:

C-213

24 OF 43


11/11/2025

MISSOURI
STATE FAIRGROUNDS


PROJECT # F2307-01
SITE # 1501
ASSET # 3511501153

CAD DWG FILE: 23117.02-SHEETSBASE
DRAWN BY: DEP
CHECKED BY: CWS
DESIGNED BY: BPH

26 OF 43
11/11/2025

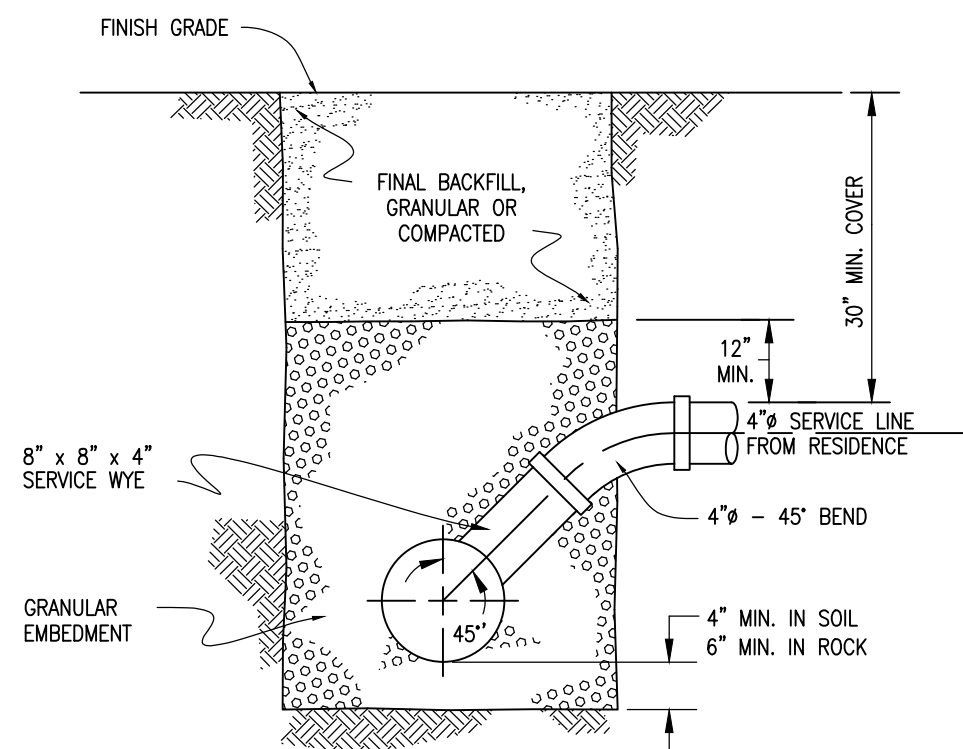


STANDARD SERVICE CONNECTION

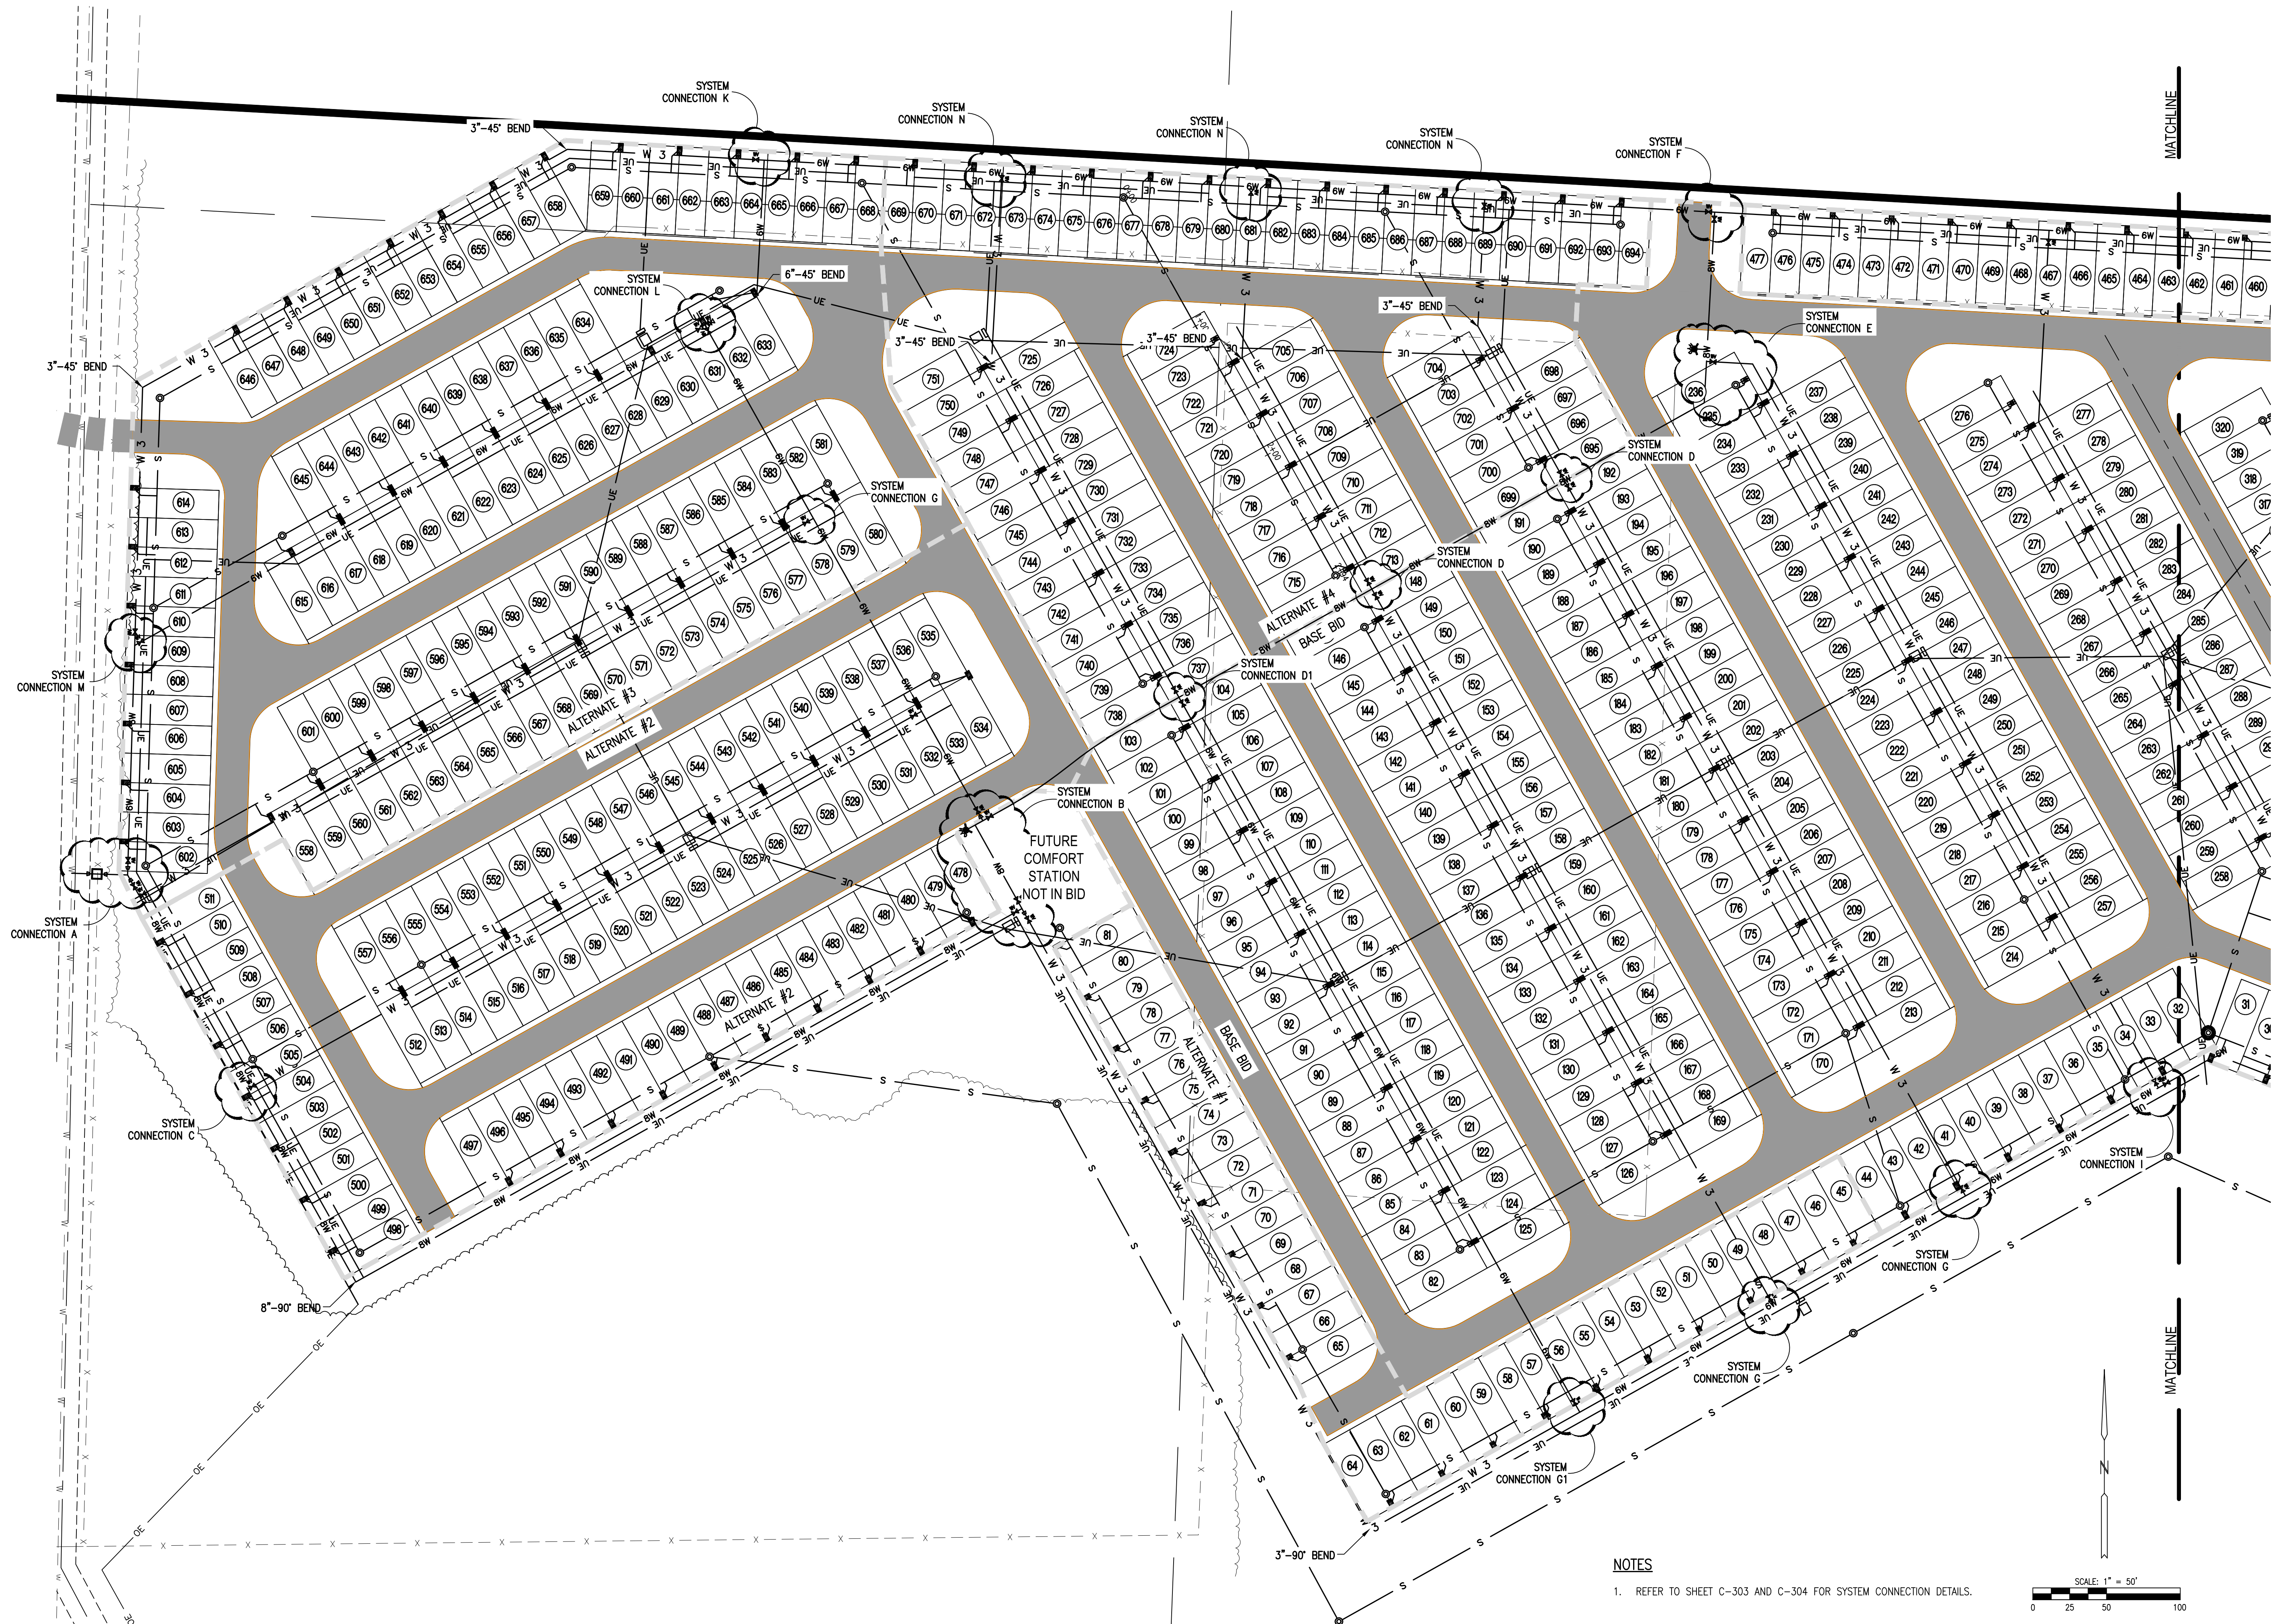

NOTES

1. REFER TO SHEET C-303 AND C-304 FOR SYSTEM CONNECTION DETAILS.

STATE OF MISSOURI
MIKE KEHOE,
GOVERNOR

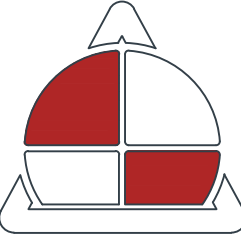

ALLSTATE
CONSULTANTS
allstateconsultants.net

3312 LEMONE INDUSTRIAL BLVD.
COLUMBIA, MO 65201
(573) 875-8799

P.O. BOX 156, 30601 HIGHWAY 5
MARCELINE, MO 64658
(660) 376-2941

410 SE THIRD ST., SUITE 103C
LEE'S SUMMIT, MO 64063
(816) 895-2310

MISSOURI STATE CERTIFICATE
OF AUTHORITY #200704004
REUSE OF THIS DRAWING IN ANY MANNER IS
STRICTLY PROHIBITED WITHOUT THE WRITTEN
APPROVAL OF
ALLSTATE CONSULTANTS LLC

OFFICE OF ADMINISTRATION
DIVISION OF FACILITIES
MANAGEMENT,
DESIGN AND CONSTRUCTION

MISSOURI
STATE FAIRGROUNDS

NEW CAMPGROUND
CONSTRUCTION PLANS

MISSOURI
STATE FAIRGROUNDS
2503 W 16th STREET
SEDALIA, MO

PROJECT # F2307-01
SITE # 1501
ASSET # 3511501153

REVISION: _____
DATE: _____
REVISION: _____
DATE: _____
REVISION: _____
DATE: _____
ISSUE DATE: 11/11/2025

CAD DWG FILE: 231117.02-SHEETSBASE
DRAWN BY: DEP
CHECKED BY: CWS
DESIGNED BY: BPH


SHEET TITLE:
WATERLINE PLAN

SHEET NUMBER:

C-301


27 OF 43
11/11/2025

P:\2023\231117.02 - Campgrounds Expansion\DWG\DESIGN\231117.02-SHEETSBASE.dwg, C-301, WATERLINE, 11/11/2025 1:02:10 PM

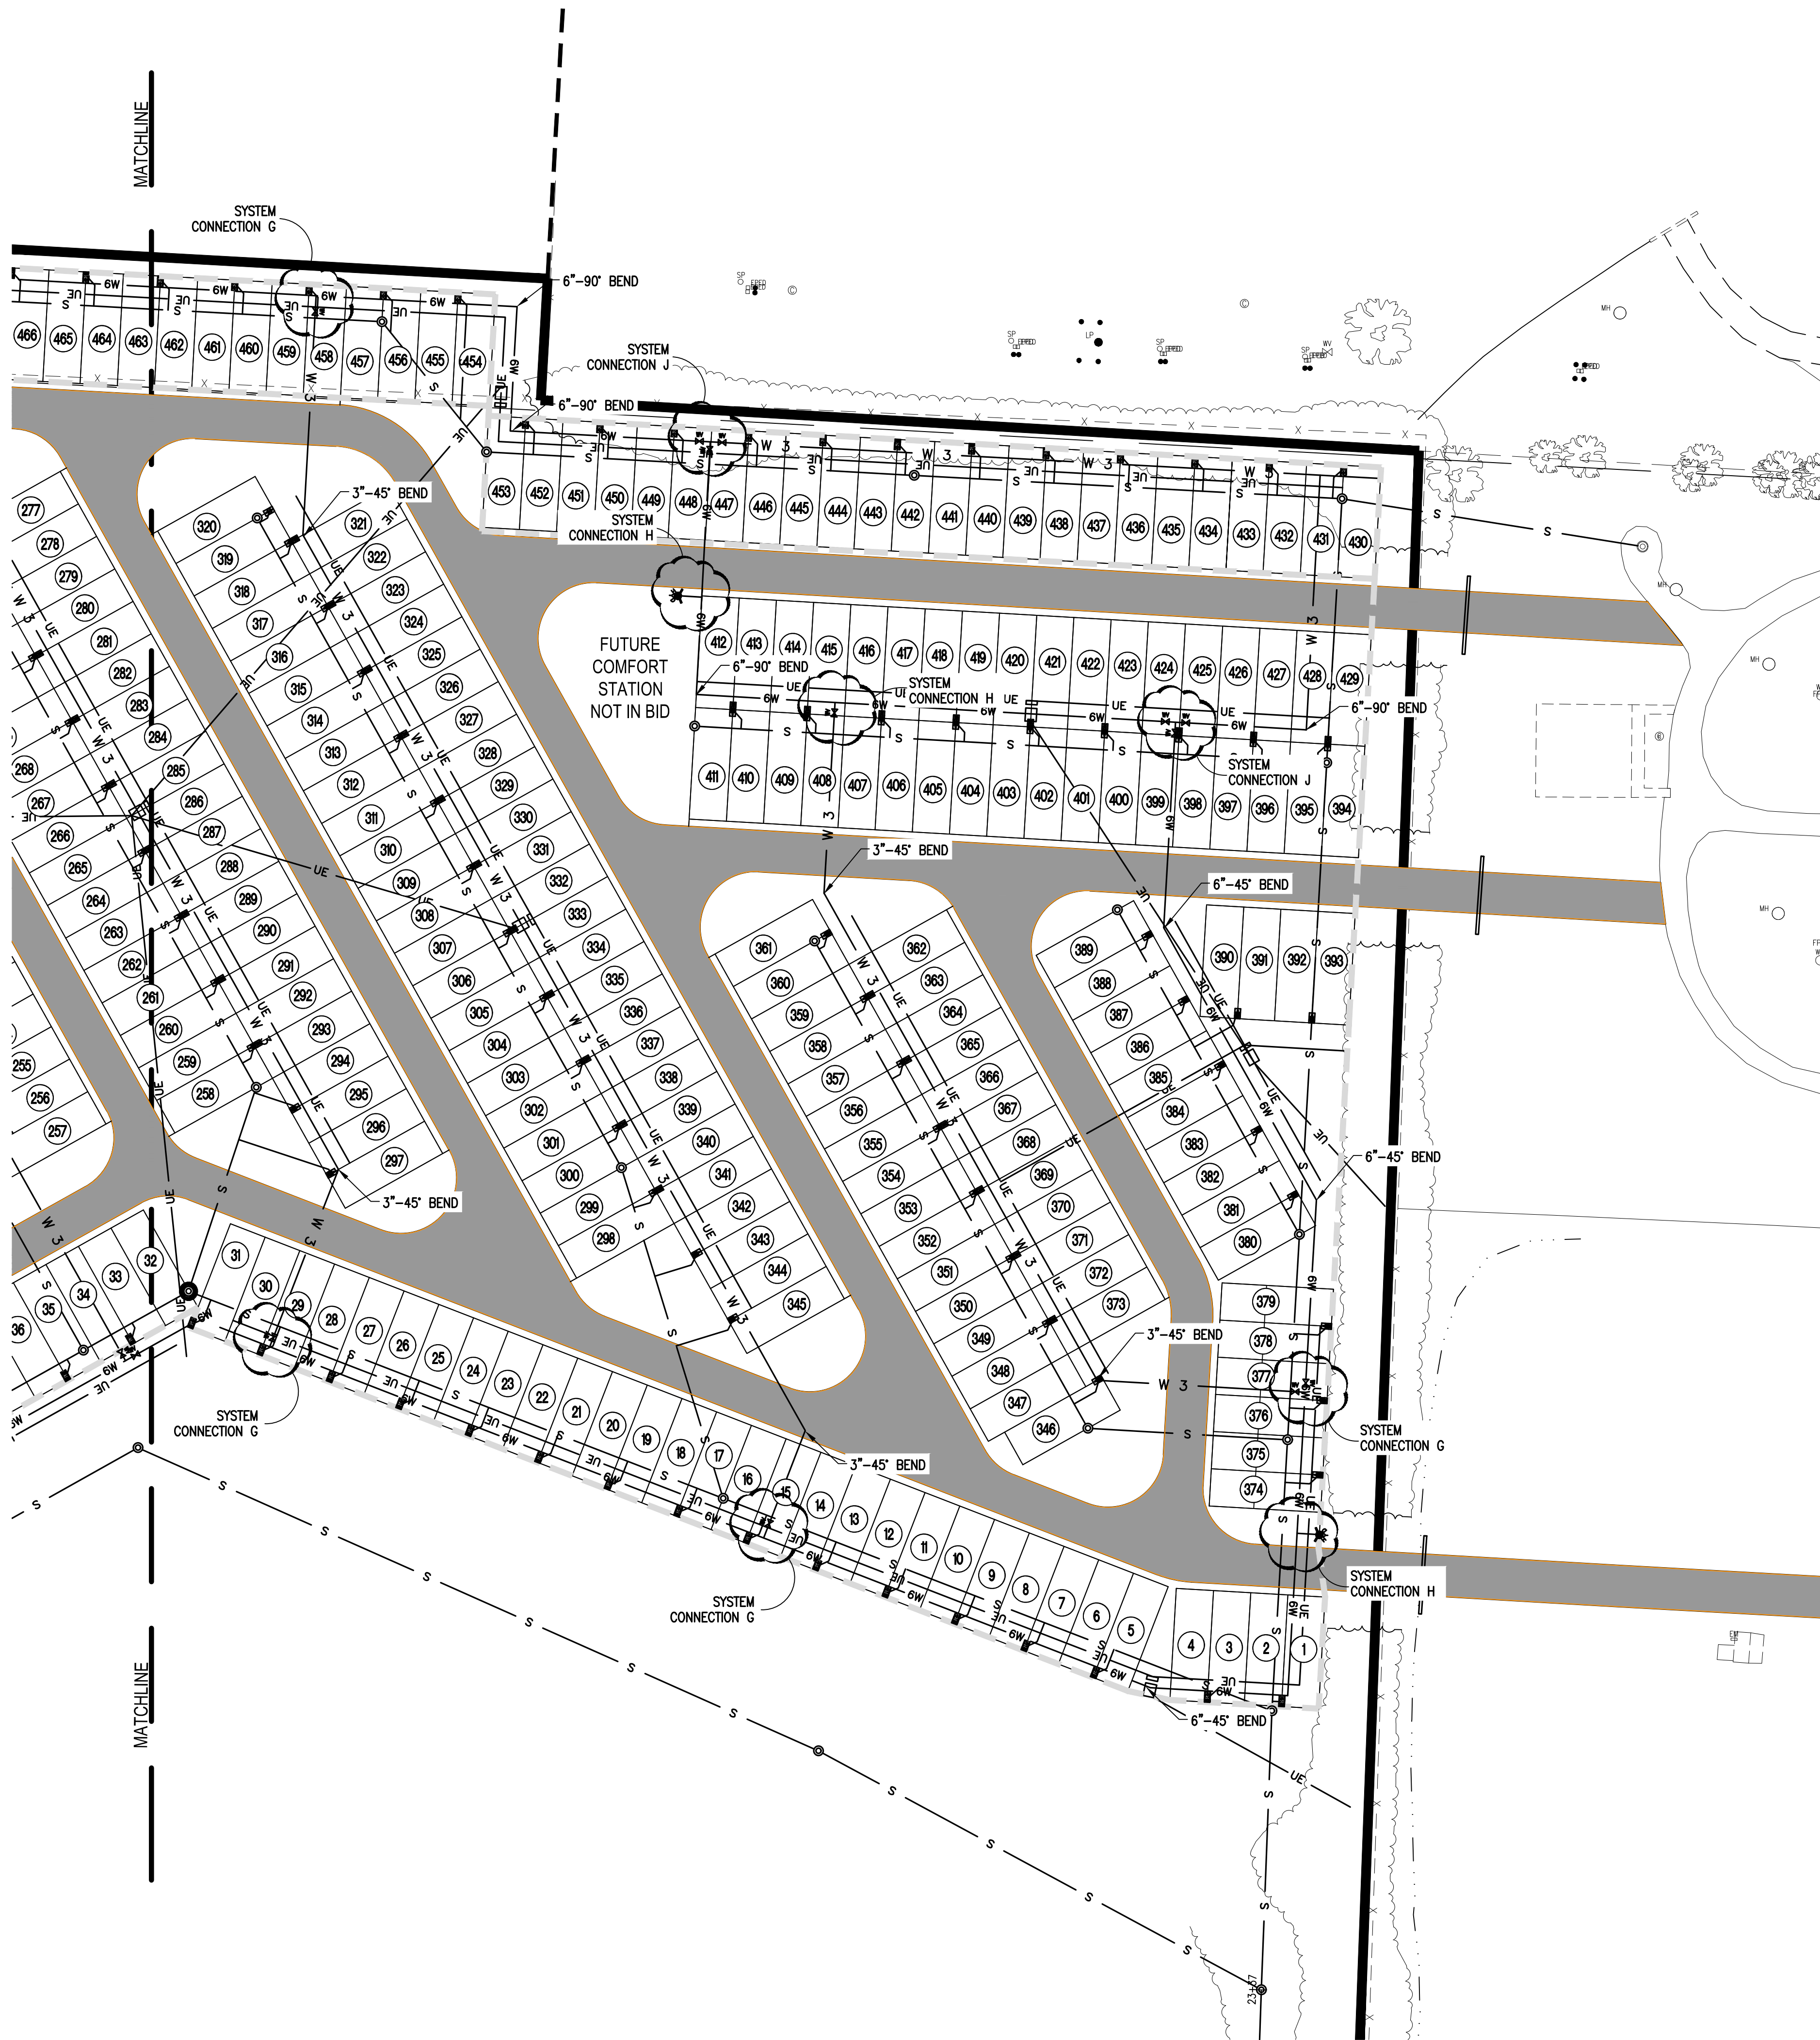


NOTES

1. REFER TO SHEET C-303 AND C-304 FOR SYSTEM CONNECTION DETAILS.

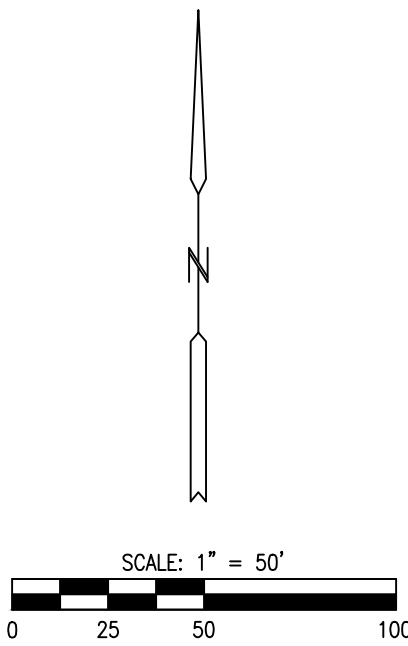

STATE OF MISSOURI
MIKE KEHOE,
GOVERNOR

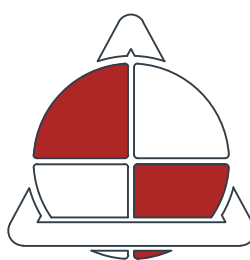

ALLSTATE
CONSULTANTS

allstateconsultants.net

3312 LEMONE INDUSTRIAL BLVD.
COLUMBIA, MO 65201
(573) 875-8799

P.O. BOX 156, 30601 HIGHWAY 5
MARCELINE, MO 64658
(660) 376-2941

410 SE THIRD ST., SUITE 103C
LEE'S SUMMIT, MO 64063
(816) 895-2310

MISSOURI STATE CERTIFICATE
OF AUTHORITY #2007004004
REUSE OF THIS DRAWING IN ANY MANNER IS
STRICTLY PROHIBITED WITHOUT THE WRITTEN
APPROVAL OF
ALLSTATE CONSULTANTS LLC

OFFICE OF ADMINISTRATION
DIVISION OF FACILITIES
MANAGEMENT,
DESIGN AND CONSTRUCTION

MISSOURI
STATE FAIRGROUNDS

NEW CAMPGROUND
CONSTRUCTION PLANS

MISSOURI
STATE FAIRGROUNDS
2503 W 16th STREET
SEDALIA, MO

PROJECT # F2307-01
SITE # 1501
ASSET # 3511501153

REVISION: _____
DATE: _____
REVISION: _____
DATE: _____
REVISION: _____
DATE: _____
ISSUE DATE: 11/11/2025

CAD DWG FILE: 231117.02-SHEETSBASE
DRAWN BY: DEP
CHECKED BY: CWS
DESIGNED BY: BPH

 
 
 
 
 
 
 
 
SHEET TITLE:
WATERLINE PLAN



SHEET NUMBER:

C-302

28 OF 43
11/11/2025

P:\2023\231117.02 - Campgrounds Expansion\DWG\DESIGN\231117.02-SHEETSBASE.dwg, C-302 WATERLINE, 11/11/2025 1:02:44 PM



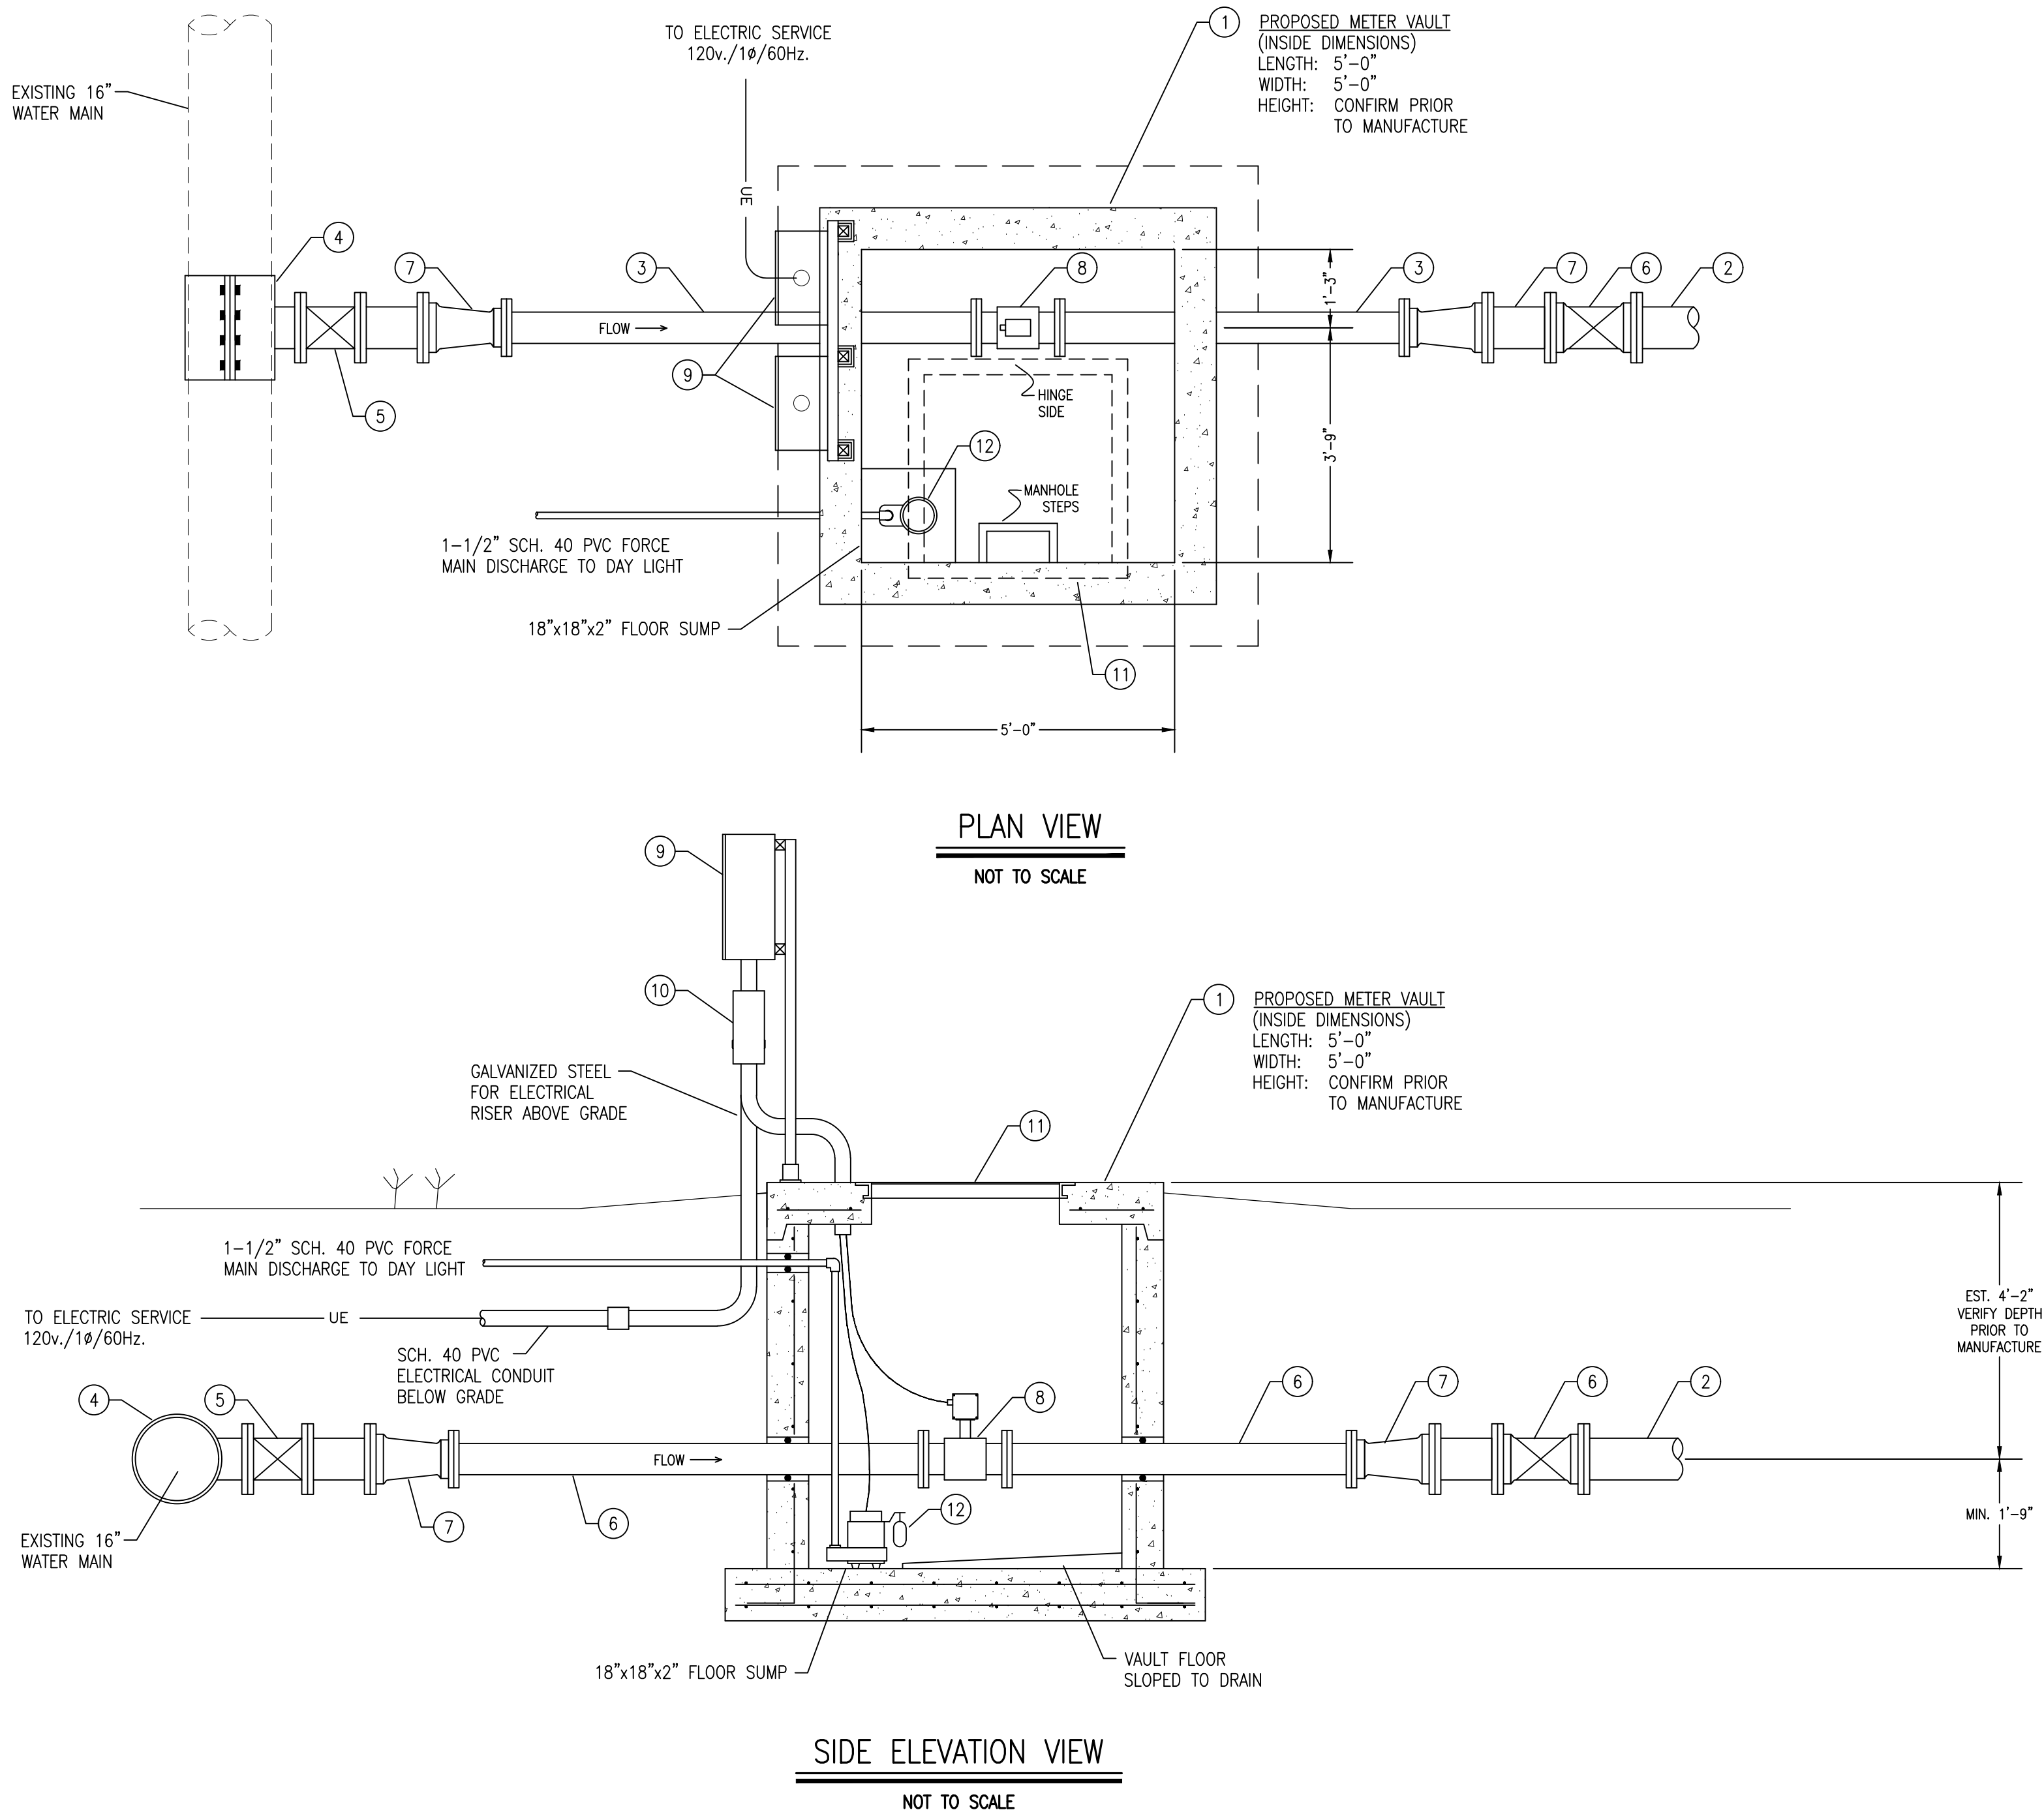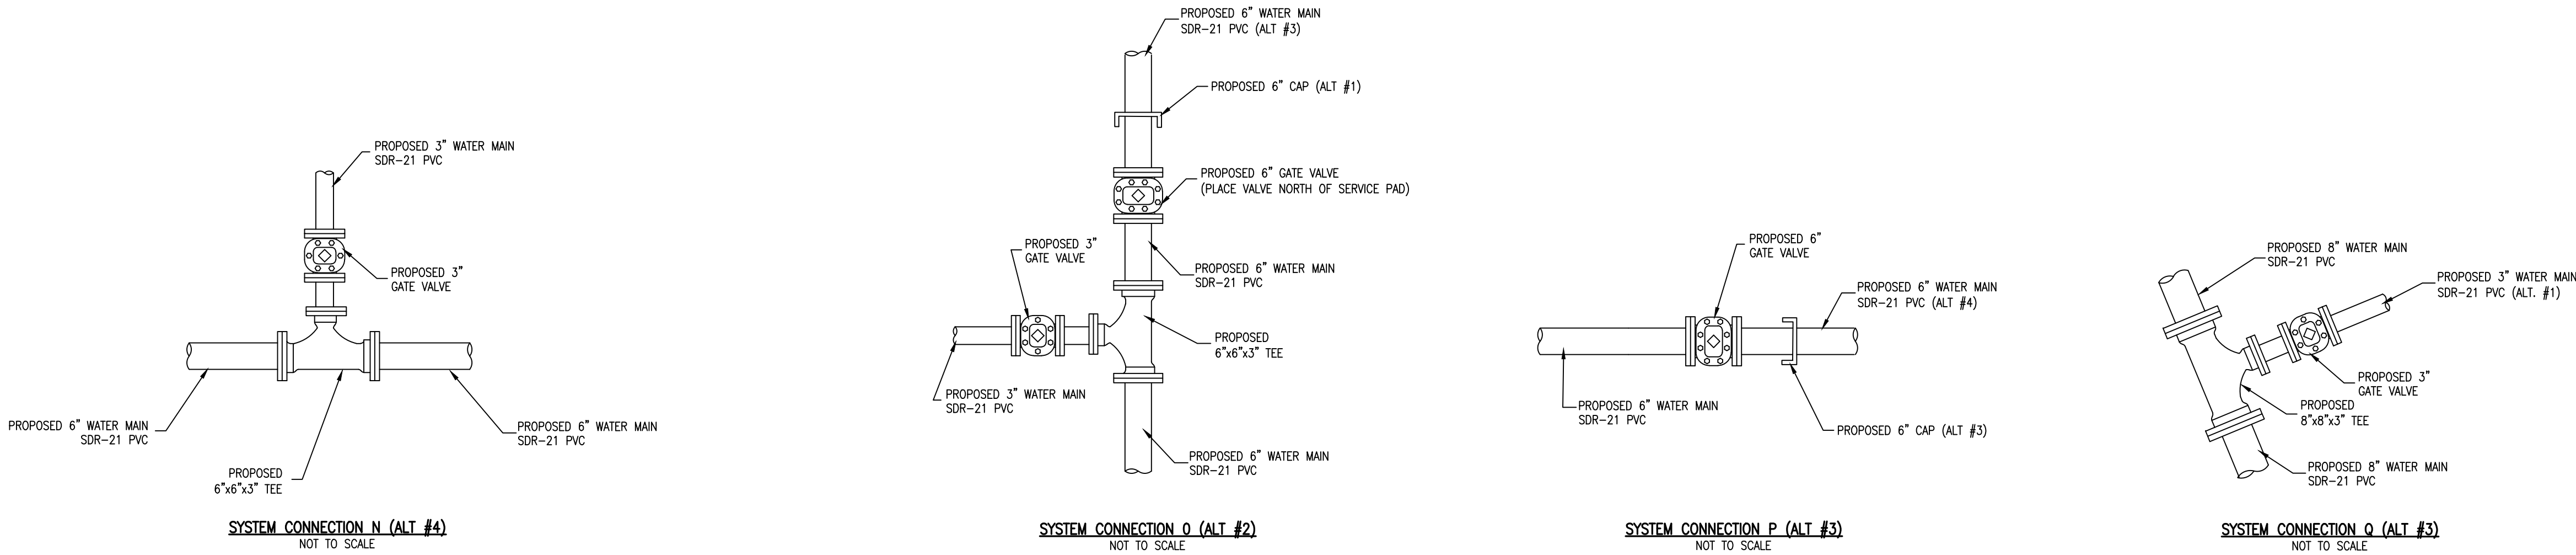


ITEM	DESCRIPTION	SIZE	MATERIAL
1	CONCRETE METER VAULT	SEE DETAIL	PRECAST CONCRETE
2	PVC PIPE PIPE	8"	DUCTILE IRON
3	DUCTILE IRON PIPE	6"	DUCTILE IRON
4	TAPPING SLEEVE	16"x8"	STAINLESS STEEL
5	TAPPING VALVE	8"	DUCTILE IRON
6	GATE VALVE	8"	DUCTILE IRON
7	REDUCER	8"x6"	DUCTILE IRON
8	ELECTROMAGNETIC FLOW METER	8"	DUCTILE IRON
9	ELECTRICAL RACK FOR ELECTRICAL PANELS, REMOTE METER MOUNT, & TELEMETRY PANEL (NEMA 4X REQ'D)	AS REQ'D.	-
10	JUNCTION BOX (NEMA 4X)	AS REQ'D.	-
11	VAULT HATCH (HALLIDAY SERIES S1S)	36"x36"	ALUMINUM
12	SUMP PUMP	-	-

NOTES

- ALL ELECTRIC WORK SHALL COMPLY WITH NATIONAL ELECTRIC CODE.
- ALL ELECTRIC PANELS SHALL BE NEMA 4X RATED.
- ALL PANELS SHALL BE SECURED USING A UNI-STRUT FRAME SECURELY ATTACHED TO CONCRETE USING A MINIMUM OF TWO VERTICALS AND TWO HORIZONTAL STRUTS.
- ALL ELECTRICAL SERVICE DROPS SHALL BE GALVANIZED ABOVE GROUND. SCH. 40 CONDUIT SHALL BE USED FOR BURIED SERVICE LINE.
- A 110 VOLT OUTLET SHALL BE PROVIDED AT THE ELECTRICAL RACK.
- FLOW METER SHALL BE BADGER M-SERIES (2000) OR EQUIVALENT WITH SUBMERGED PROTECTION AND REMOTE READ INCLUDED IN NEW ELECTRICAL PANEL (NEMA 4X) ON EXTERIOR OF DRY VAULT.
- ALL FASTENERS SHALL BE STAINLESS STEEL.
- SHOP DRAWINGS AND LOADING CALCULATIONS FOR PRECAST CONCRETE VAULT SHALL BE PROVIDED TO THE ENGINEER AND MUST BE SIGNED AND SEALED BY A REGISTERED PROFESSIONAL ENGINEER IN THE STATE OF MISSOURI. ROUND STRUCTURES SHALL CONFORM TO ASTM C478 AND ASTM C497 AND RECTANGULAR/SQUARE STRUCTURES SHALL CONFORM TO ASTM C913 AND ASTM C890. PORTLAND CEMENT CONCRETE SHALL CONFORM TO REQUIREMENTS OF THE CURRENT MODOT STANDARD SPECIFICATIONS FOR HIGHWAY CONSTRUCTION (MSSHC), SECTION 501, FOR CLASS B-1 AIR-ENTRAINED CONCRETE AND ALL OTHER SECTIONS AS REFERENCED IN THE MODOT MSSHC UNLESS OTHERWISE SPECIFIED BY THE ENGINEER. JOINTS SHALL BE SEALED WITH AN EXTERNAL RUBBER SLEEVE, GATOR WRAP OR EQUIVALENT.
- ALL PIPE PENETRATIONS AND CONDUIT SHALL BE SEALED WITH GASKETS, NON-SHRINK GROUT, ELECTRICAL DUCT SEAL PUTTY, OR AS REQUIRED TO PREVENT WATER INFILTRATION.
- SUMP PUMP SHALL BE ZOELLER MODEL 53, 0.3 HP, 115 VOLT, SINGLE PHASE, OR EQUIVALENT.

STATE OF MISSOURI
MIKE KEHOE,
GOVERNOR

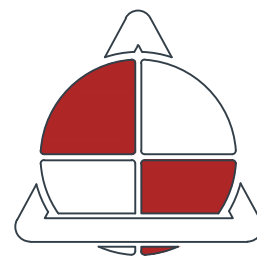

ALLSTATE
CONSULTANTS
allstateconsultants.net

3312 LEMONE INDUSTRIAL BLVD.
COLUMBIA, MO 65201
(573) 875-8799

P.O. BOX 156, 30601 HIGHWAY 5
MARCELINE, MO 64658
(660) 376-2941

410 SE THIRD ST., SUITE 103C
LEE'S SUMMIT, MO 64063
(816) 895-2310

MISSOURI STATE CERTIFICATE
OF AUTHORITY #2007004004
REUSE OF THIS DRAWING IN ANY MANNER IS
STRICTLY PROHIBITED WITHOUT THE WRITTEN
APPROVAL OF
ALLSTATE CONSULTANTS LLC

OFFICE OF ADMINISTRATION
DIVISION OF FACILITIES
MANAGEMENT,
DESIGN AND CONSTRUCTION

MISSOURI
STATE FAIRGROUNDS

NEW CAMPGROUND
CONSTRUCTION PLANS

MISSOURI
STATE FAIRGROUNDS
2503 W 16th STREET
SEDALIA, MO

PROJECT # F2307-01
SITE # 1501
ASSET # 3511501153

REVISION: _____
DATE: _____
REVISION: _____
DATE: _____
REVISION: _____
DATE: _____
ISSUE DATE: 11/11/2025

CAD DWG FILE: 23117.02-SHEETSBASE
DRAWN BY: DEP
CHECKED BY: CWS
DESIGNED BY: BPH

SHEET TITLE:
**WATERLINE
DETAILS**

SHEET NUMBER:

C-304

30 OF 43
11/11/2025




MISSOURI STATE CERTIFICATE
OF AUTHORITY #2007004004
REUSE OF THIS DRAWING IN ANY MANNER IS
STRICTLY PROHIBITED WITHOUT THE WRITTEN
APPROVAL OF
ALLSTATE CONSULTANTS LLC

MISSOURI
STATE FAIRGROUNDS


REVISION: _____
DATE: _____
REVISION: _____
DATE: _____
REVISION: _____
DATE: _____
ISSUE DATE: 11/11/2025

C-305


P:\2023\23117.02 - Campgrounds Expansion\DWG\DESIGN\23117.02-SHEETSBASE.dwg, C-305 WATER, 11/11/2025 1:03:39 PM

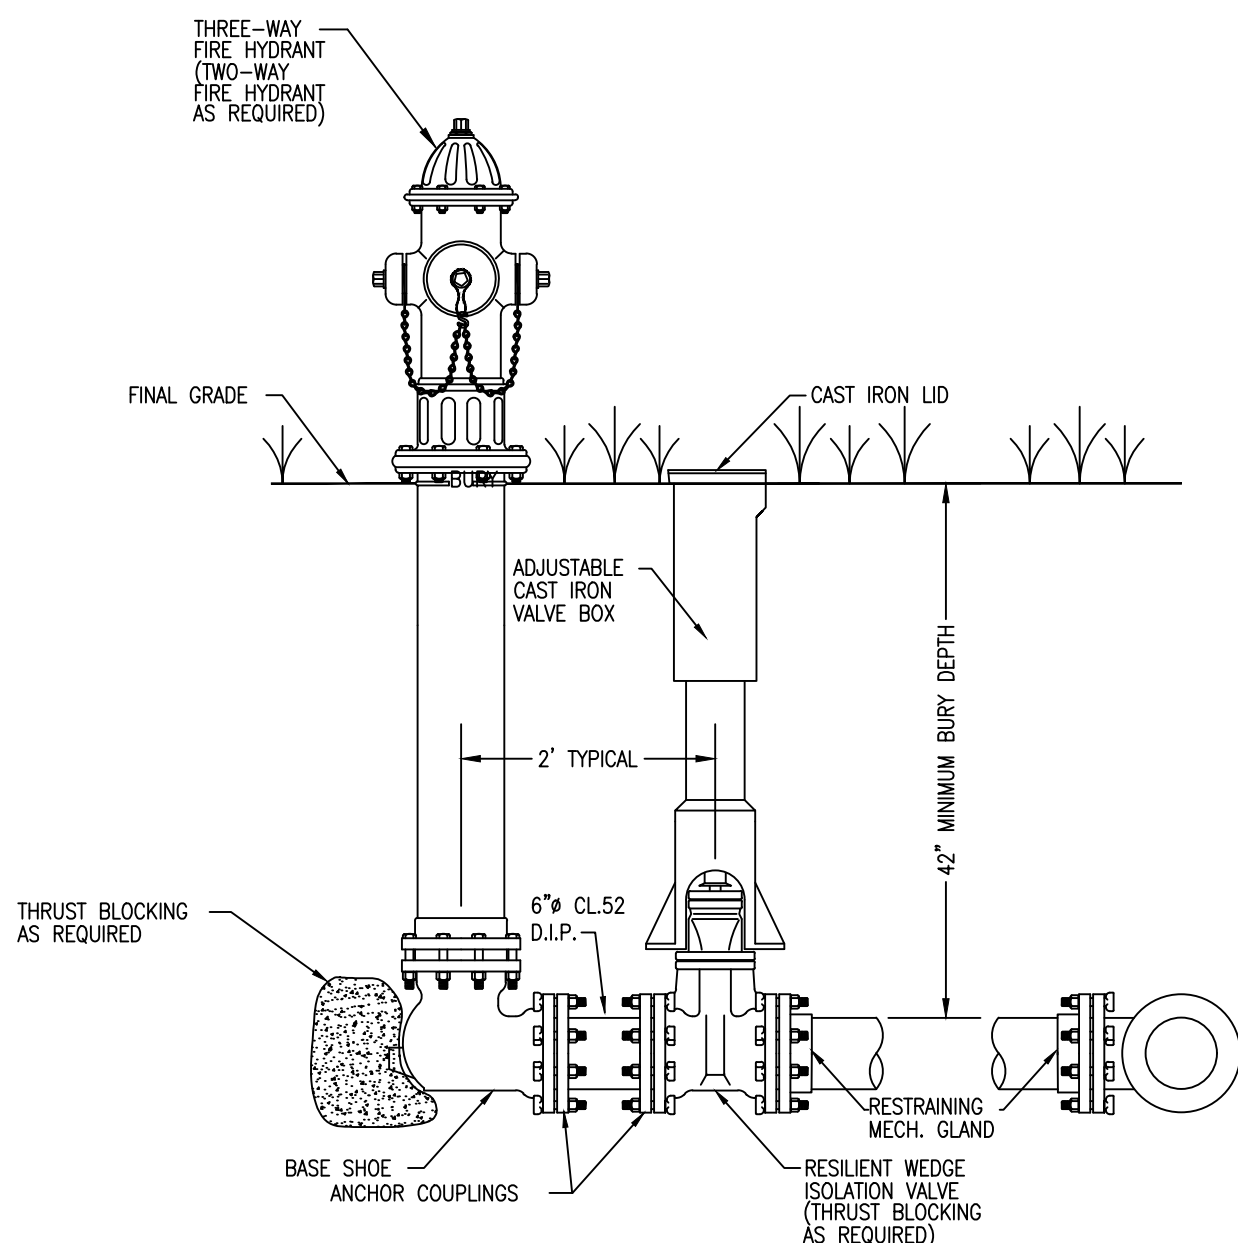

CONTRACTOR SHALL INCLUDE PIPE SPOOL, VALVE, VALVE BOX AND ALL NECESSARY APPURTENANCES IN THE BID PRICE FOR THE FIRE HYDRANT SETTING.

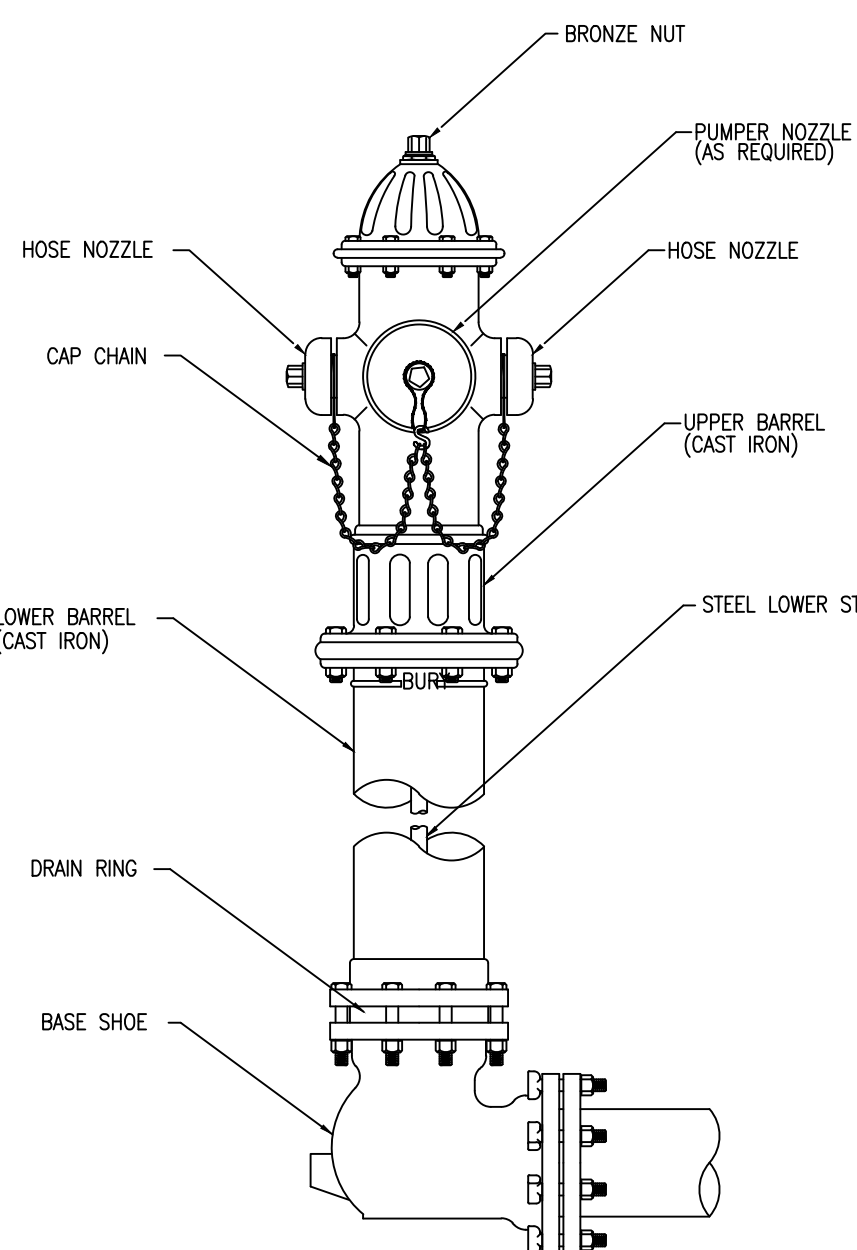

FIRE HYDRANTS SHALL BE THREE-WAY HYDRANTS
UNLESS SPECIFIED ON PLANS OR BY ENGINEER.
FIRE HYDRANT SHALL BE MUELLER, CLOW, OR AMERICAN.

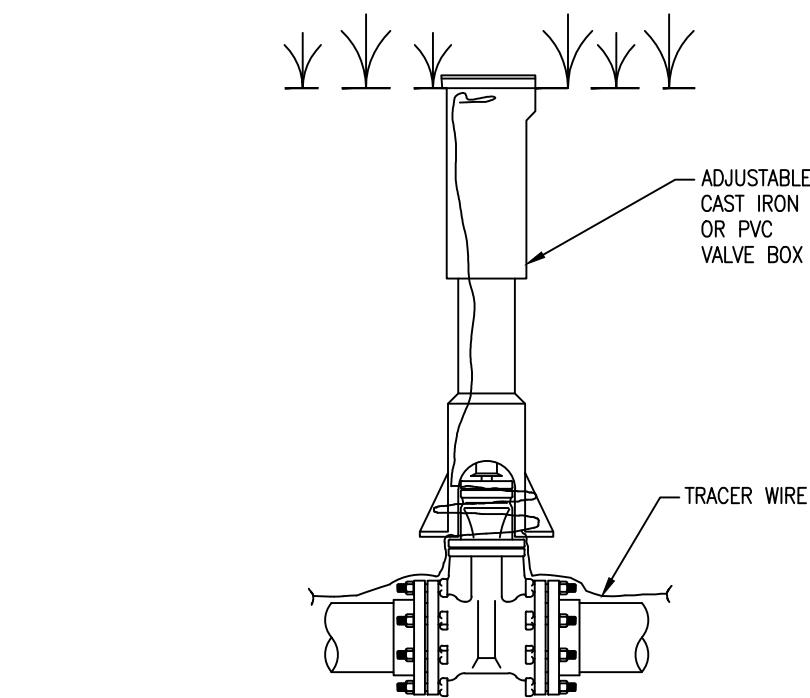

CONTRACTOR NOTE
ANTI-SEEP COLLARS
SHALL BE REQUIRED
@ 160' INTERVALS
MAXIMUM.

PIPE DIA.	MIN. TRENCH WIDTH
2"-4"	PIPE DIA. + 4"
6"-8"	PIPE DIA. + 10"

42" MIN.

6" MIN.

TOP OF PIPE

FINISH GRADE

(2') 3/4" CLEAN LIMESTONE
(6") 2-3" LIMESTONE BASE

FINAL BACKFILL COMPACTED
TO 95% S.P.D.

INITIAL BACKFILL; HAND PLACED
EXCAVATED MATERIAL WITH NO ROCK

TRACER WIRE TAPED
TO TOP OF PIPE


1/2" CRUSHED ROCK LEVELING
COURSE UNDER PIPE OR AS
RECOMMENDED BY PIPE
MANUFACTURER

UNDISTURBED SOIL
OR ROCK

THRUST BLOCKS SHOWN ARE BASED UPON SOIL PRESSURE-3000 POUNDS/SQUARE FOOT. ACTUAL FIELD CONDITIONS MAY VARY. MINIMUM DIAMETER AND THICKNESS SHALL BE ONE FOOT UNLESS OTHERWISE APPROVED BY ENGINEER. ALL DUCTILE IRON FITTINGS, VALVES, ETC., SHALL BE PLASTIC WRAPPED TO KEEP CONCRETE FROM COMING INTO CONTACT WITH FITTING.

TYPICAL EMBEDMENT DETAIL FOR ALL DUCTILE
IRON AND PVC PIPING LOCATED UNDER
AGGREGATE SURFACES.

TAPPING SLEEVE ASSEMBLY AS SHOWN
REQ'D. FOR ALL WET CONNECTIONS.

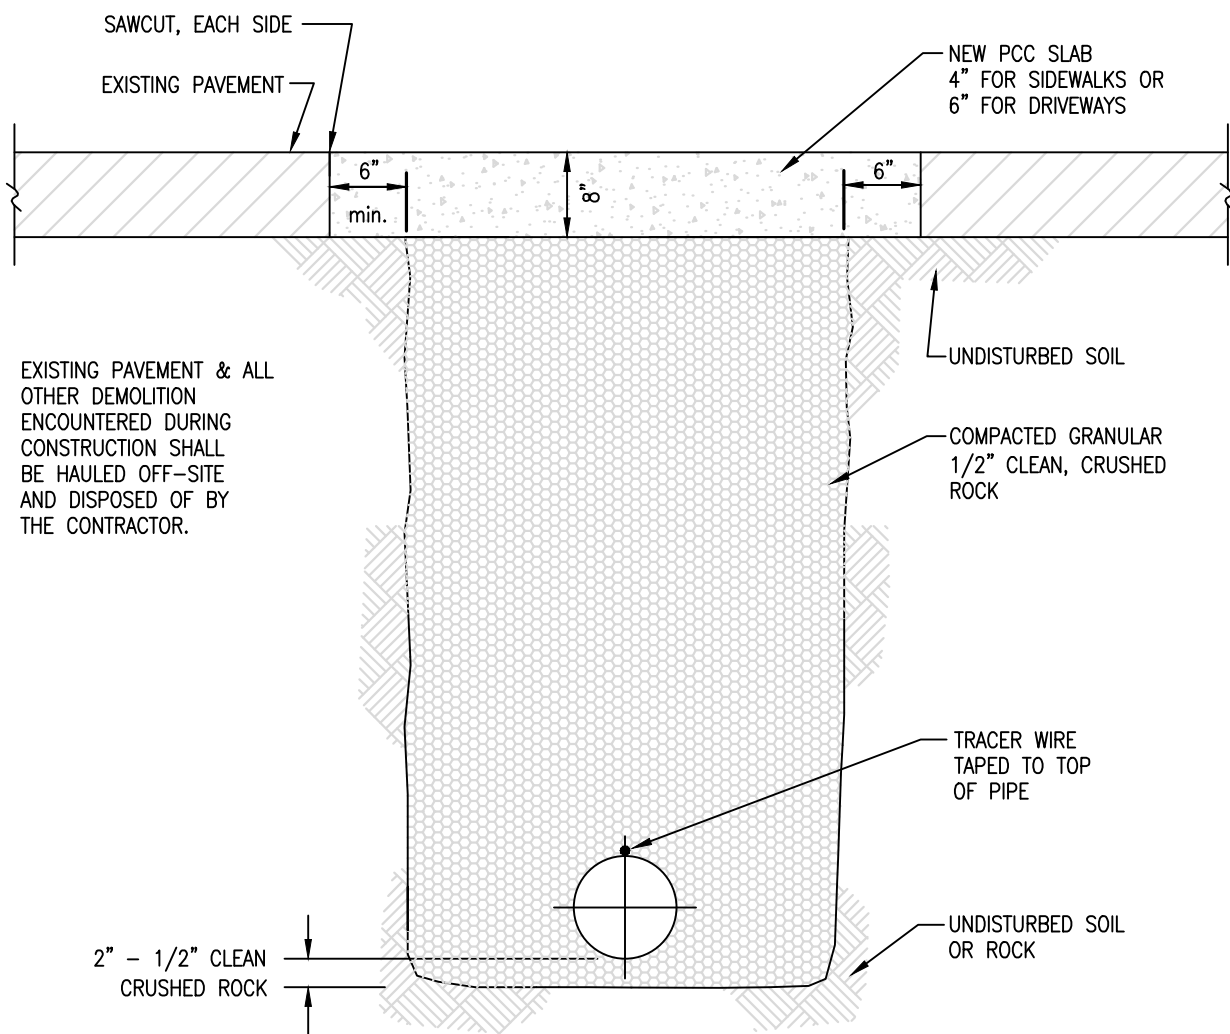

EXISTING WATERMAIN (CAST, DUCTILE, PVC, C-900 PVC)

STAINLESS STEEL TAPPING SLEEVE

TAPPING VALVE (FL x MJ)


PROPOSED WATERMAIN SIZE AS NOTED

FLANGED OUTLET FOR TAPPING VALVE












STAINLESS STEEL TAPPING SLEEVE

SIZE OF TAPPING SLEEVE SHALL BE AS STATED ON PLAN SHEETS TO BE VERIFIED AND ADJUSTED AS NECESSARY BY CONTRACTOR FOR ACTUAL CONDITIONS.

GATE VALVES SHALL BE RESILIENT WEDGE VALVES w/MECHANICAL JOINT ENDS, OR ENGINEER APPROVED EQUIVALENT.

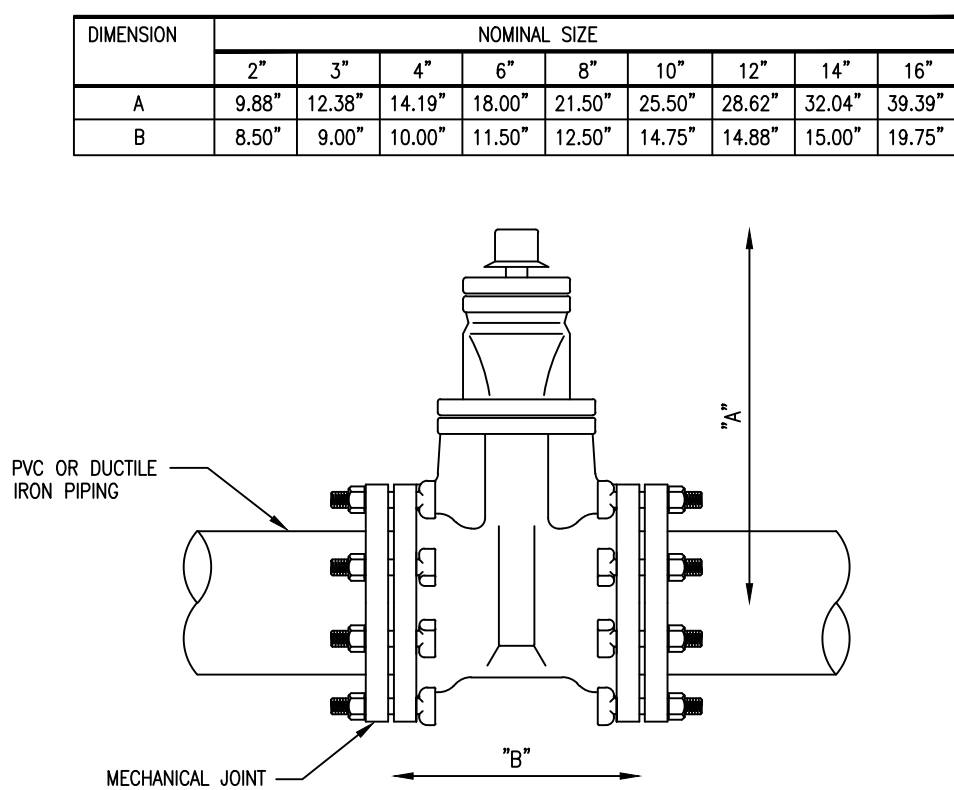


          T:\job\24\2404\1\24041.dwg, 1/17/2025 12:30:25 PM, JoshB

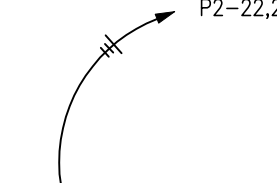ELECTRICAL SYMBOL SCHEDULE	
	HOME RUN CIRCUIT TO PANEL P2, CIRCUITS 22,24
	EACH ARROW INDICATES ONE CIRCUIT
	SHORT HATCH MARKS INDICATE # OF PHASE CONDUCTORS
	LONG HATCH MARKS INDICATE # OF NEUTRAL CONDUCTORS
	NO HATCH MARK INDICATES TWO CONDUCTORS
	ELECTRICAL SERVICE OR FEEDER WIRING
	WIRING IN WALL OR CEILING - WIRING IN FLOOR
	RECEPTACLE OUTLET (DUPLEX - QUADRUPLX - SPECIAL POWER)
	COMMUNICATIONS OUTLET (TELEPHONE - CATV - DATA/PHONE)
	WALL SWITCH (3-WAY - DIMMER - 4-WAY - PILOT - SPEED - KEYED - TIMER - OCCUPANCY)
	LED STYLE LIGHT FIXTURE (CEILING MOUNTED - WALL MOUNTED)
	LED STYLE LIGHT FIXTURE (ENCLOSED - STRIP) (S INDICATES SPLIT WIRED)
	EXIT LIGHT - EMERGENCY LIGHT - EMERGENCY/EXIT LIGHT
	OTHER RECEPTACLE OUTLET (CLOCK - FLOOR - SPLIT WIRED)
	ELECTRIC PANEL
	SPEAKER - PUSH TO TALK
	JUNCTION BOX - PULL BOX
	DISCONNECT (FUSED - NONFUSED)
	STARTER - CONTACTOR
	ELECTRIC MOTOR (5 HP - 208V - 3 PHASE)
	THERMOSTAT - HUMIDISTAT (ZONE SUBSCRIPT)
	OUTLET MODIFIERS (MOUNT HEIGHT INCHES - GFI PROTECTED - WEATHER PROOF GFI - USB)
	SMOKE DETECTOR - HEAT DETECTOR - DUCT DETECTOR - MANUAL PULL STATION
	AUDIO VISUAL - VISUAL
	MAGNETIC DOOR HOLDER - INTERLOCK RELAY
	END OF LINE RESISTOR
	FIRE ALARM CONTROL PANEL
	DIALER


SINGLE CAMPSITE WIRE SIZE CHART		
WIRE SIZE (CU)	MINIMUM LENGTH OF CIRCUIT	MAXIMUM LENGTH OF CIRCUIT
3 #2	-	260'
3 #1	260'	325'
3 #1/0	325'	410'
3 #2/0	410'	520'
3 #3/0	520'	655'
3 #4/0	655'	825'
3 #250MCM	825'	975'
3 #300MCM	975'	>975'

DOUBLE CAMPSITE WIRE SIZE CHART		
WIRE SIZE (CU)	MINIMUM LENGTH OF CIRCUIT	MAXIMUM LENGTH OF CIRCUIT
3 #2/0	-	260'
3 #3/0	260'	325'
3 #4/0	325'	410'
3 #250MCM	410'	485'
3 #300MCM	485'	585'
3 #350MCM	585'	685'
3 #400MCM	685'	780'
3 #500MCM	780'	975'
3 #600MCM	975'	>975'

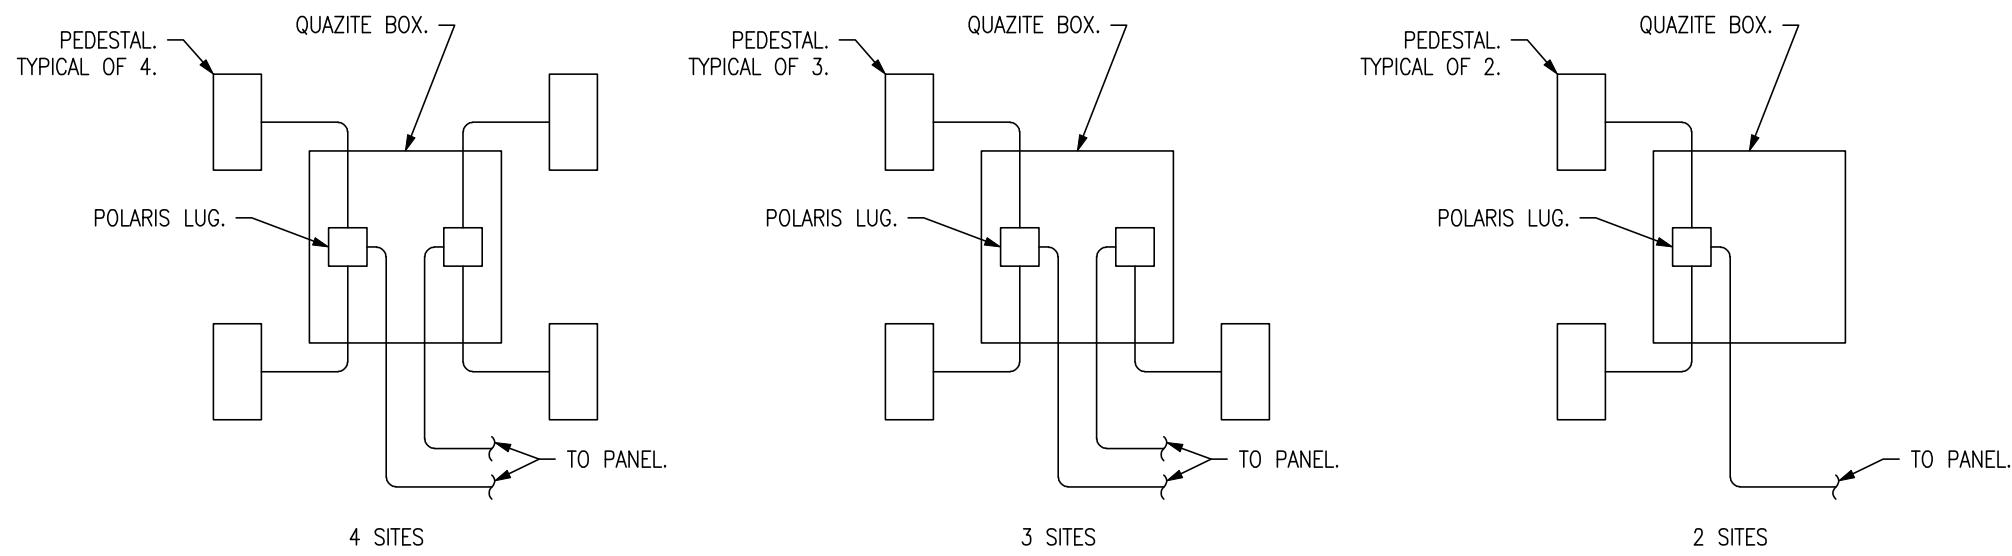

1 PEDESTAL WIRING DIAGRAM
ME1 NO SCALE

STATE OF MISSOURI
MIKE KEHOE,
GOVERNOR

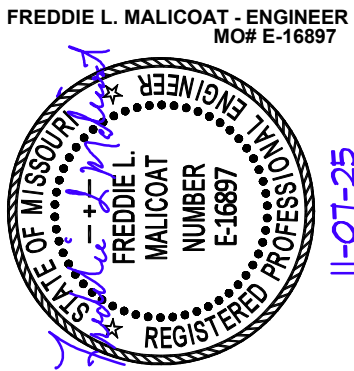

MALICOAT - WINSLOW
ENGINEERS, INC.
MISSOURI STATE CERTIFICATE OF AUTHORITY #000421
4840 RANGELINE STREET, #101 TEL 573-875-1300
COLUMBIA, MISSOURI 65202
FREDDIE MALICOAT, P.E.

OFFICE OF ADMINISTRATION
DIVISION OF FACILITIES
MANAGEMENT,
DESIGN AND CONSTRUCTION

MISSOURI
STATE FAIRGROUNDS

NEW CAMPGROUND
CONSTRUCTION PLANS

MISSOURI
STATE FAIRGROUNDS
2503 W 16th STREET
SEDALIA, MO

PROJECT # F2307-01
SITE # 1501
ASSET # 3511501153

REVISION: _____
DATE: _____
REVISION: _____
DATE: _____
REVISION: _____
DATE: _____

ISSUE DATE: _____

CAD DWG FILE: M-PLN-01
DRAWN BY: JDB
CHECKED BY: FM
DESIGNED BY: FM

SHEET TITLE:

SCHEDULES &
SPECIFICATIONS

SHEET NUMBER:


ME1

32 OF 43
11/11/2025

1. REFER TO PANEL SCHEDULES ON SHEETS E9-E11 FOR BREAKER SIZES.
2. REFER TO CAMPGROUND ELECTRIC SERVICES TABLE ON SHEET ME1 FOR RECOMMENDED MINIMUM WIRE SIZES AND LENGTHS.
3. WIRE SIZES ASSUME COPPER WIRE.
4. ALL TRANSFORMERS TO BE 15KV TO 208V, 3Ø TRANSFORMERS PER EVERY REQUIREMENTS
5. SEE PANEL SCHEDULES ON SHEETS E9-E11 AND SHEET C-003 FOR ALTERNATE SCHEDULE



FREDDIE L. MALICOAT - ENGINEER
MO# E 16897

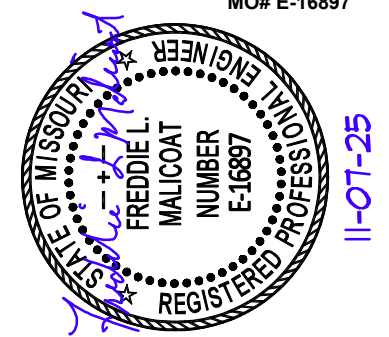

MISSOURI STATE CERTIFICATE OF AUTHORITY #000421

MISSOURI STATE CERTIFICATE OF ADOPTION # 000421
4840 RANGELINE STREET. #101
TEL 573-875-1300

FREDDIE MALICOAT, P.E.

MISSOURI
STATE FAIRGROUNDS

MISSOURI
STATE FAIRGROUNDS
2503 W 16th STREET
SEDALIA, MO

PROJECT #	F2307-01
SITE #	1501
ASSET #	3511501153

REVISION: _____
DATE: _____
REVISION: _____
DATE: _____
REVISION: _____
DATE: _____
ISSUE DATE: _____

CAD DWG FILE: E-PLN-01
 DRAWN BY: JDB
 CHECKED BY: FM
 DESIGNED BY: FM

SHEET TITLE:

CAMP SITE ELECTRIC PLAN


SHEET NUMBER:

E1

33 OF 43
11/11/2025


T:\job\24\2404\1\24041.dwg, 11/7/2025 12:33:23 PM, JoshB

- NOTE:
1. REFER TO PANEL SCHEDULES ON SHEETS E9-E11 FOR BREAKER SIZES.
 2. REFER TO CAMPGROUND ELECTRIC SERVICES TABLE ON SHEET ME1 FOR RECOMMENDED MINIMUM WIRE SIZES AND LENGTHS.
 3. WIRE SIZES ASSUME COPPER WIRE.
 4. ALL TRANSFORMERS TO BE 15KV TO 208V, 3Ø TRANSFORMERS PER EVERY REQUIREMENTS
 5. SEE PANEL SCHEDULES ON SHEETS E9-E11 AND SHEET C-003 FOR ALTERNATE SCHEDULE.

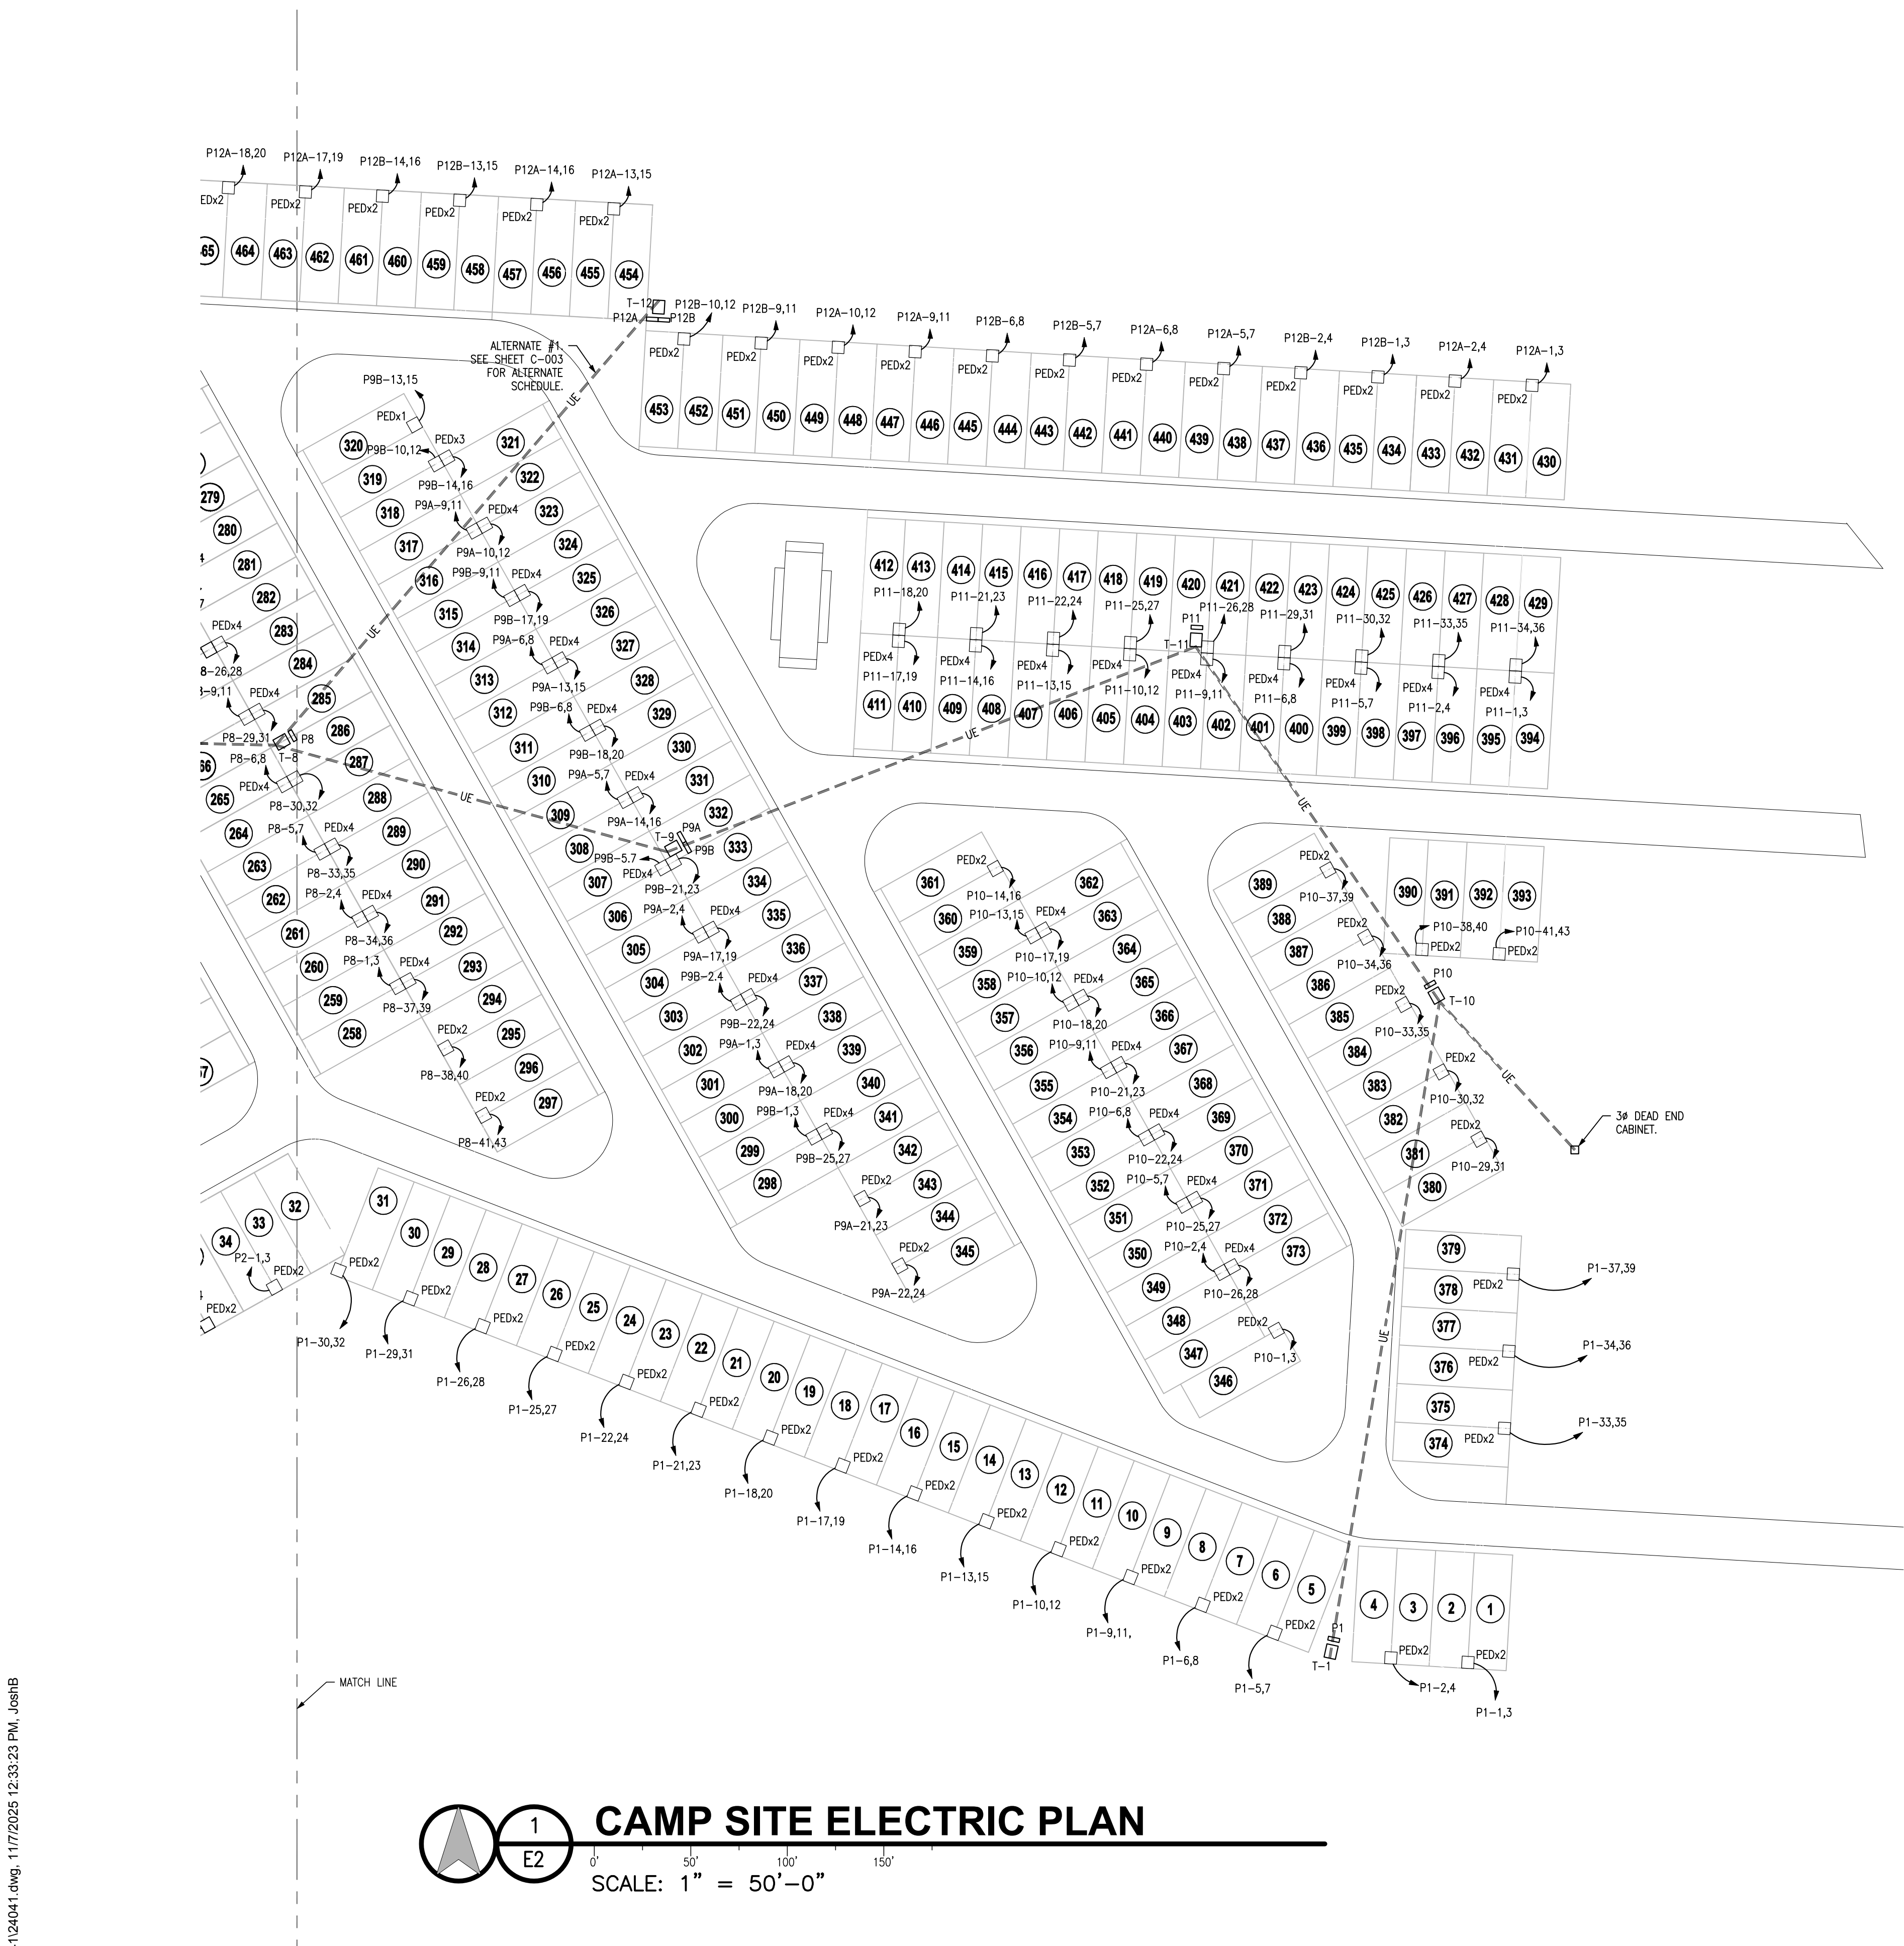


T:\Job02420401\24041.dwg, 11/7/2025 12:30:14 PM, JoshB


- NOTE:
1. REFER TO PANEL SCHEDULES ON SHEETS E9-E11 FOR BREAKER SIZES.
2. REFER TO CAMPGROUND ELECTRIC SERVICES TABLE ON SHEET ME1 FOR RECOMMENDED MINIMUM WIRE SIZES AND LENGTHS.
3. WIRE SIZES ASSUME COPPER WIRE.
4. ALL TRANSFORMERS TO BE 15KV TO 208V, 3Ø TRANSFORMERS PER EVERY REQUIREMENTS
5. DASHED ITEMS DENOTES THEY ARE AN ALTERNATE. SEE PANEL SCHEDULES ON SHEETS E9-E11 AND SHEET C-003 FOR ALTERNATE SCHEDULE.

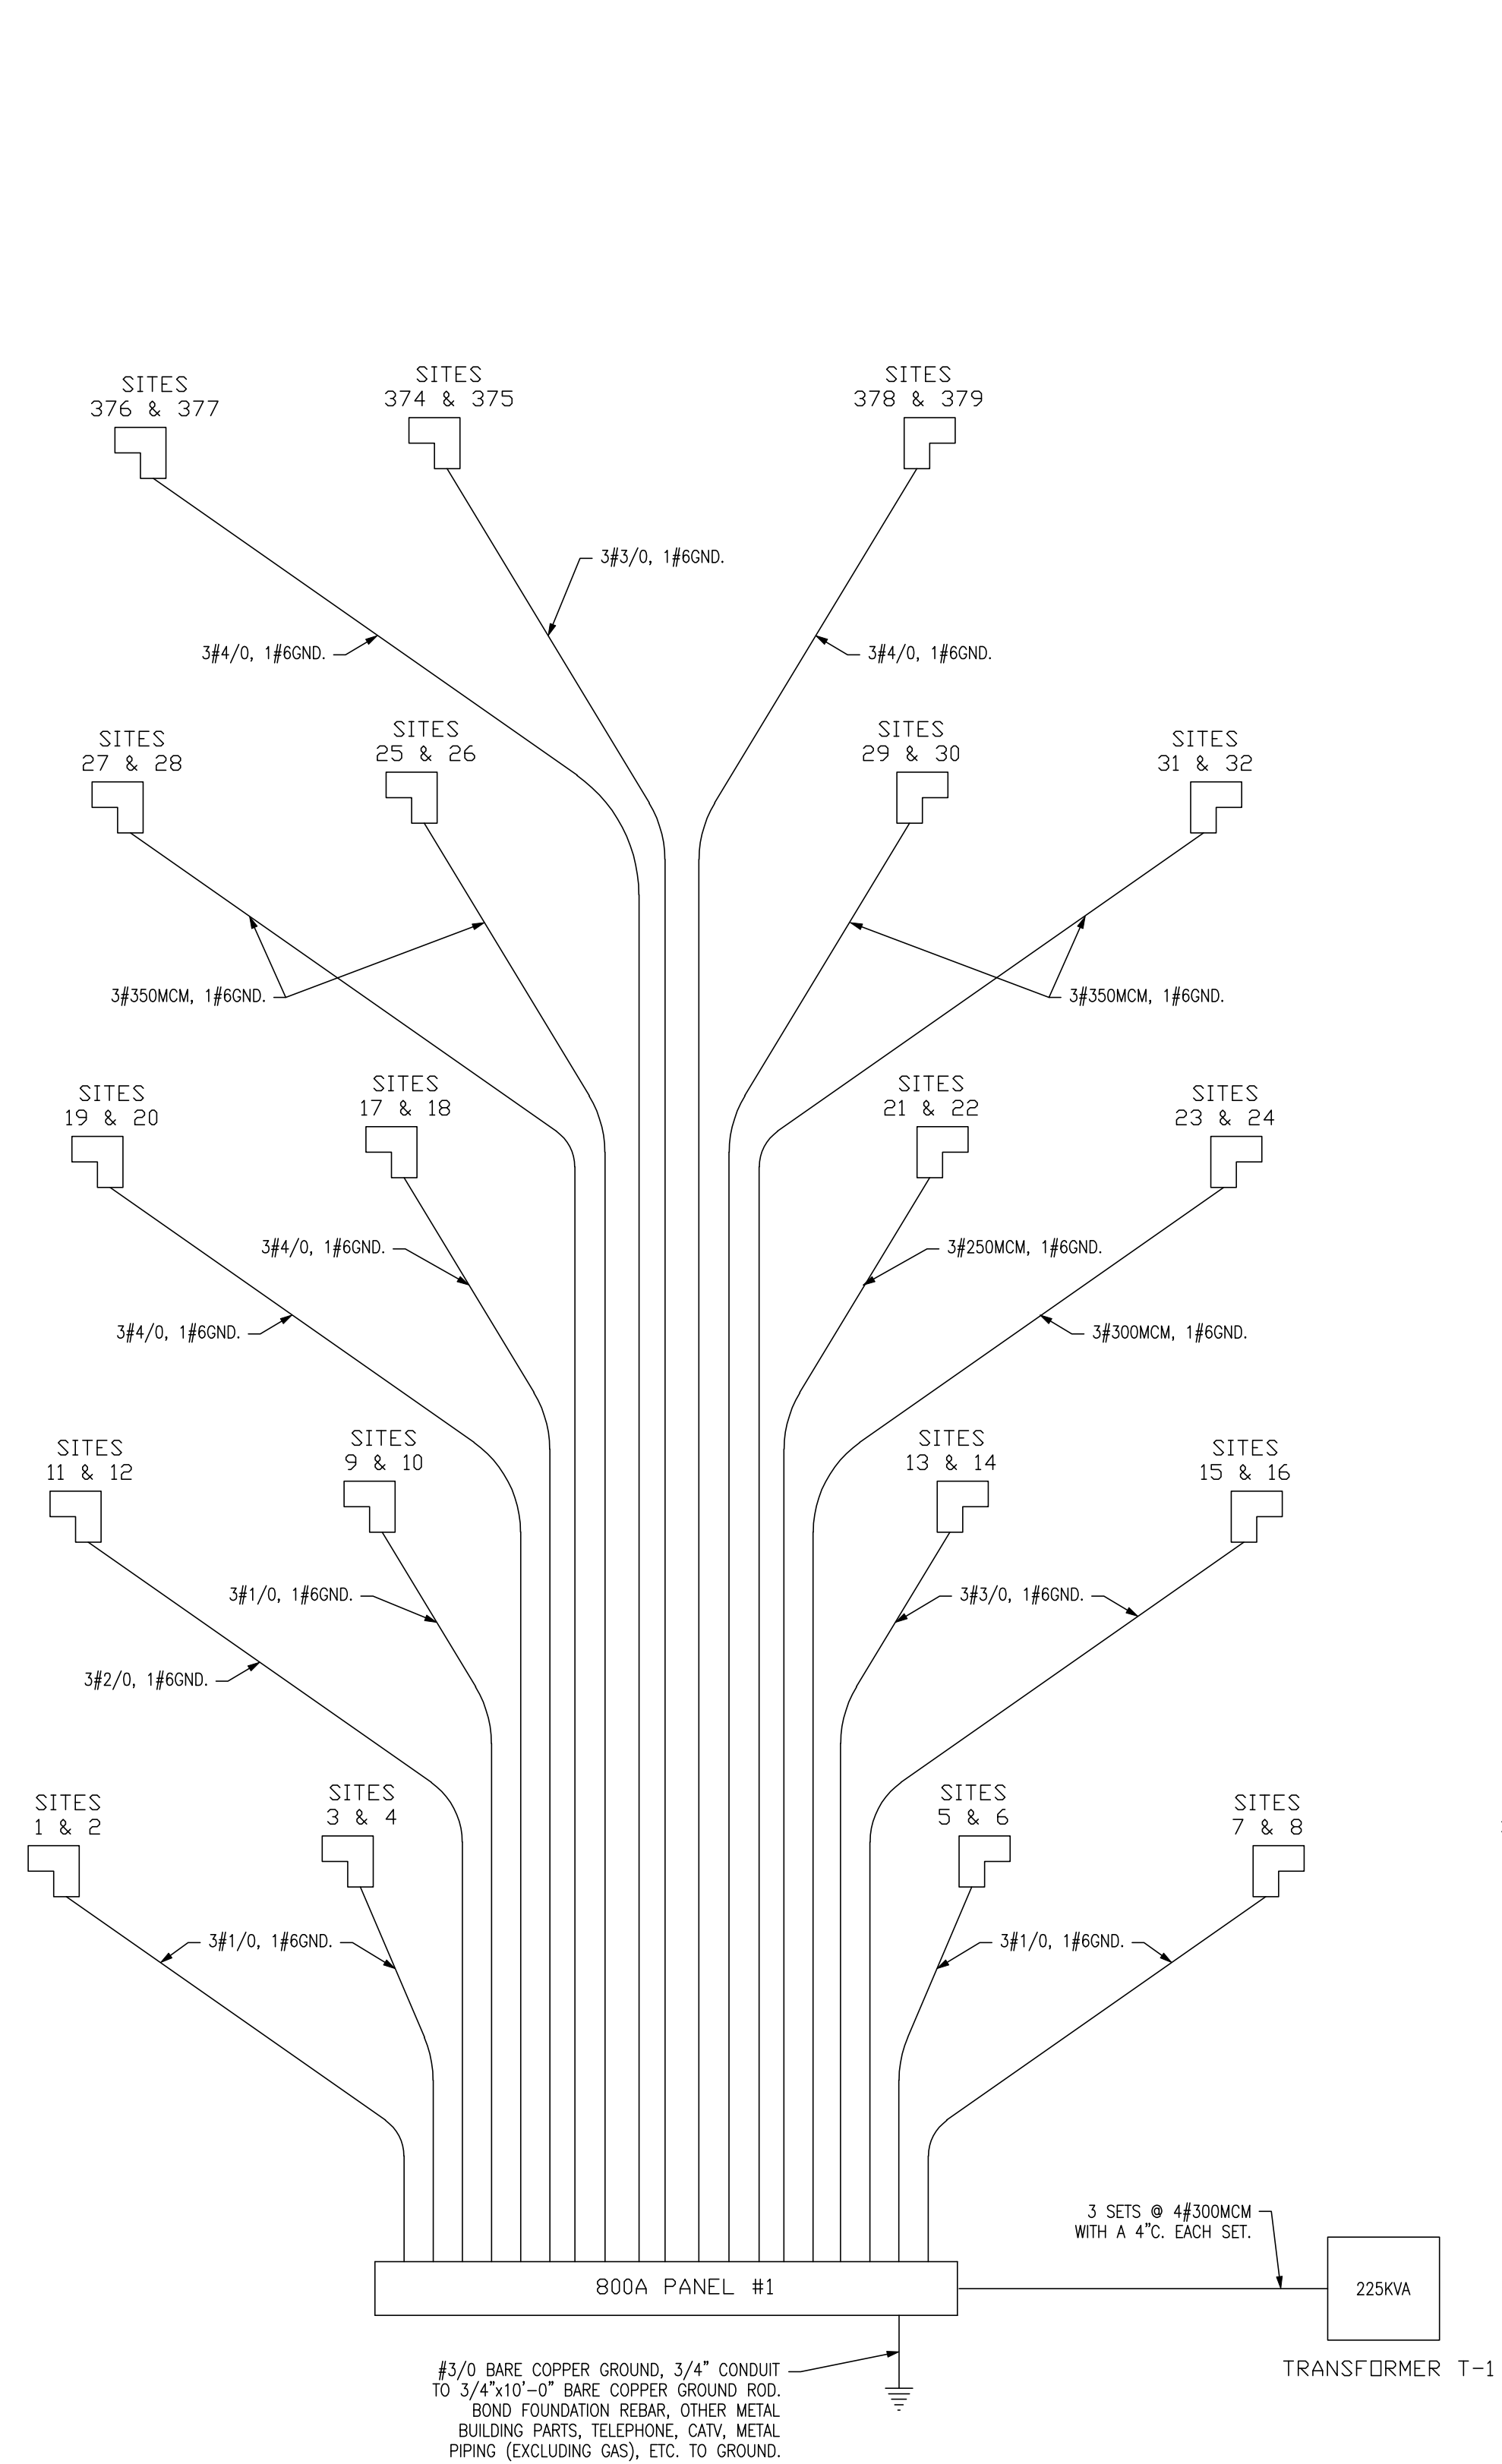

1 ELECTRIC RISER DIAGRAM
E3 SCALE: NO SCALE

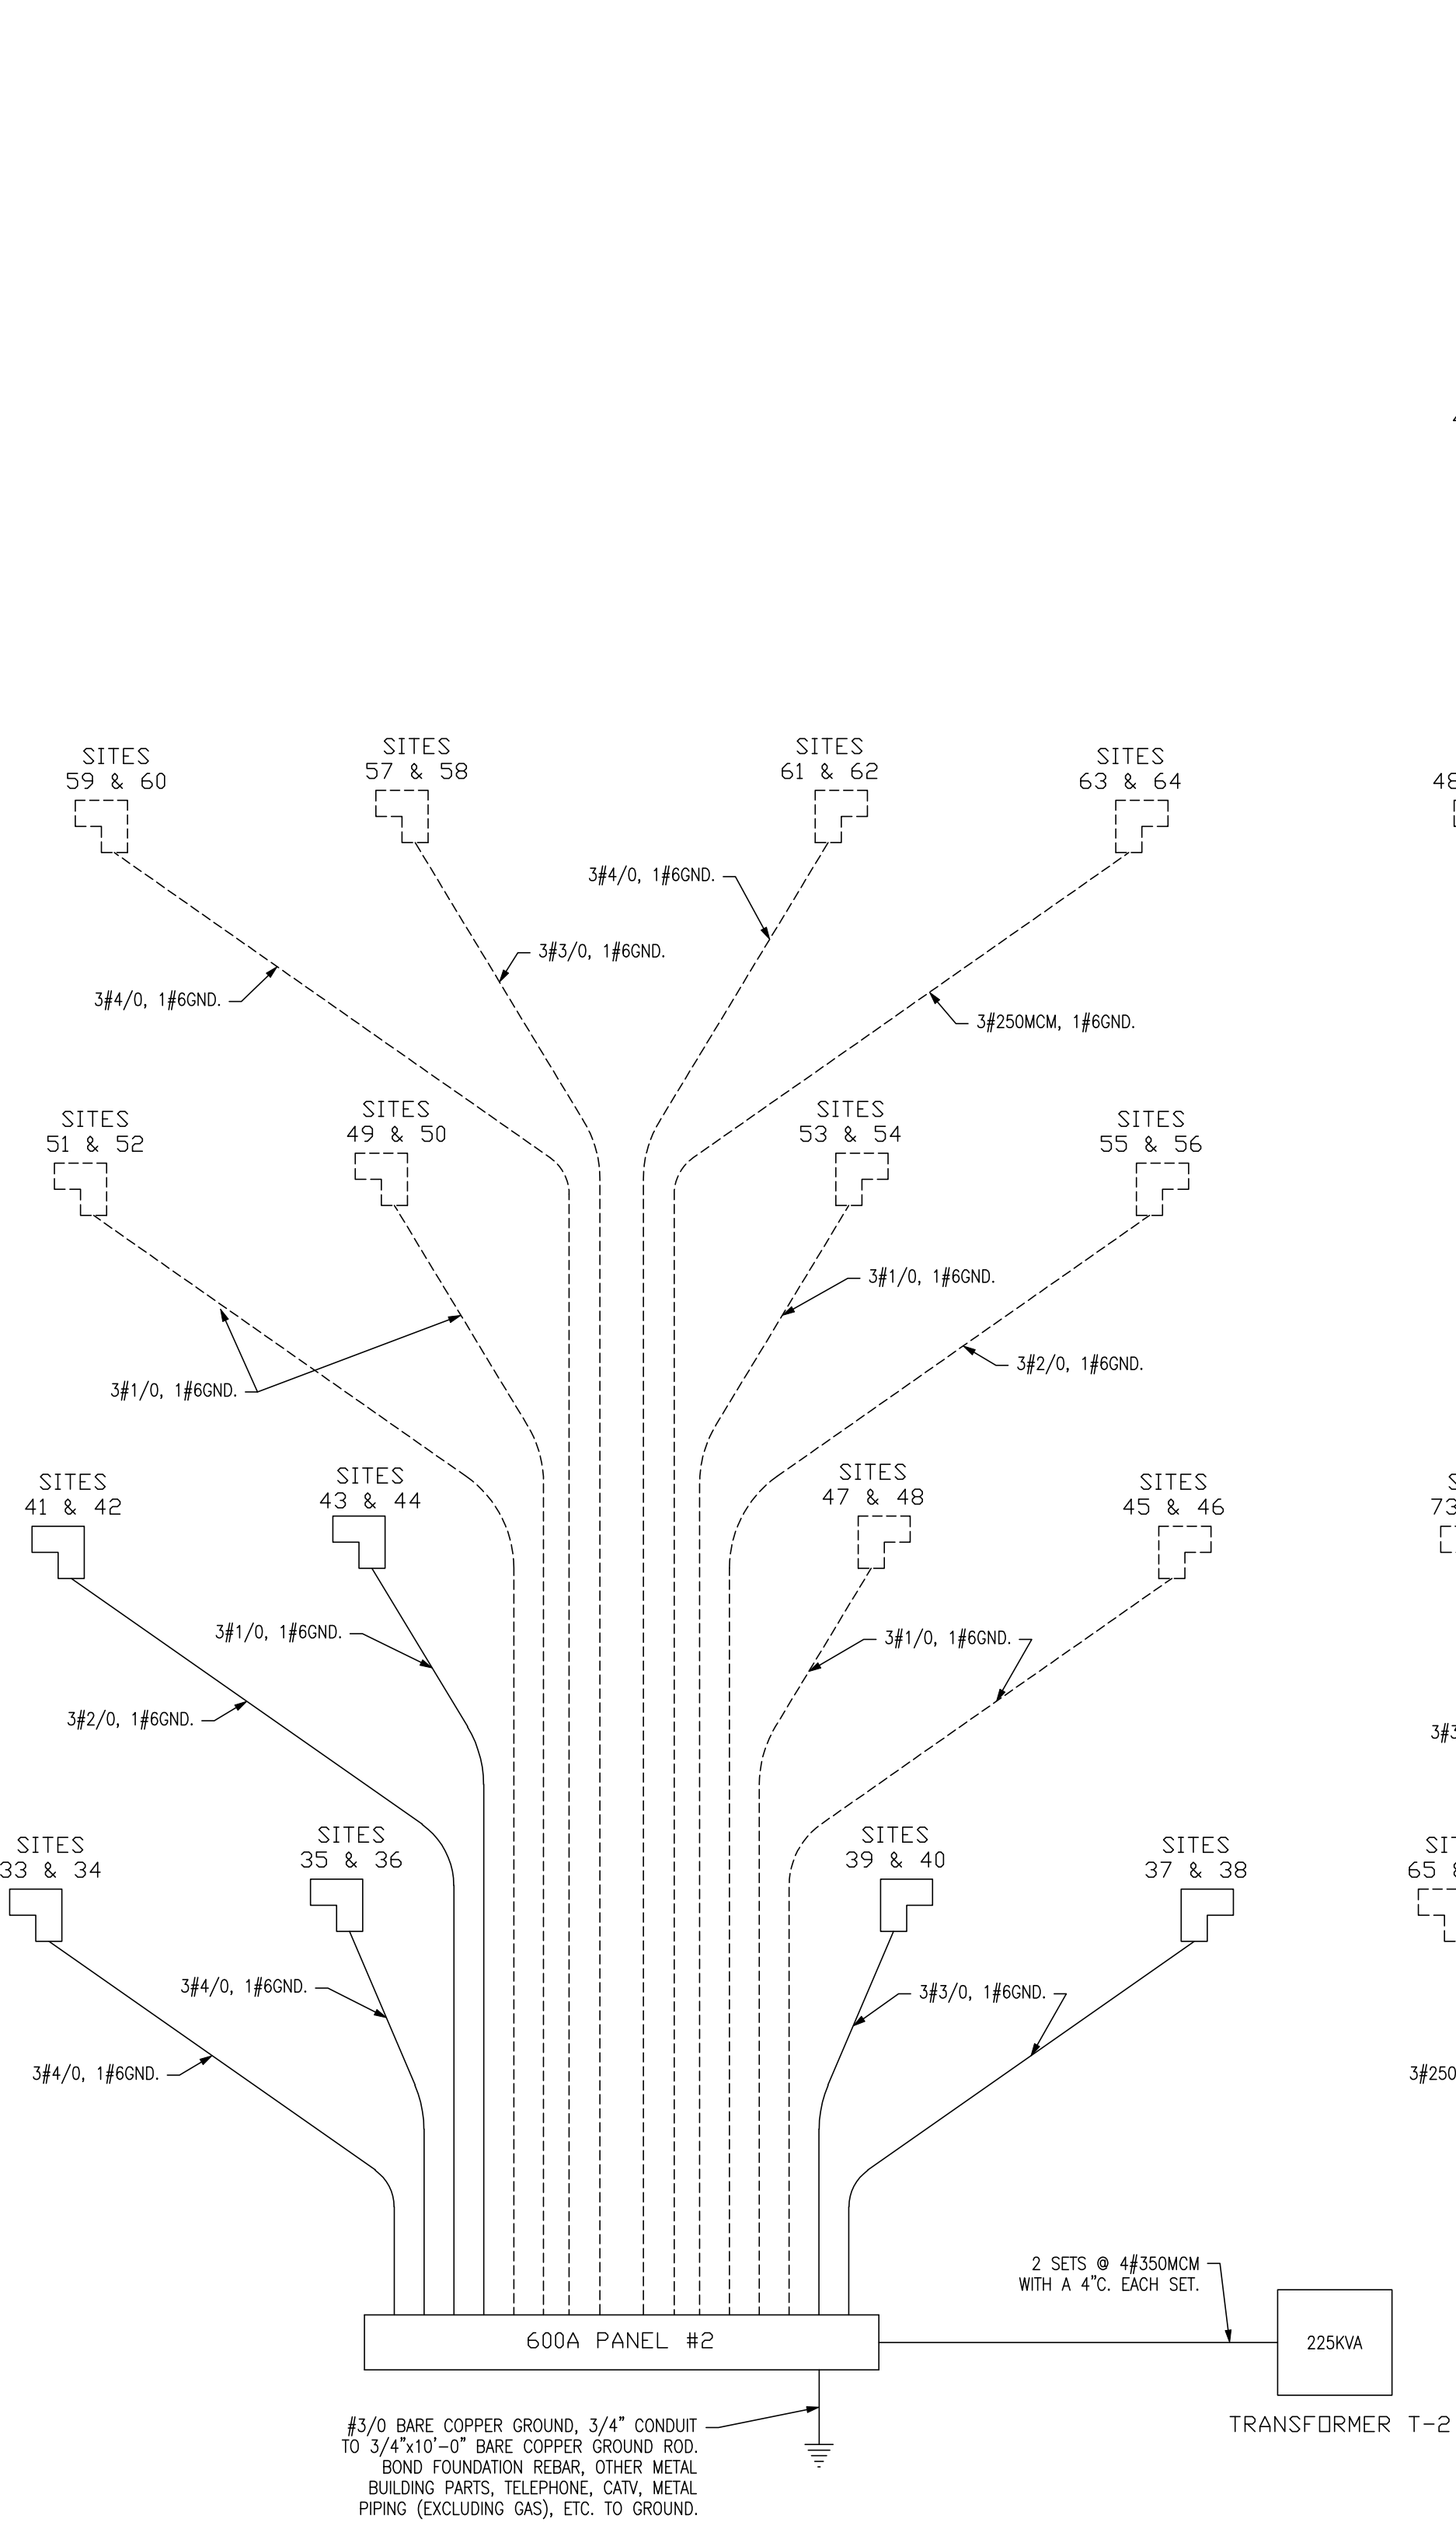


2 ELECTRIC RISER DIAGRAM
E3 SCALE: NO SCALE

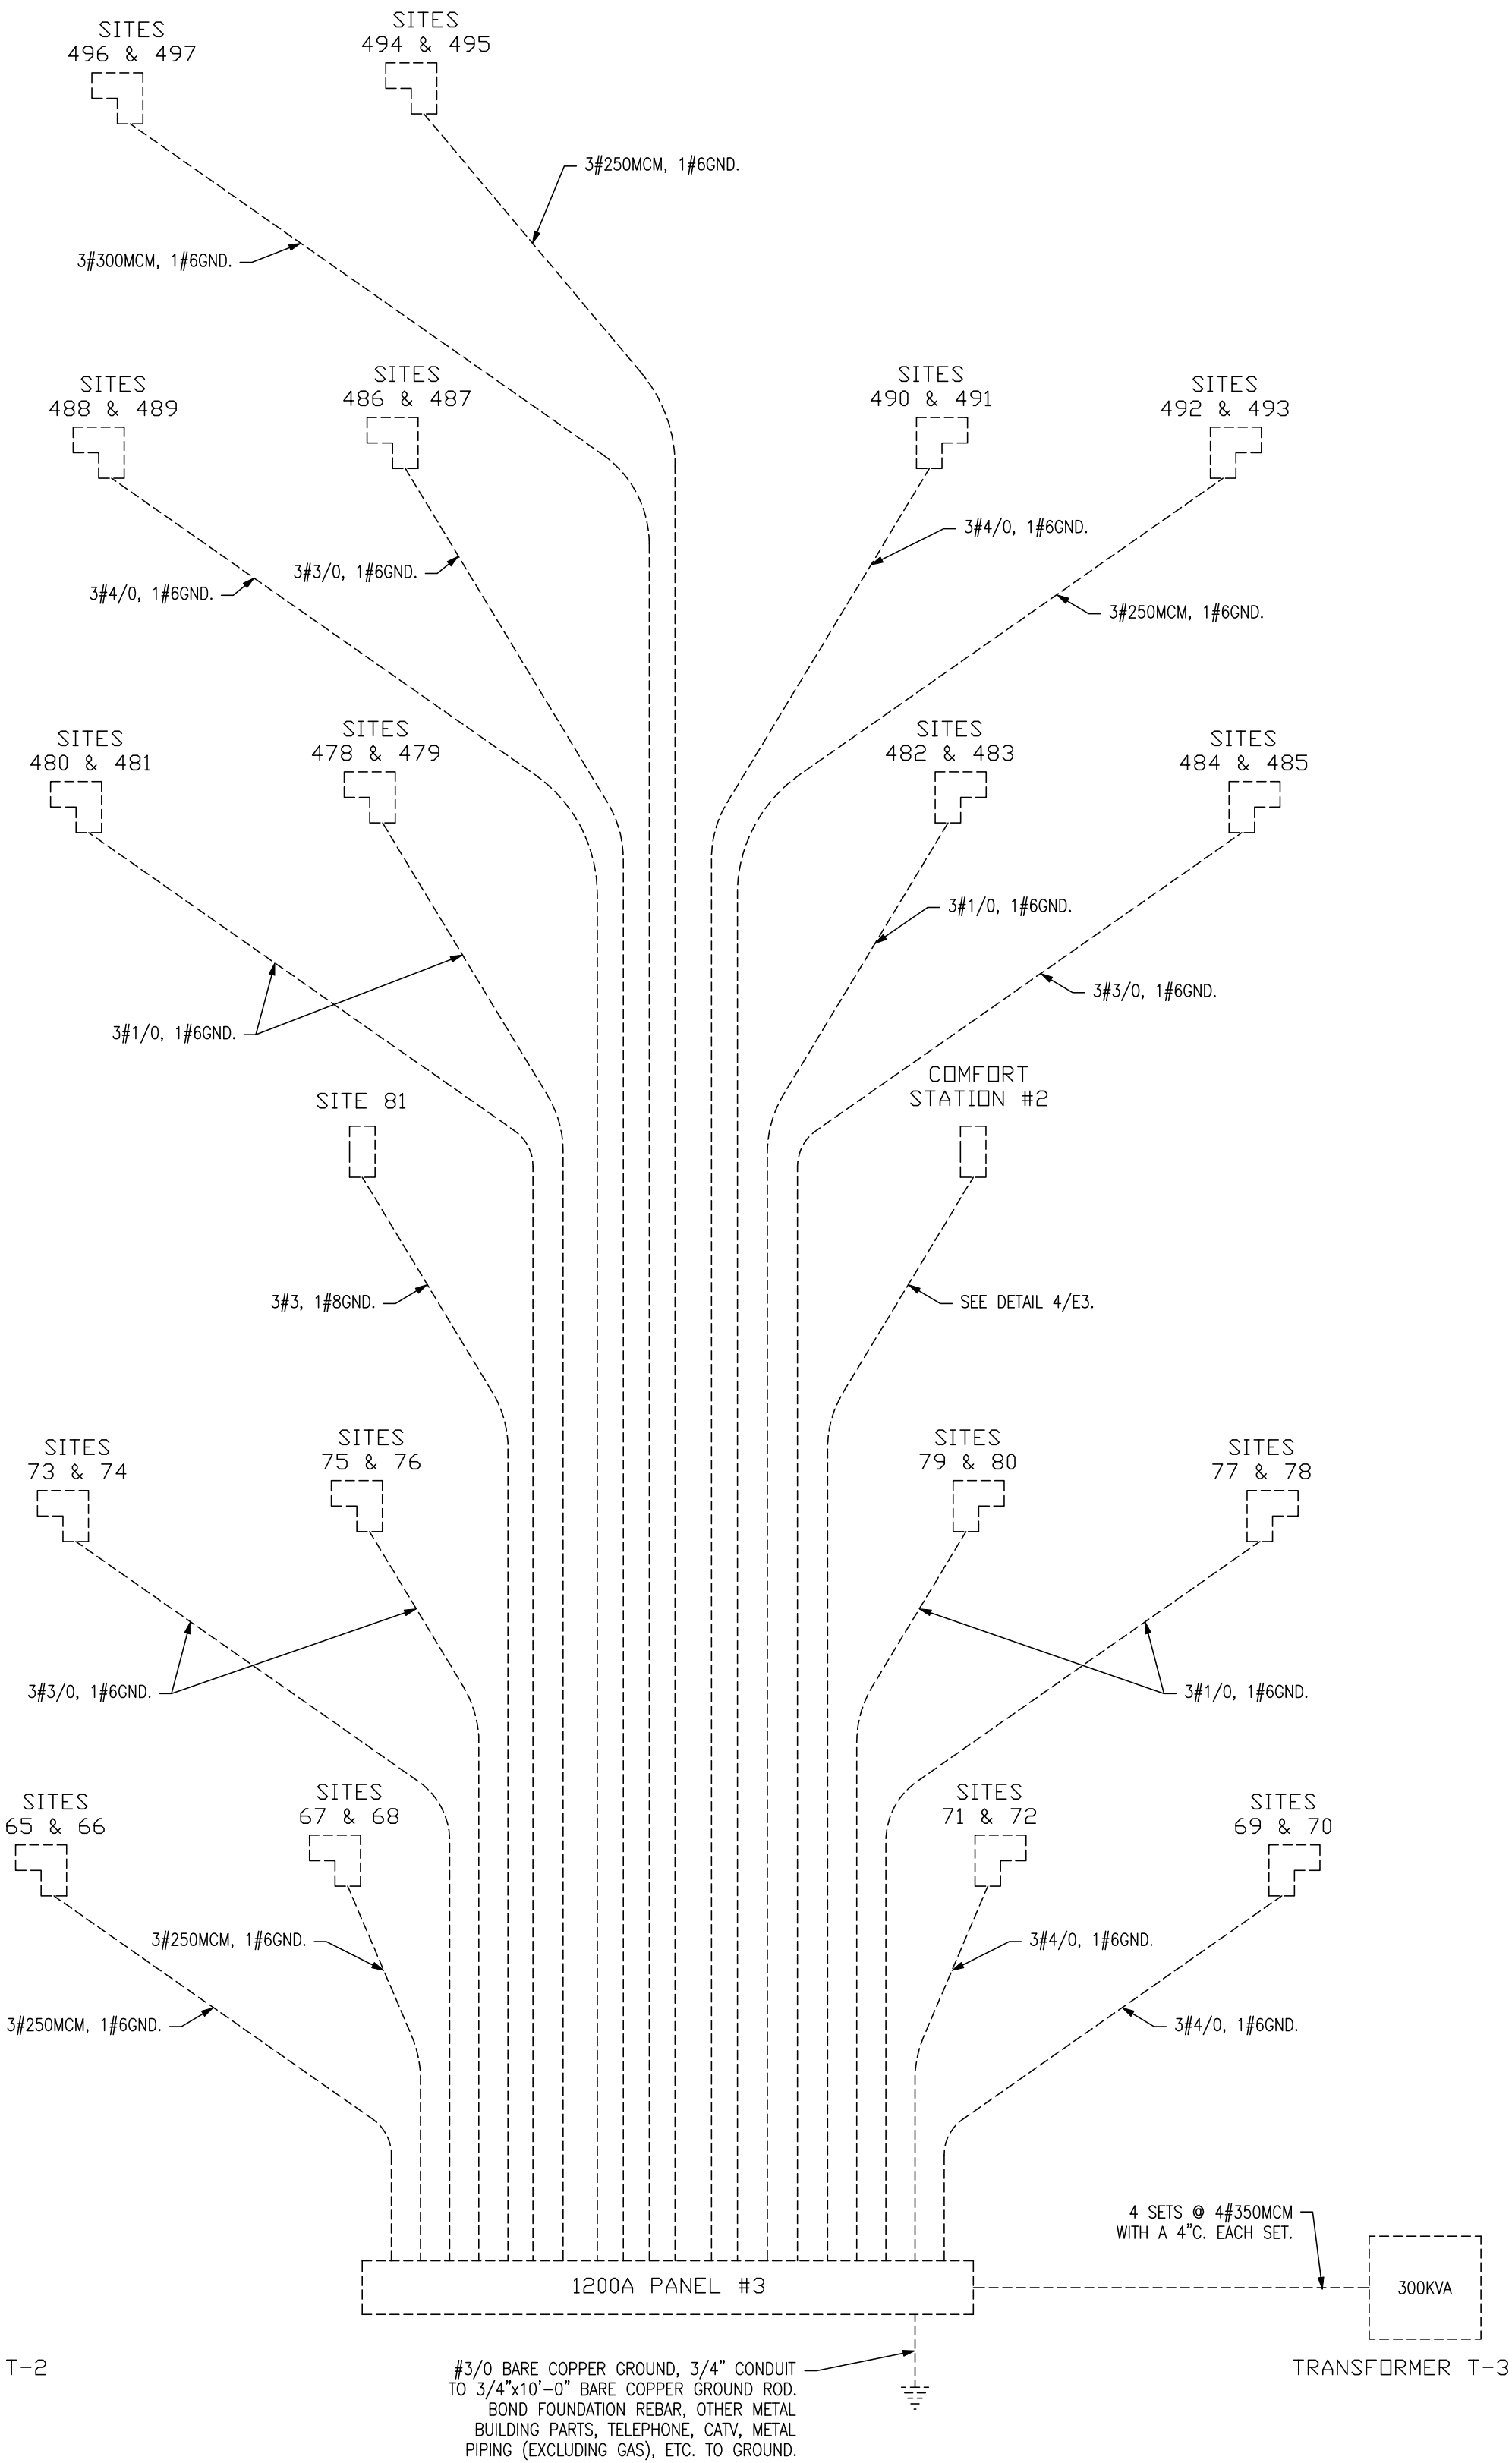

3 ELECTRIC RISER DIAGRAM
E3 SCALE: NO SCALE

STATE OF MISSOURI
MIKE KEHOE,
GOVERNOR

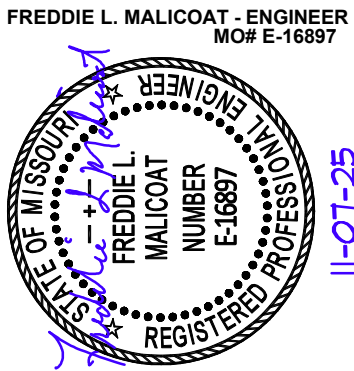

MALICOAT - WINSLOW
ENGINEERS, INC.

MISSOURI STATE CERTIFICATE OF AUTHORITY #000421
4840 RANGELINE STREET, #101
COLUMBIA, MISSOURI 65202
TEL 573-875-1300
FREDDIE MALICOAT, P.E.

OFFICE OF ADMINISTRATION
DIVISION OF FACILITIES
MANAGEMENT,
DESIGN AND CONSTRUCTION

MISSOURI
STATE FAIRGROUNDS

NEW CAMPGROUND
CONSTRUCTION PLANS

MISSOURI
STATE FAIRGROUNDS
2503 W 16th STREET
SEDALIA, MO

PROJECT # F2307-01
SITE # 1501
ASSET # 3511501153

REVISION: _____
DATE: _____
REVISION: _____
DATE: _____
REVISION: _____
DATE: _____
ISSUE DATE: _____

CAD DWG FILE: E-PLN-03
DRAWN BY: JDB
CHECKED BY: FM
DESIGNED BY: FM

SHEET TITLE:
ELECTRIC RISER
DIAGRAMS


SHEET NUMBER:

E3


35 OF 43
11/11/2025

T:\Job\24\2404\1\24041.dwg, 11/7/2025 12:30:13 PM, JoshB


- NOTE:
1. REFER TO PANEL SCHEDULES ON SHEETS E9-E11 FOR BREAKER SIZES.
 2. REFER TO CAMPGROUND ELECTRIC SERVICES TABLE ON SHEET ME1 FOR RECOMMENDED MINIMUM WIRE SIZES AND LENGTHS.
 3. WIRE SIZES ASSUME COPPER WIRE.
 4. ALL TRANSFORMERS TO BE 15KV TO 208V, 3Ø TRANSFORMERS PER EVERY REQUIREMENTS
 5. DASHED ITEMS DENOTES THEY ARE AN ALTERNATE. SEE PANEL SCHEDULES ON SHEETS E9-E11 AND SHEET C-003 FOR ALTERNATE SCHEDULE.

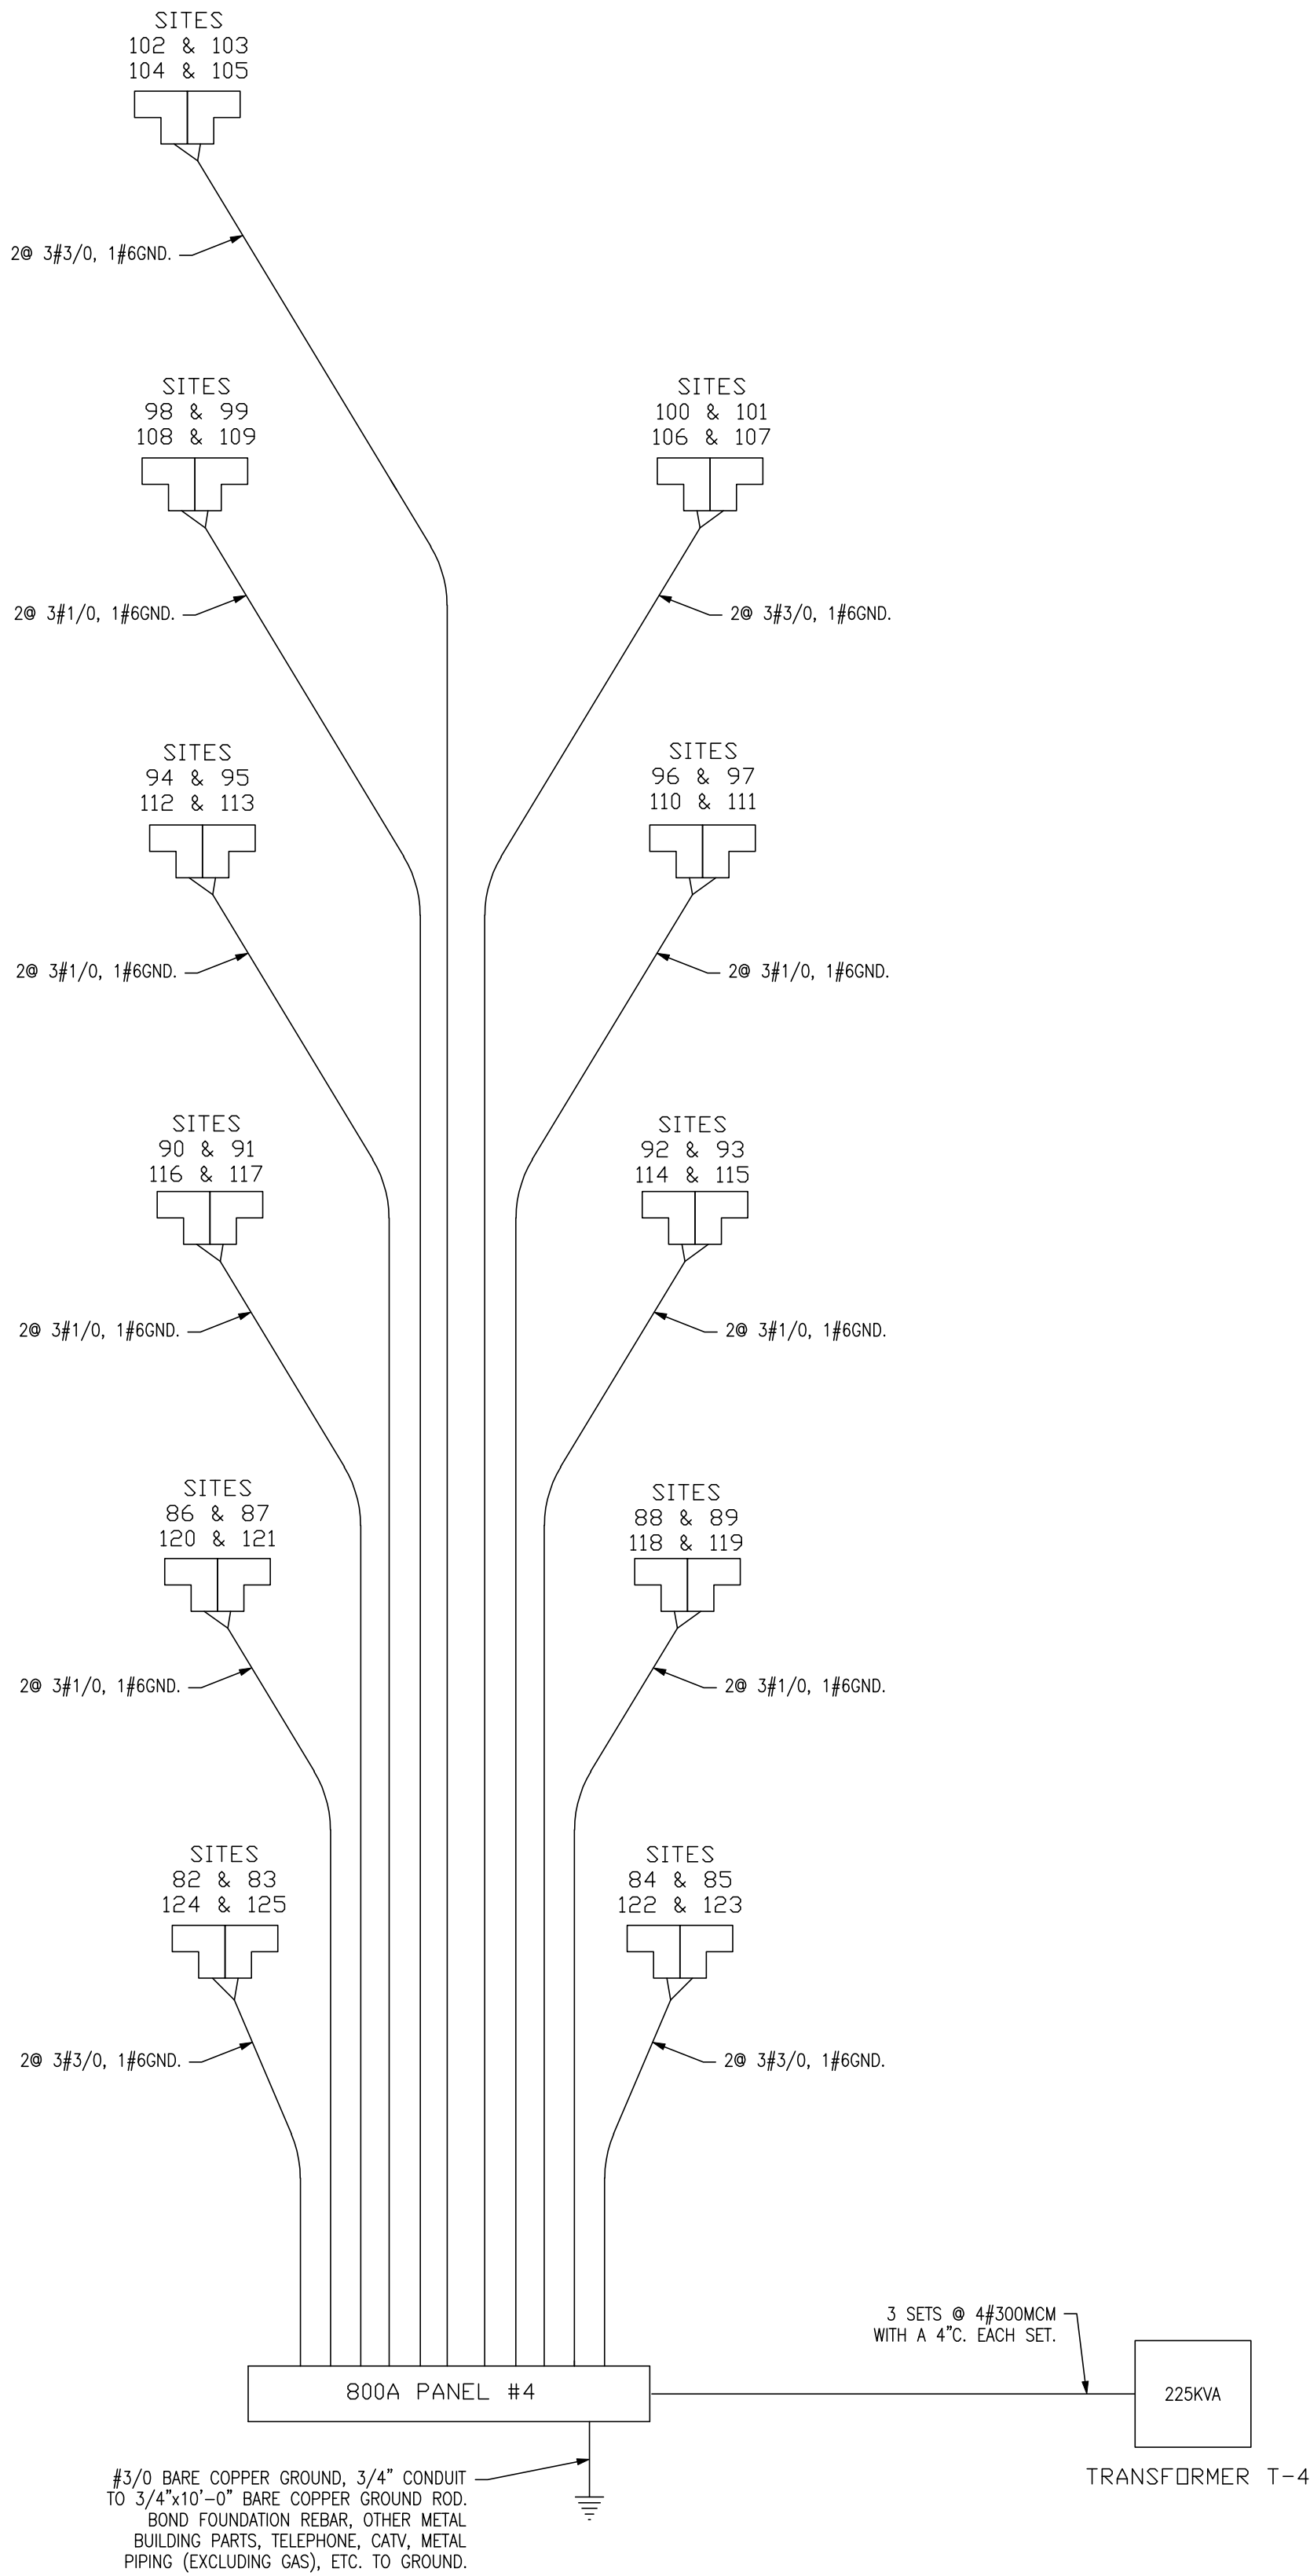

1 ELECTRIC RISER DIAGRAM
E4 SCALE: NO SCALE

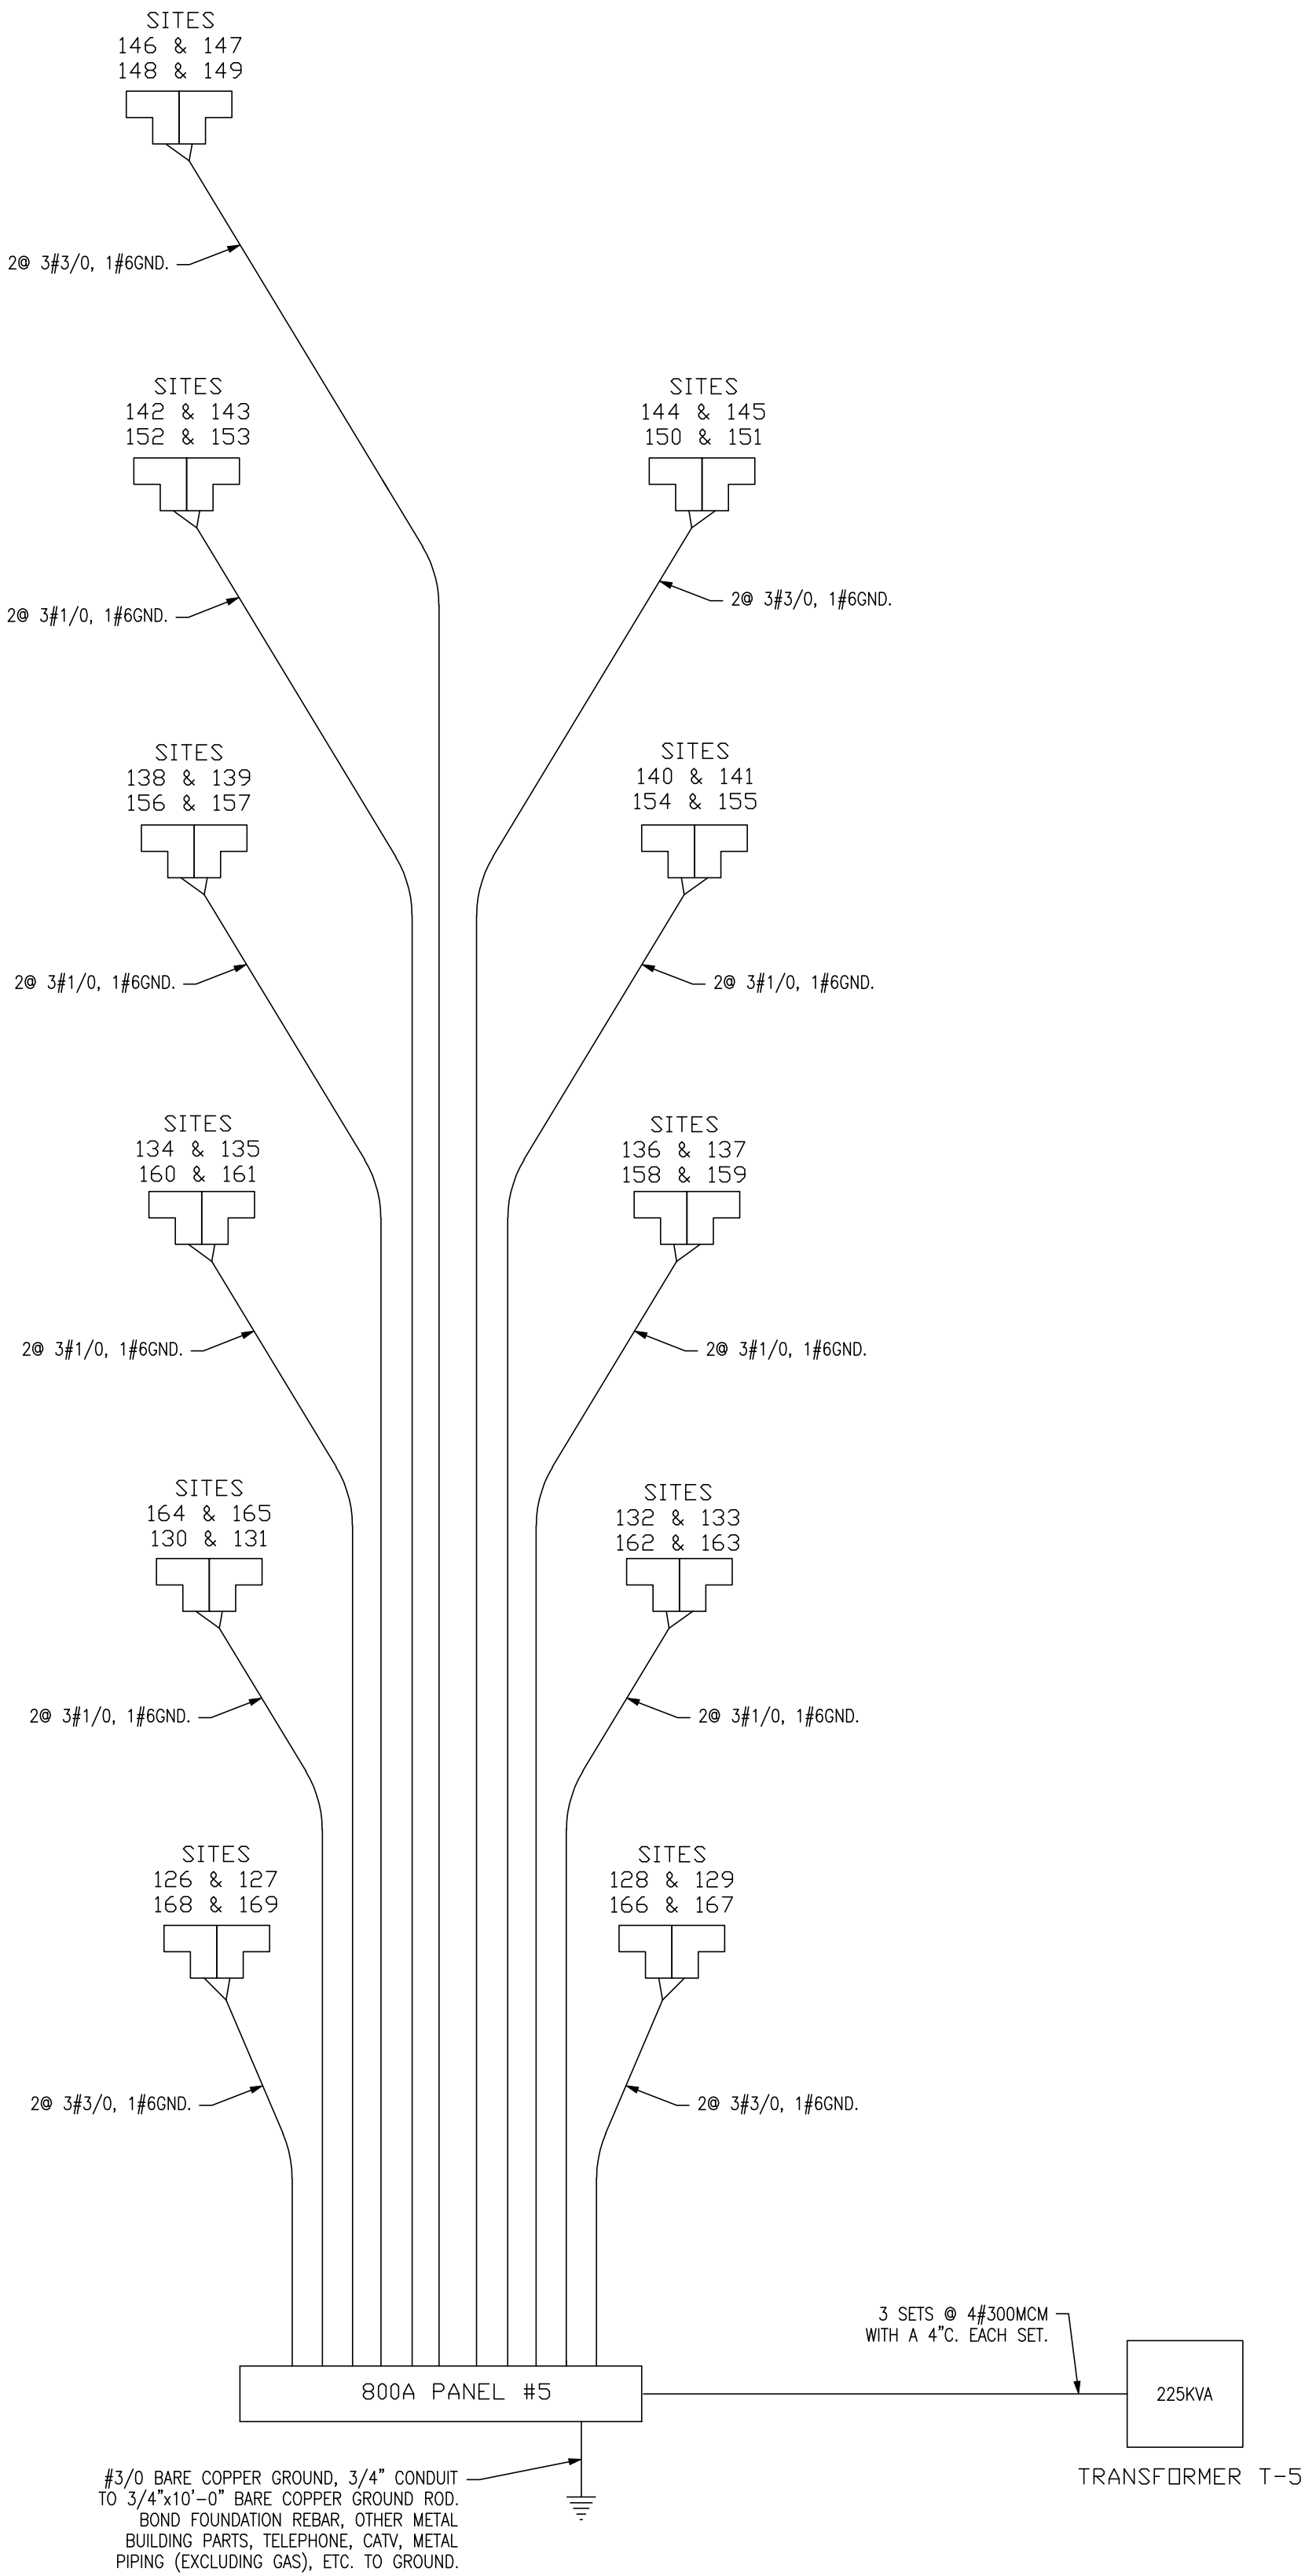


2 ELECTRIC RISER DIAGRAM
E4 SCALE: NO SCALE

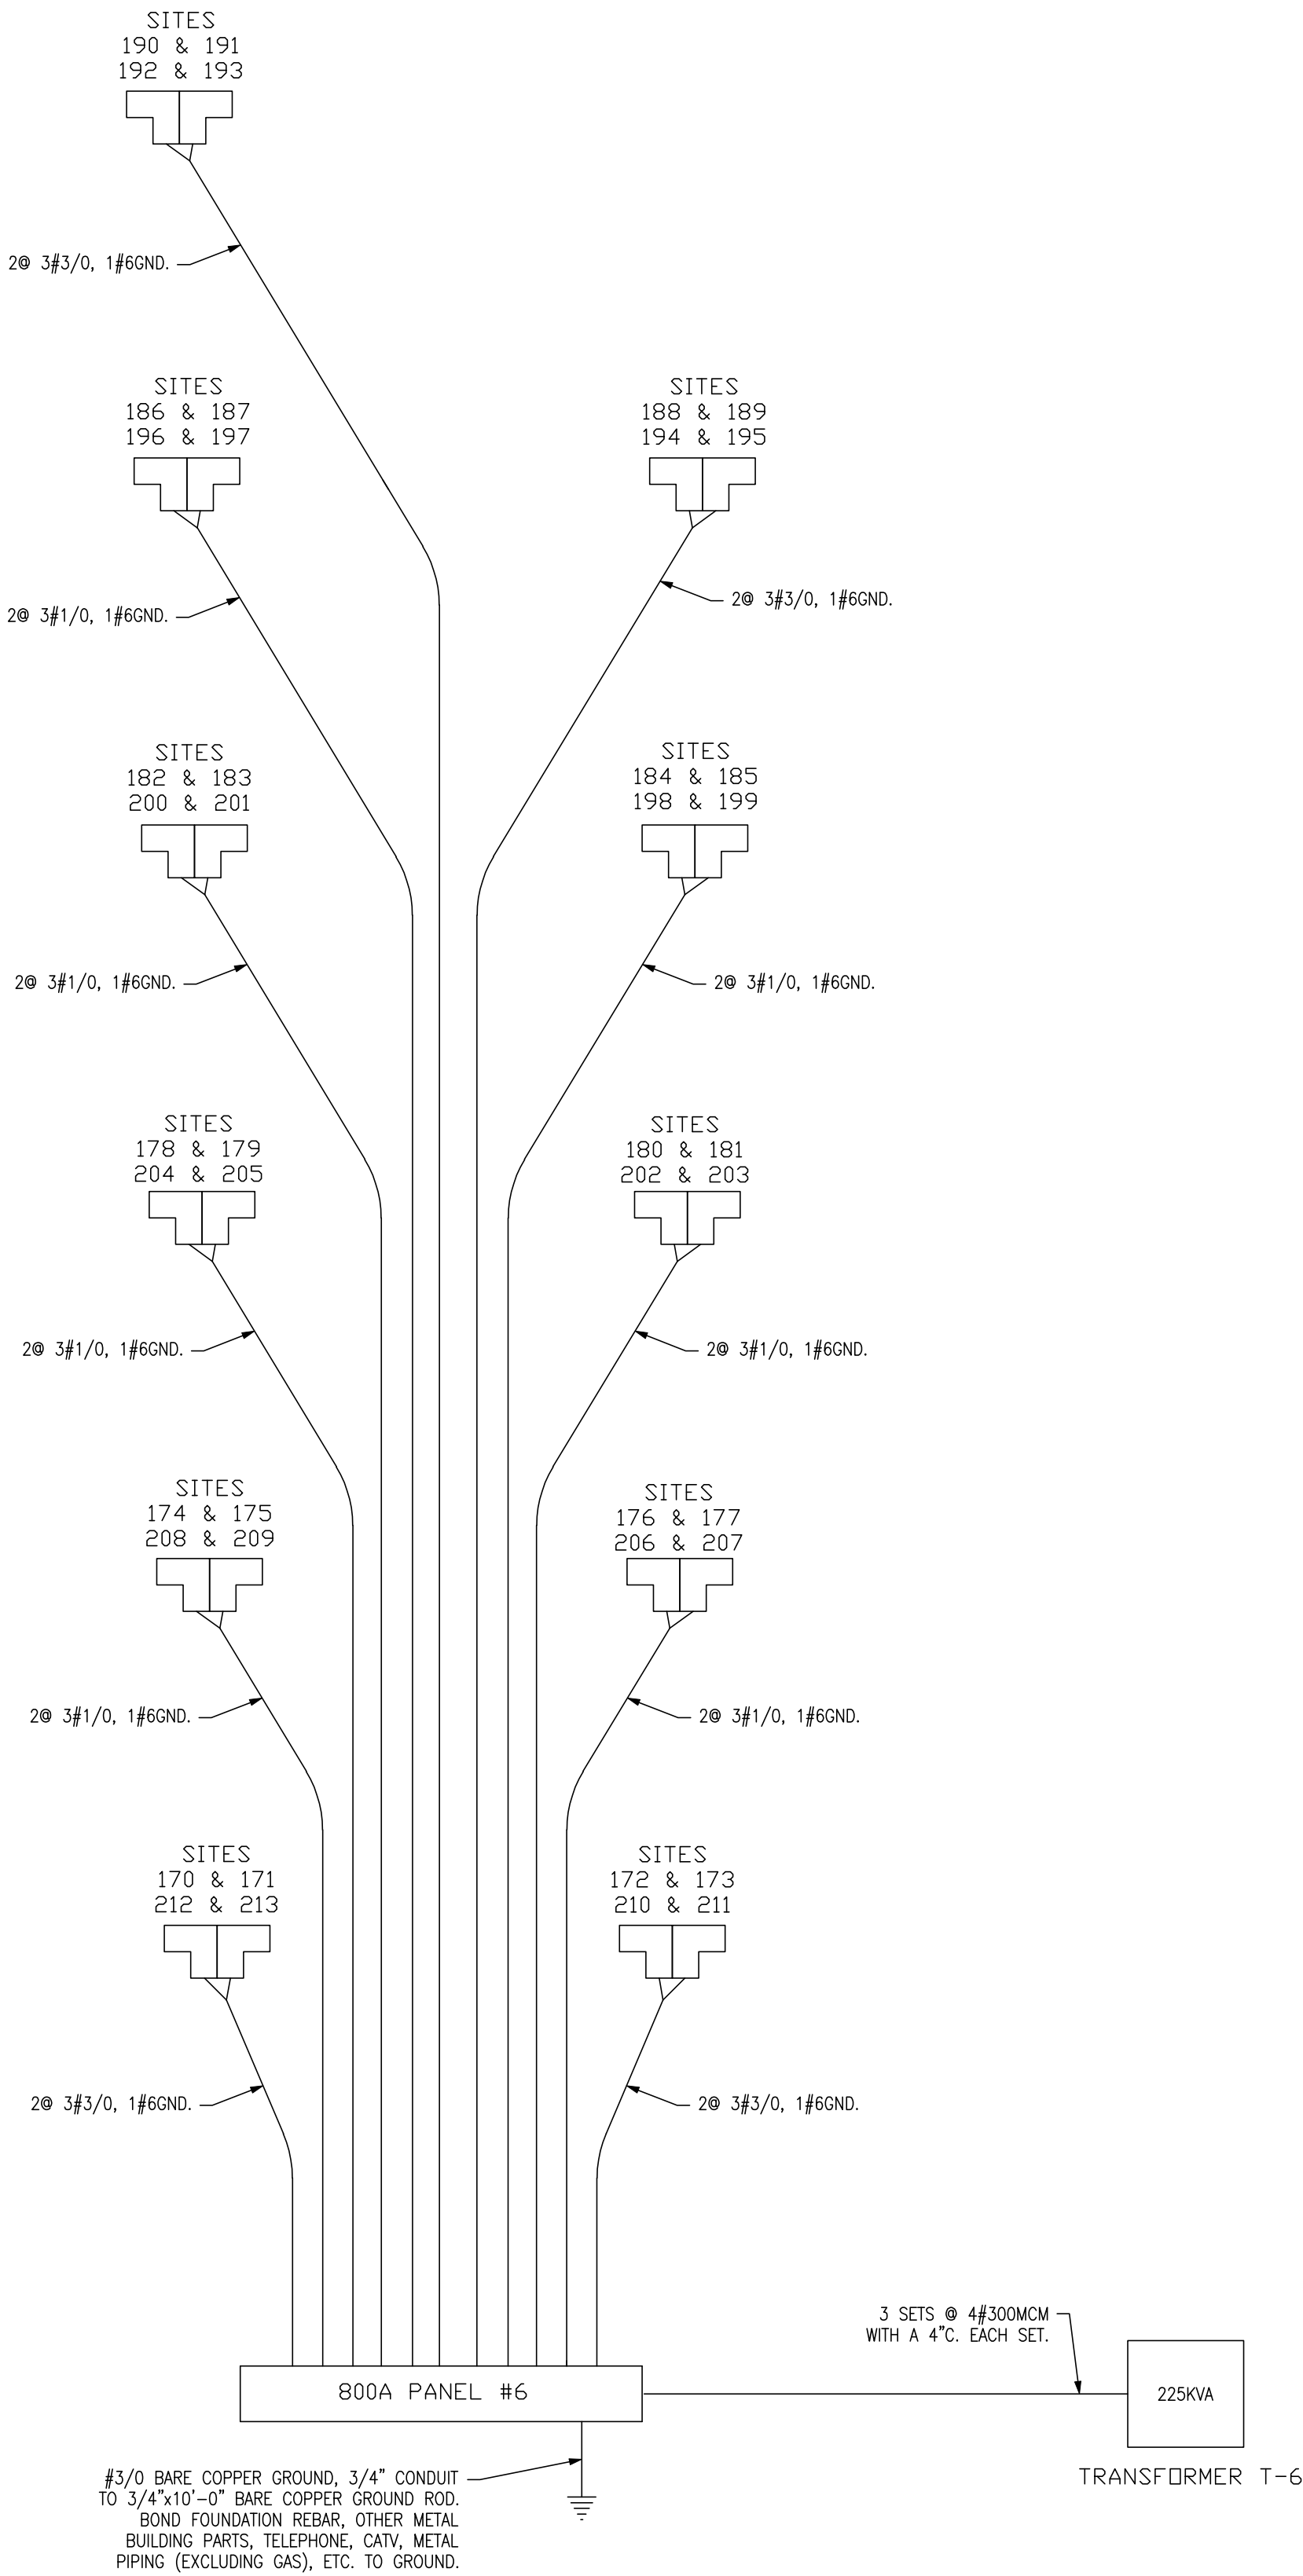

3 ELECTRIC RISER DIAGRAM
E4 SCALE: NO SCALE

STATE OF MISSOURI
MIKE KEHOE,
GOVERNOR

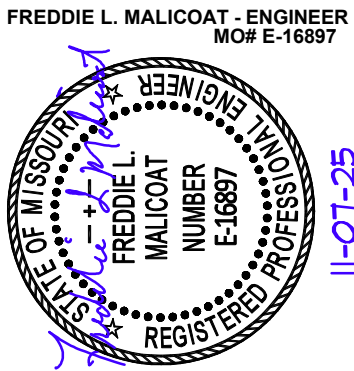

**MALICOAT - WINSLOW
ENGINEERS, INC.**

MISSOURI STATE CERTIFICATE OF AUTHORITY #000421

4840 RANGELINE STREET, #101
COLUMBIA, MISSOURI 65202

FREDDIE MALICOAT, P.E.

OFFICE OF ADMINISTRATION
DIVISION OF FACILITIES
MANAGEMENT,
DESIGN AND CONSTRUCTION

MISSOURI
STATE FAIRGROUNDS

NEW CAMPGROUND
CONSTRUCTION PLANS

MISSOURI
STATE FAIRGROUNDS
2503 W 16th STREET
SEDALIA, MO

PROJECT # F2307-01
SITE # 1501
ASSET # 3511501153

REVISION: _____
DATE: _____
REVISION: _____
DATE: _____
REVISION: _____
DATE: _____

ISSUE DATE: _____

CAD DWG FILE: E-PLN-04
DRAWN BY: JDB
CHECKED BY: FM
DESIGNED BY: FM

SHEET TITLE:

ELECTRIC RISER
DIAGRAMS

SHEET NUMBER:

E4

36 OF 43
11/11/2025

1. REFER TO PANEL SCHEDULES ON SHEETS E9-E11 FOR BREAKER SIZES.
2. REFER TO CAMPOUND ELECTRIC SERVICES TABLE ON SHEET ME1 FOR RECOMMENDED MINIMUM WIRE SIZES AND LENGTHS.
3. WIRE SIZES ASSUME COPPER WIRE.
4. ALL TRANSFORMERS TO BE 15KV TO 208V, 3Ø TRANSFORMERS PER EVERY REQUIREMENTS
5. DASHED ITEMS DENOTES THEY ARE AN ALTERNATE. SEE PANEL SCHEDULES ON SHEETS E9-E11 AND SHEET C-003 FOR ALTERNATE SCHEDULE.



FREDDIE MALICOAT, P.E.

MISSOURI
STATE FAIRGROUNDS

MISSOURI
STATE FAIRGROUNDS
2503 W 16th STREET
SEDALIA, MO

PROJECT #	F2307-01
SITE #	1501
ASSET #	3511501153

REVISION: _____
DATE: _____
REVISION: _____
DATE: _____
REVISION: _____
DATE: _____
ISSUE DATE: _____

CAD DWG FILE: E-PLN-05
DRAWN BY: JDB
CHECKED BY: FM
DESIGNED BY: FM

SHEET TITLE:

ELECTRIC RISER DIAGRAMS

SHEET NUMBER:


E5

37 OF 43
11/11/2025


T:\Job\24\24041\24041.dwg, 11/7/2025 12:30:11 PM, JoshB

T:\job\24\2404\1\24041.dwg, 11/7/2025 12:30:10 PM, JoshB


- NOTE:
1. REFER TO PANEL SCHEDULES ON SHEETS E9-E11 FOR BREAKER SIZES.
 2. REFER TO CAMPGROUND ELECTRIC SERVICES TABLE ON SHEET ME1 FOR RECOMMENDED MINIMUM WIRE SIZES AND LENGTHS.
 3. WIRE SIZES ASSUME COPPER WIRE.
 4. ALL TRANSFORMERS TO BE 15KV TO 208V, 3Ø TRANSFORMERS PER EVERY REQUIREMENTS
 5. DASHED ITEMS DENOTES THEY ARE AN ALTERNATE. SEE PANEL SCHEDULES ON SHEETS E9-E11 AND SHEET C-003 FOR ALTERNATE SCHEDULE.

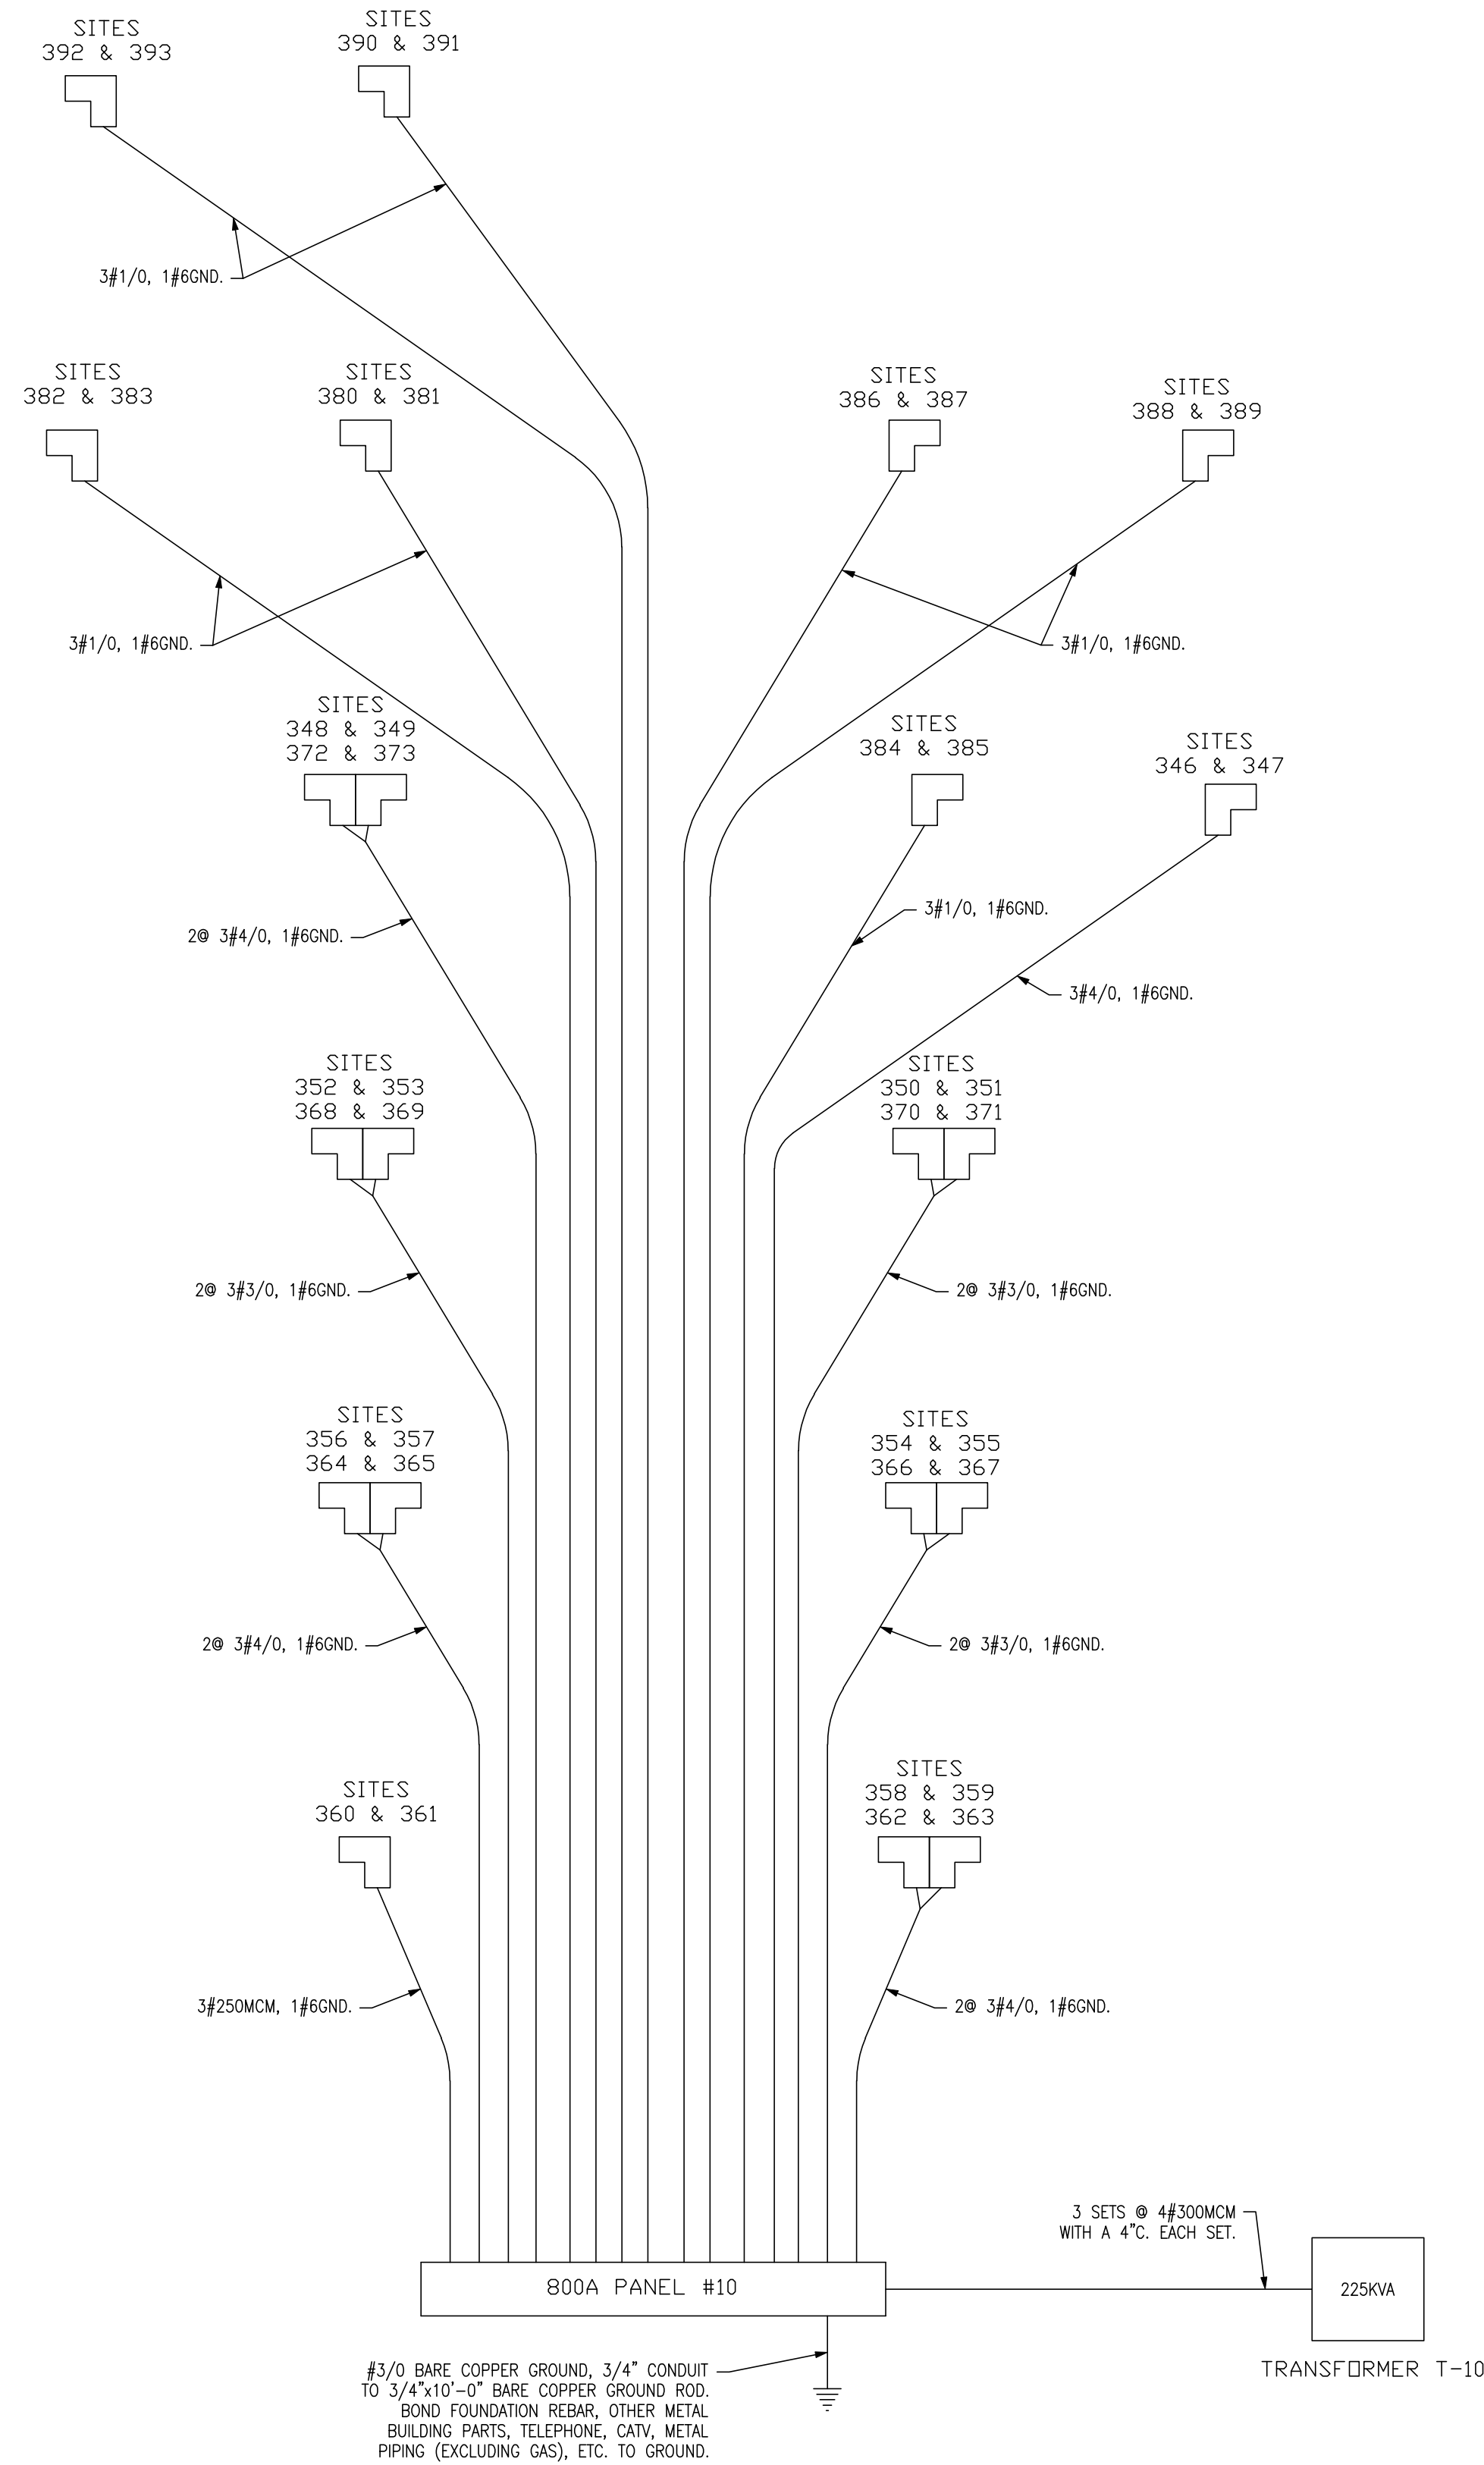

1 **ELECTRIC RISER DIAGRAM**
E6 SCALE: NO SCALE

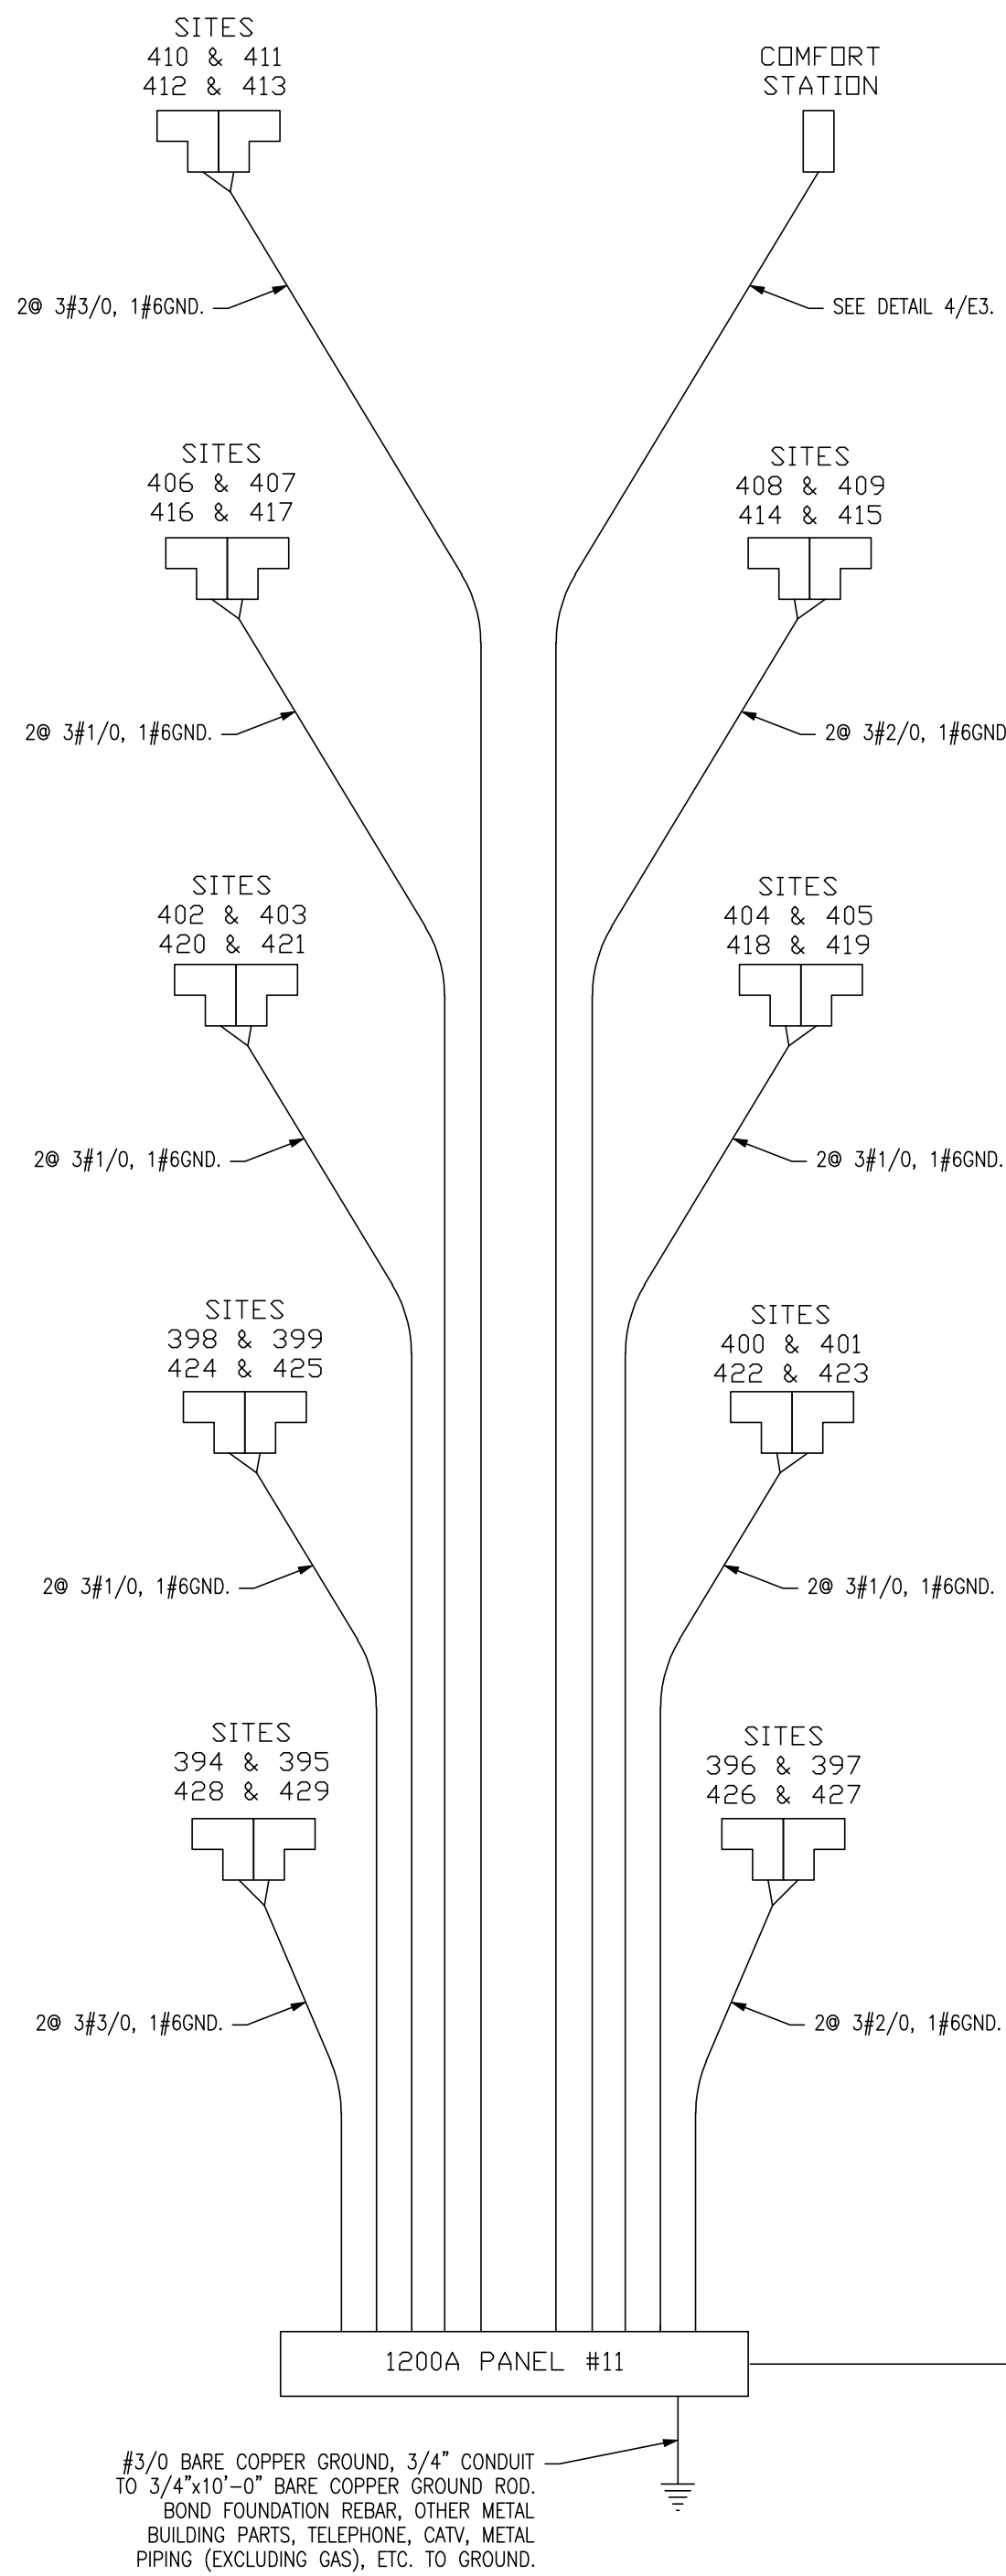


2 **ELECTRIC RISER DIAGRAM**
E6 SCALE: NO SCALE

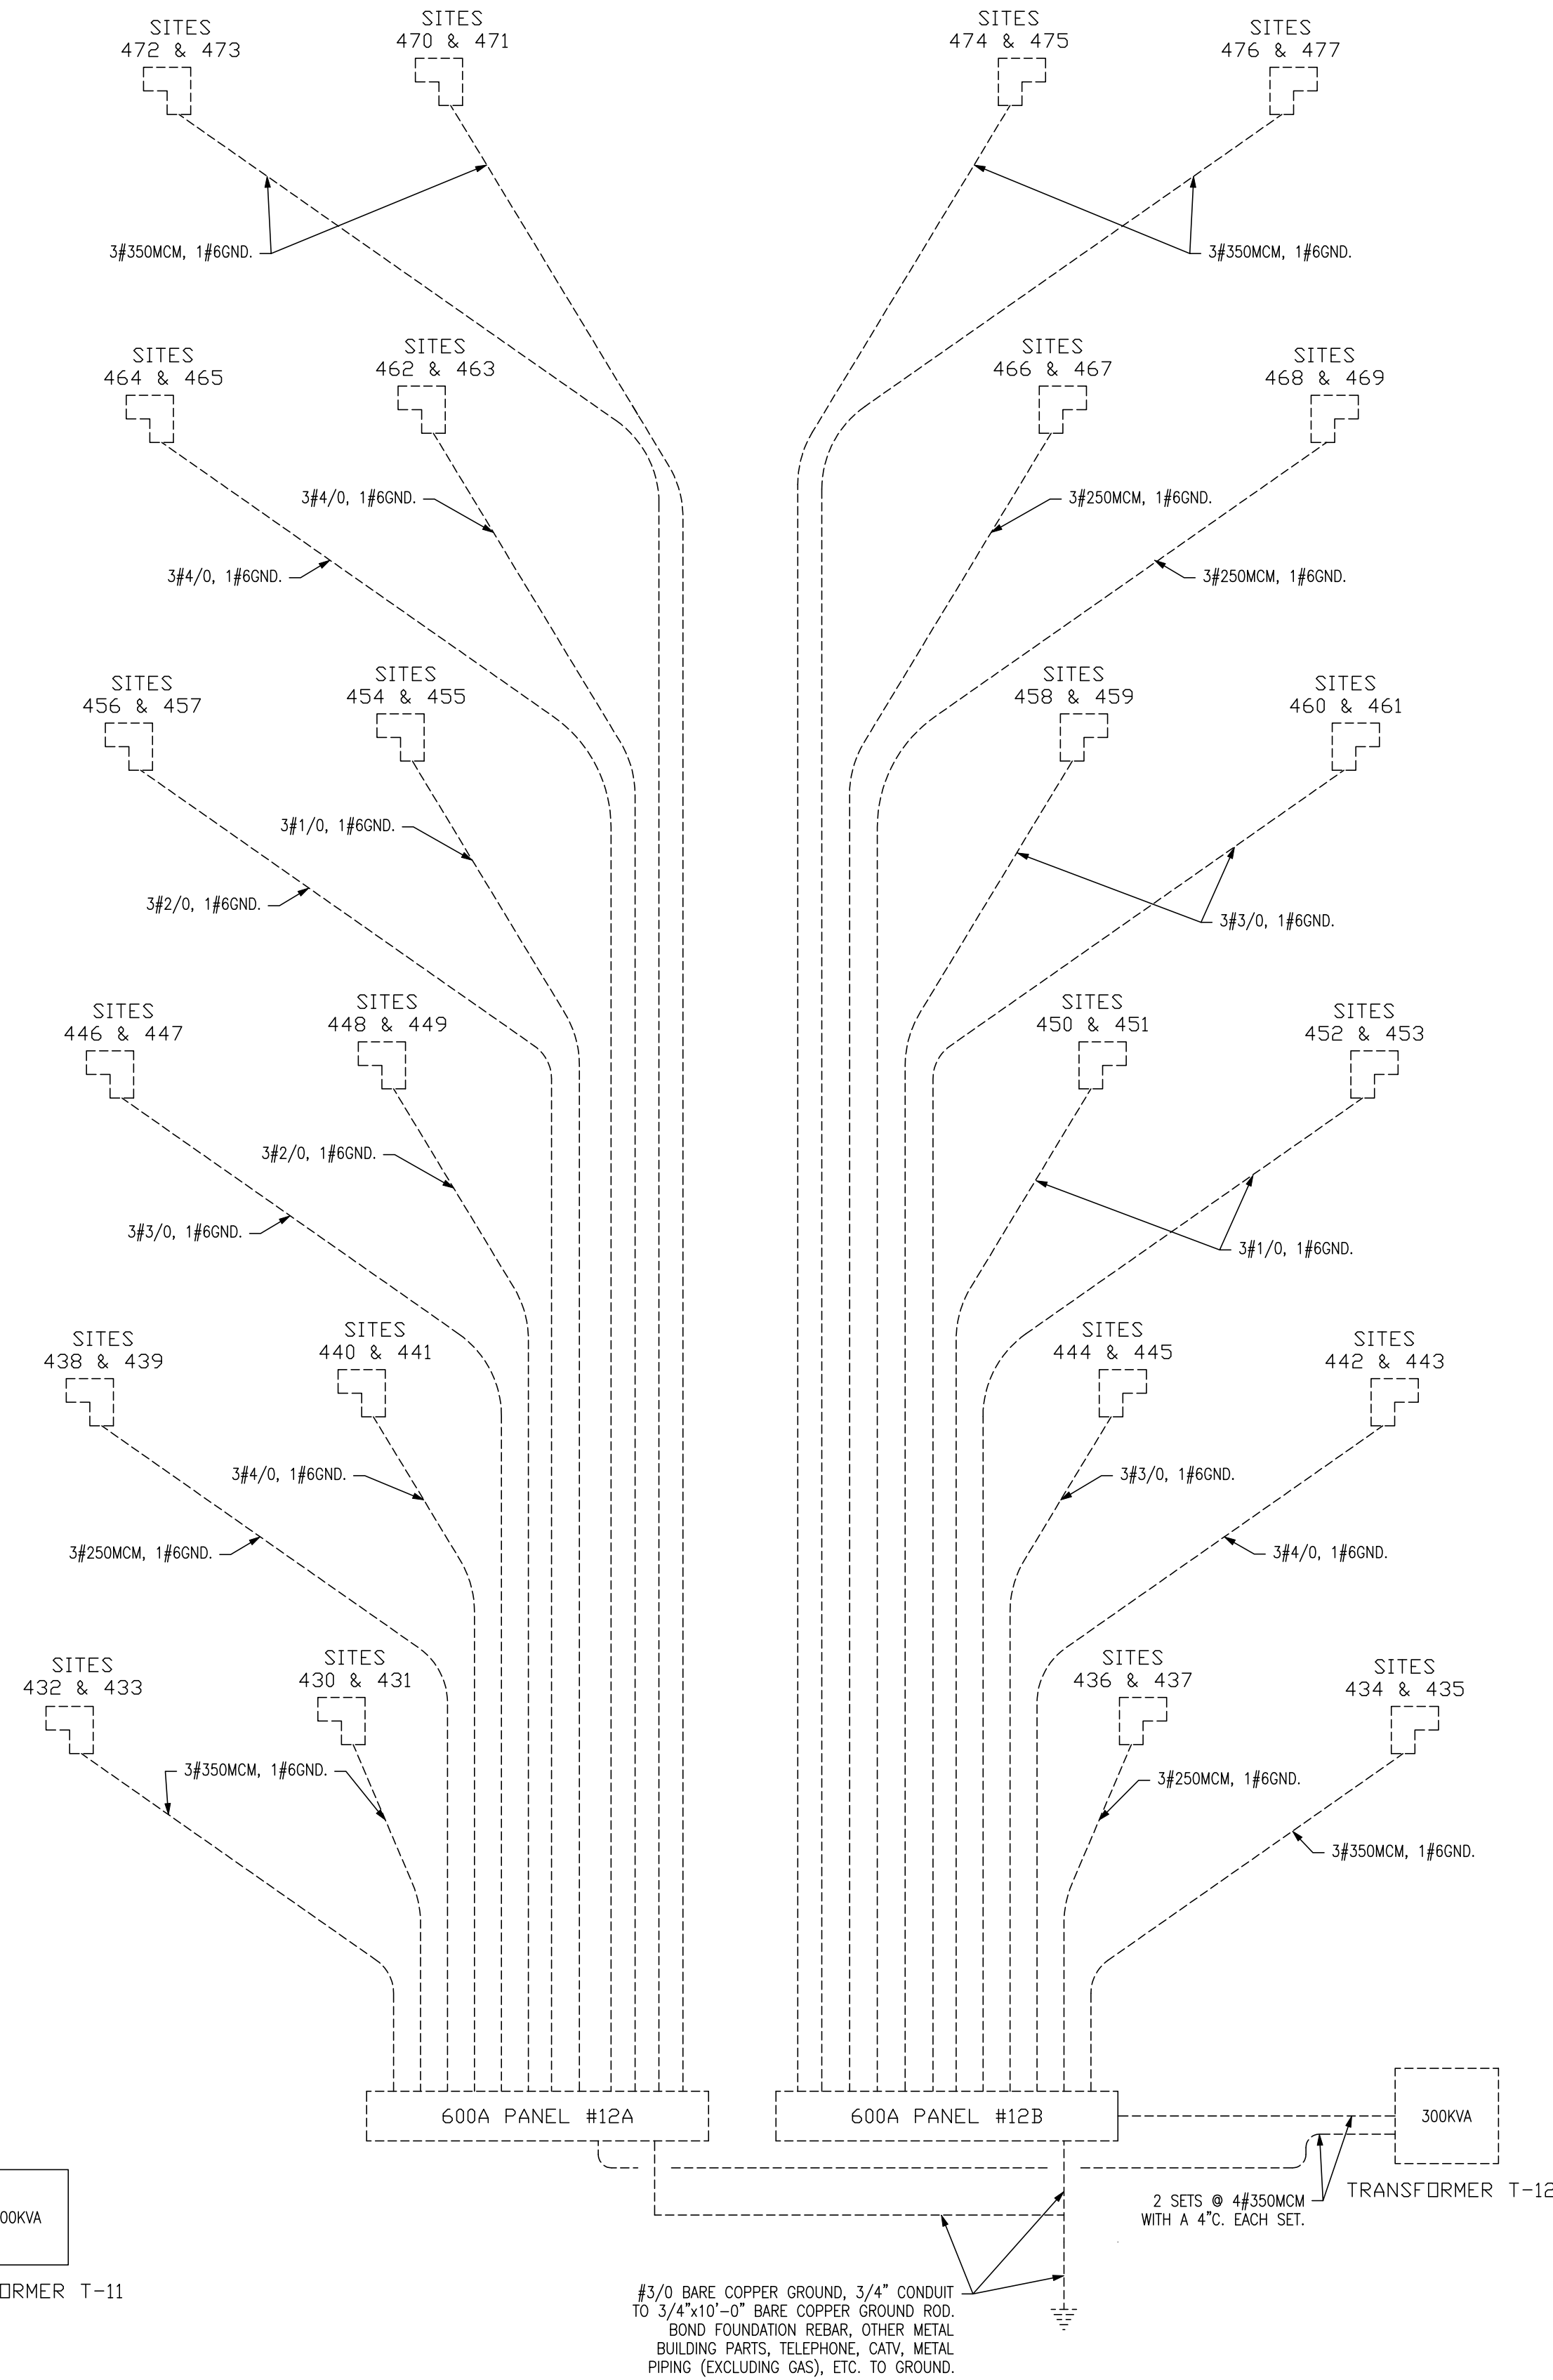

3 **ELECTRIC RISER DIAGRAM**
E6 SCALE: NO SCALE

STATE OF MISSOURI
MIKE KEHOE,
GOVERNOR

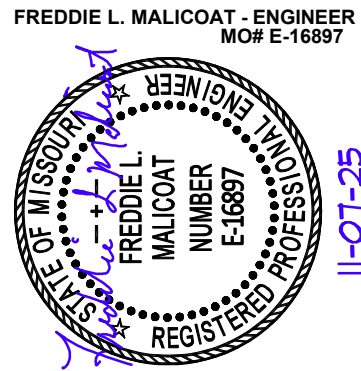

**MALICOAT - WINSLOW
ENGINEERS, INC.**

MISSOURI STATE CERTIFICATE OF AUTHORITY #000421

4840 RANGELINE STREET, #101
COLUMBIA, MISSOURI 65202

FREDDIE MALICOAT, P.E.

OFFICE OF ADMINISTRATION
DIVISION OF FACILITIES
MANAGEMENT,
DESIGN AND CONSTRUCTION

MISSOURI
STATE FAIRGROUNDS

NEW CAMPGROUND
CONSTRUCTION PLANS

MISSOURI
STATE FAIRGROUNDS
2503 W 16th STREET
SEDALIA, MO

PROJECT # F2307-01
SITE # 1501
ASSET # 3511501153

REVISION: _____
DATE: _____
REVISION: _____
DATE: _____
REVISION: _____
DATE: _____
ISSUE DATE: _____

CAD DWG FILE: E-PLN-06
DRAWN BY: JDB
CHECKED BY: FM
DESIGNED BY: FM

SHEET TITLE:
**ELECTRIC RISER
DIAGRAMS**


SHEET NUMBER:

E6


38 OF 43
11/11/2025

T:\job\24\2404\1\24041.dwg, 11/7/2025 12:30:09 PM, JoshB


- NOTE:
1. REFER TO PANEL SCHEDULES ON SHEETS E9-E11 FOR BREAKER SIZES.
 2. REFER TO CAMPGROUND ELECTRIC SERVICES TABLE ON SHEET ME1 FOR RECOMMENDED MINIMUM WIRE SIZES AND LENGTHS.
 3. WIRE SIZES ASSUME COPPER WIRE.
 4. ALL TRANSFORMERS TO BE 15KV TO 208V, 3Ø TRANSFORMERS PER EVERY REQUIREMENTS
 5. DASHED ITEMS DENOTES THEY ARE AN ALTERNATE. SEE PANEL SCHEDULES ON SHEETS E9-E11 AND SHEET C-003 FOR ALTERNATE SCHEDULE.

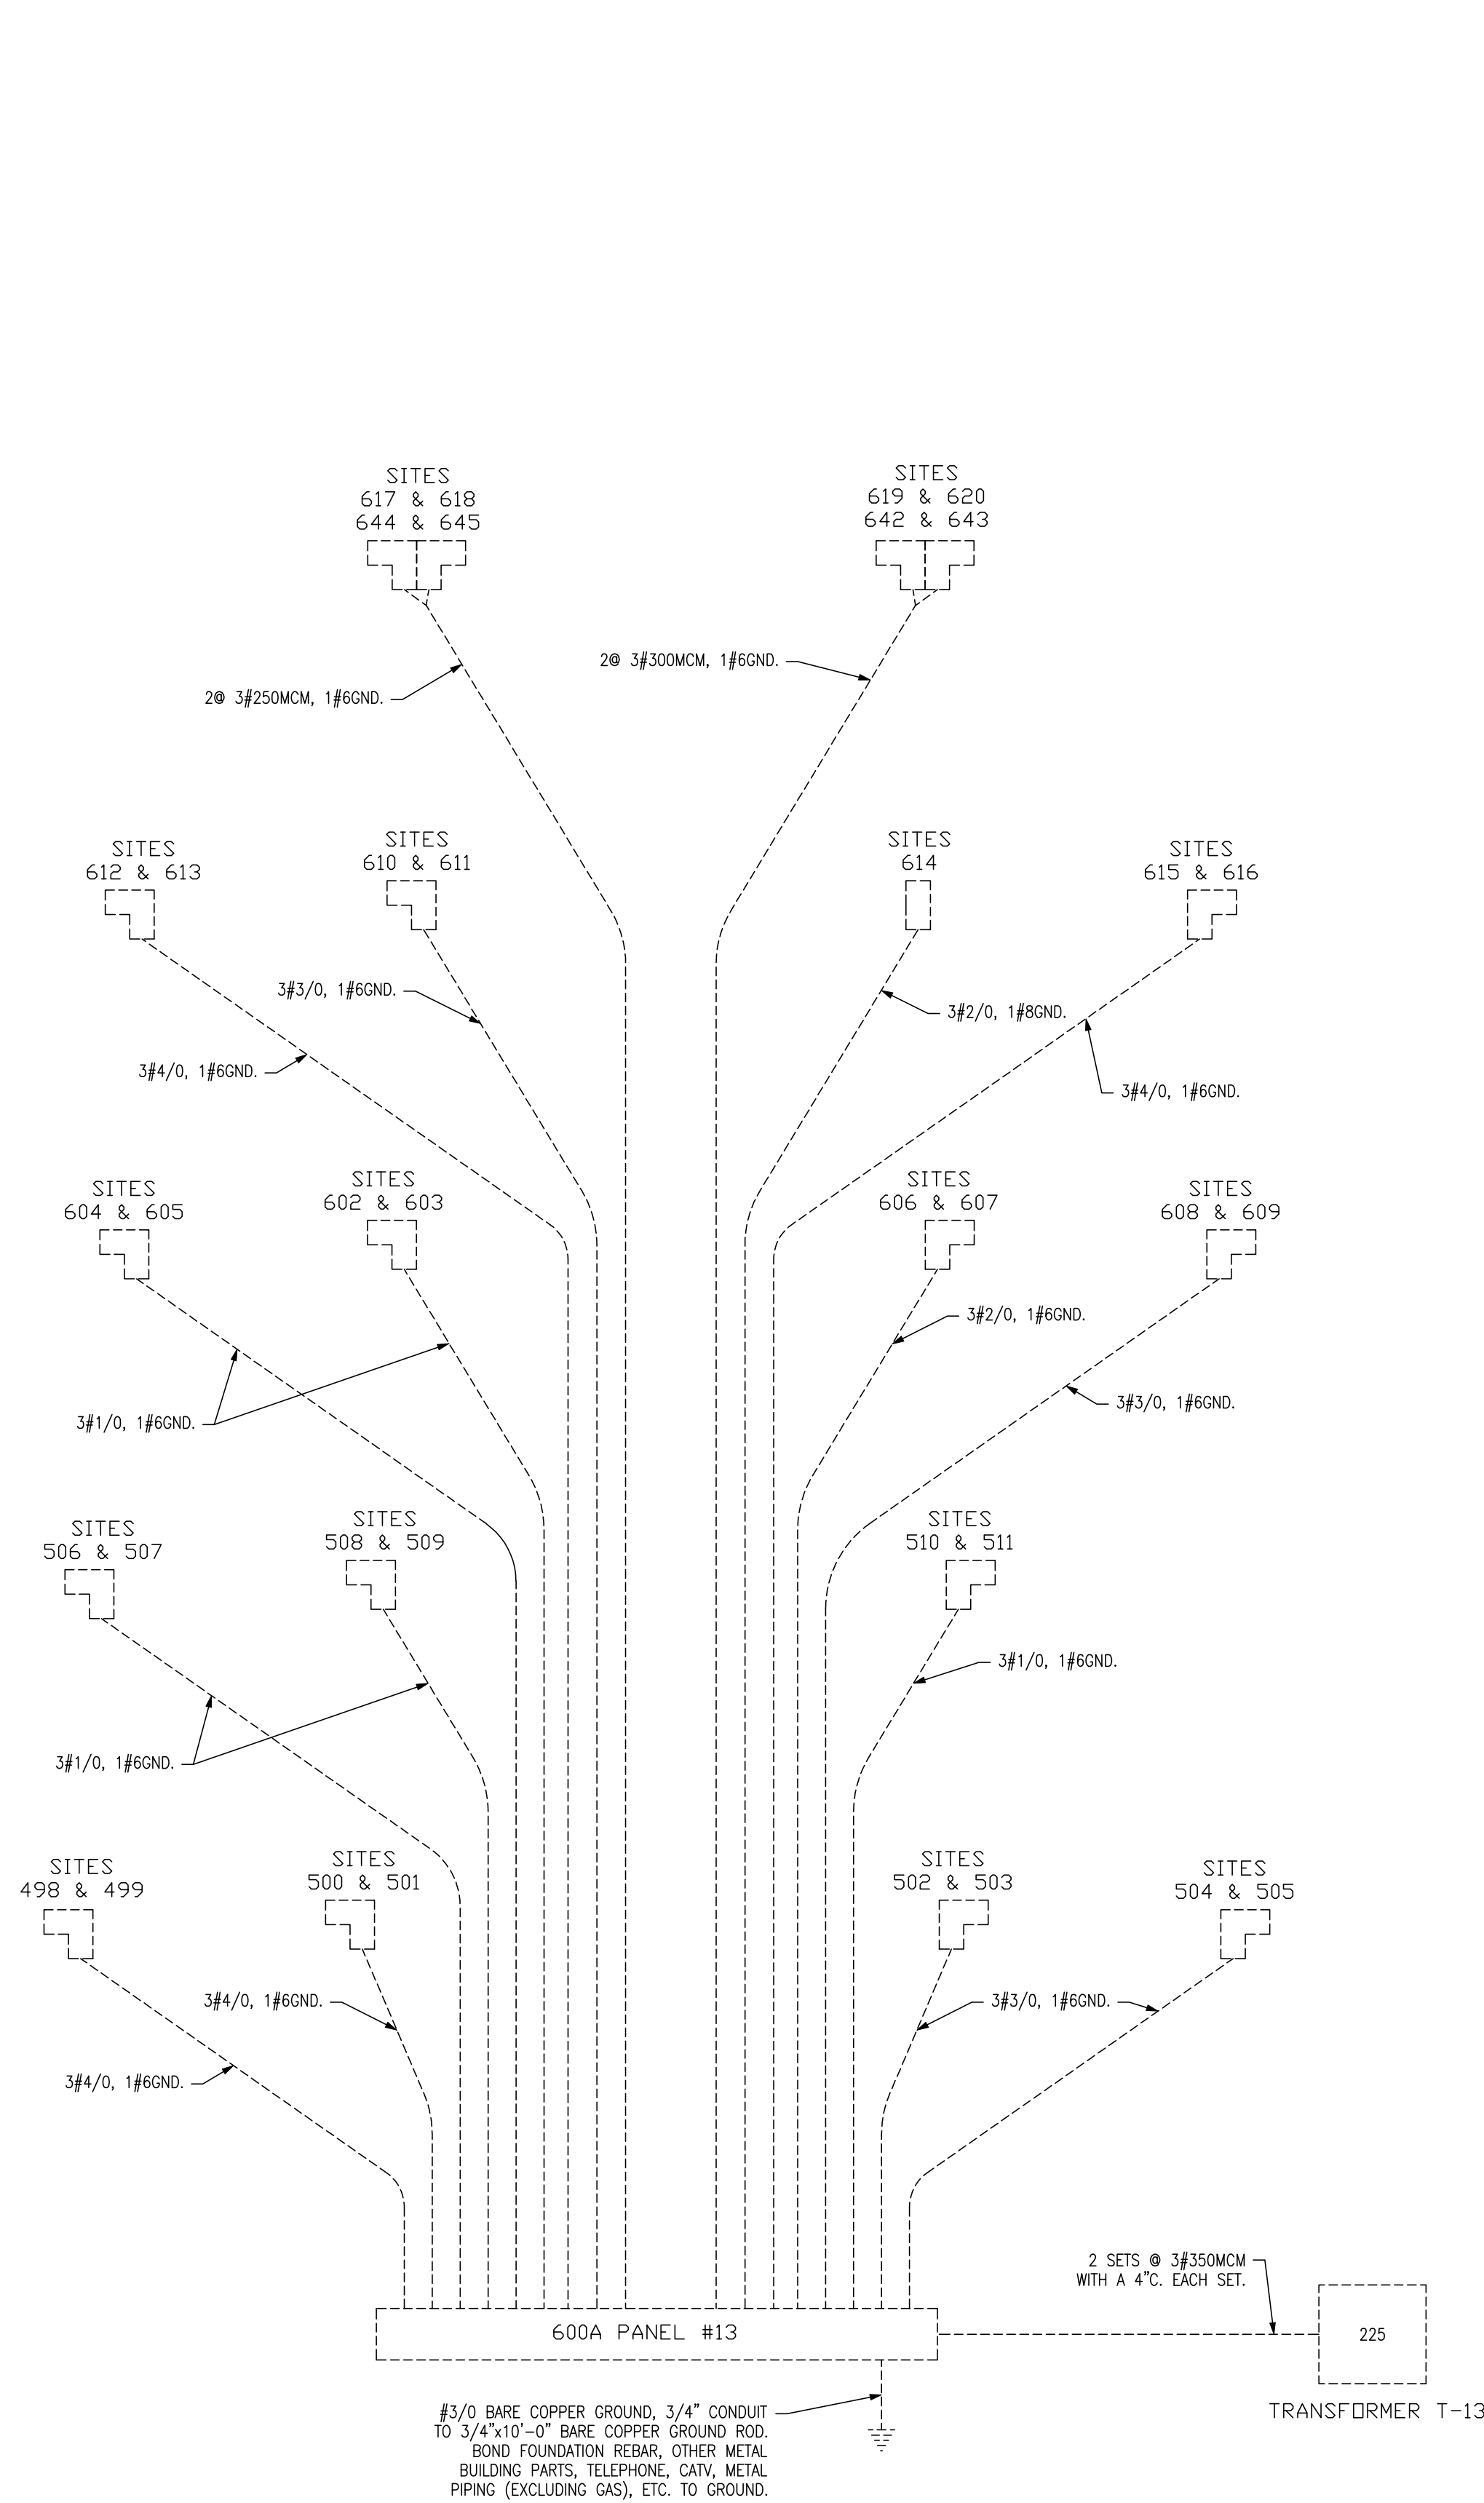

1 ELECTRIC RISER DIAGRAM
E7 SCALE: NO SCALE

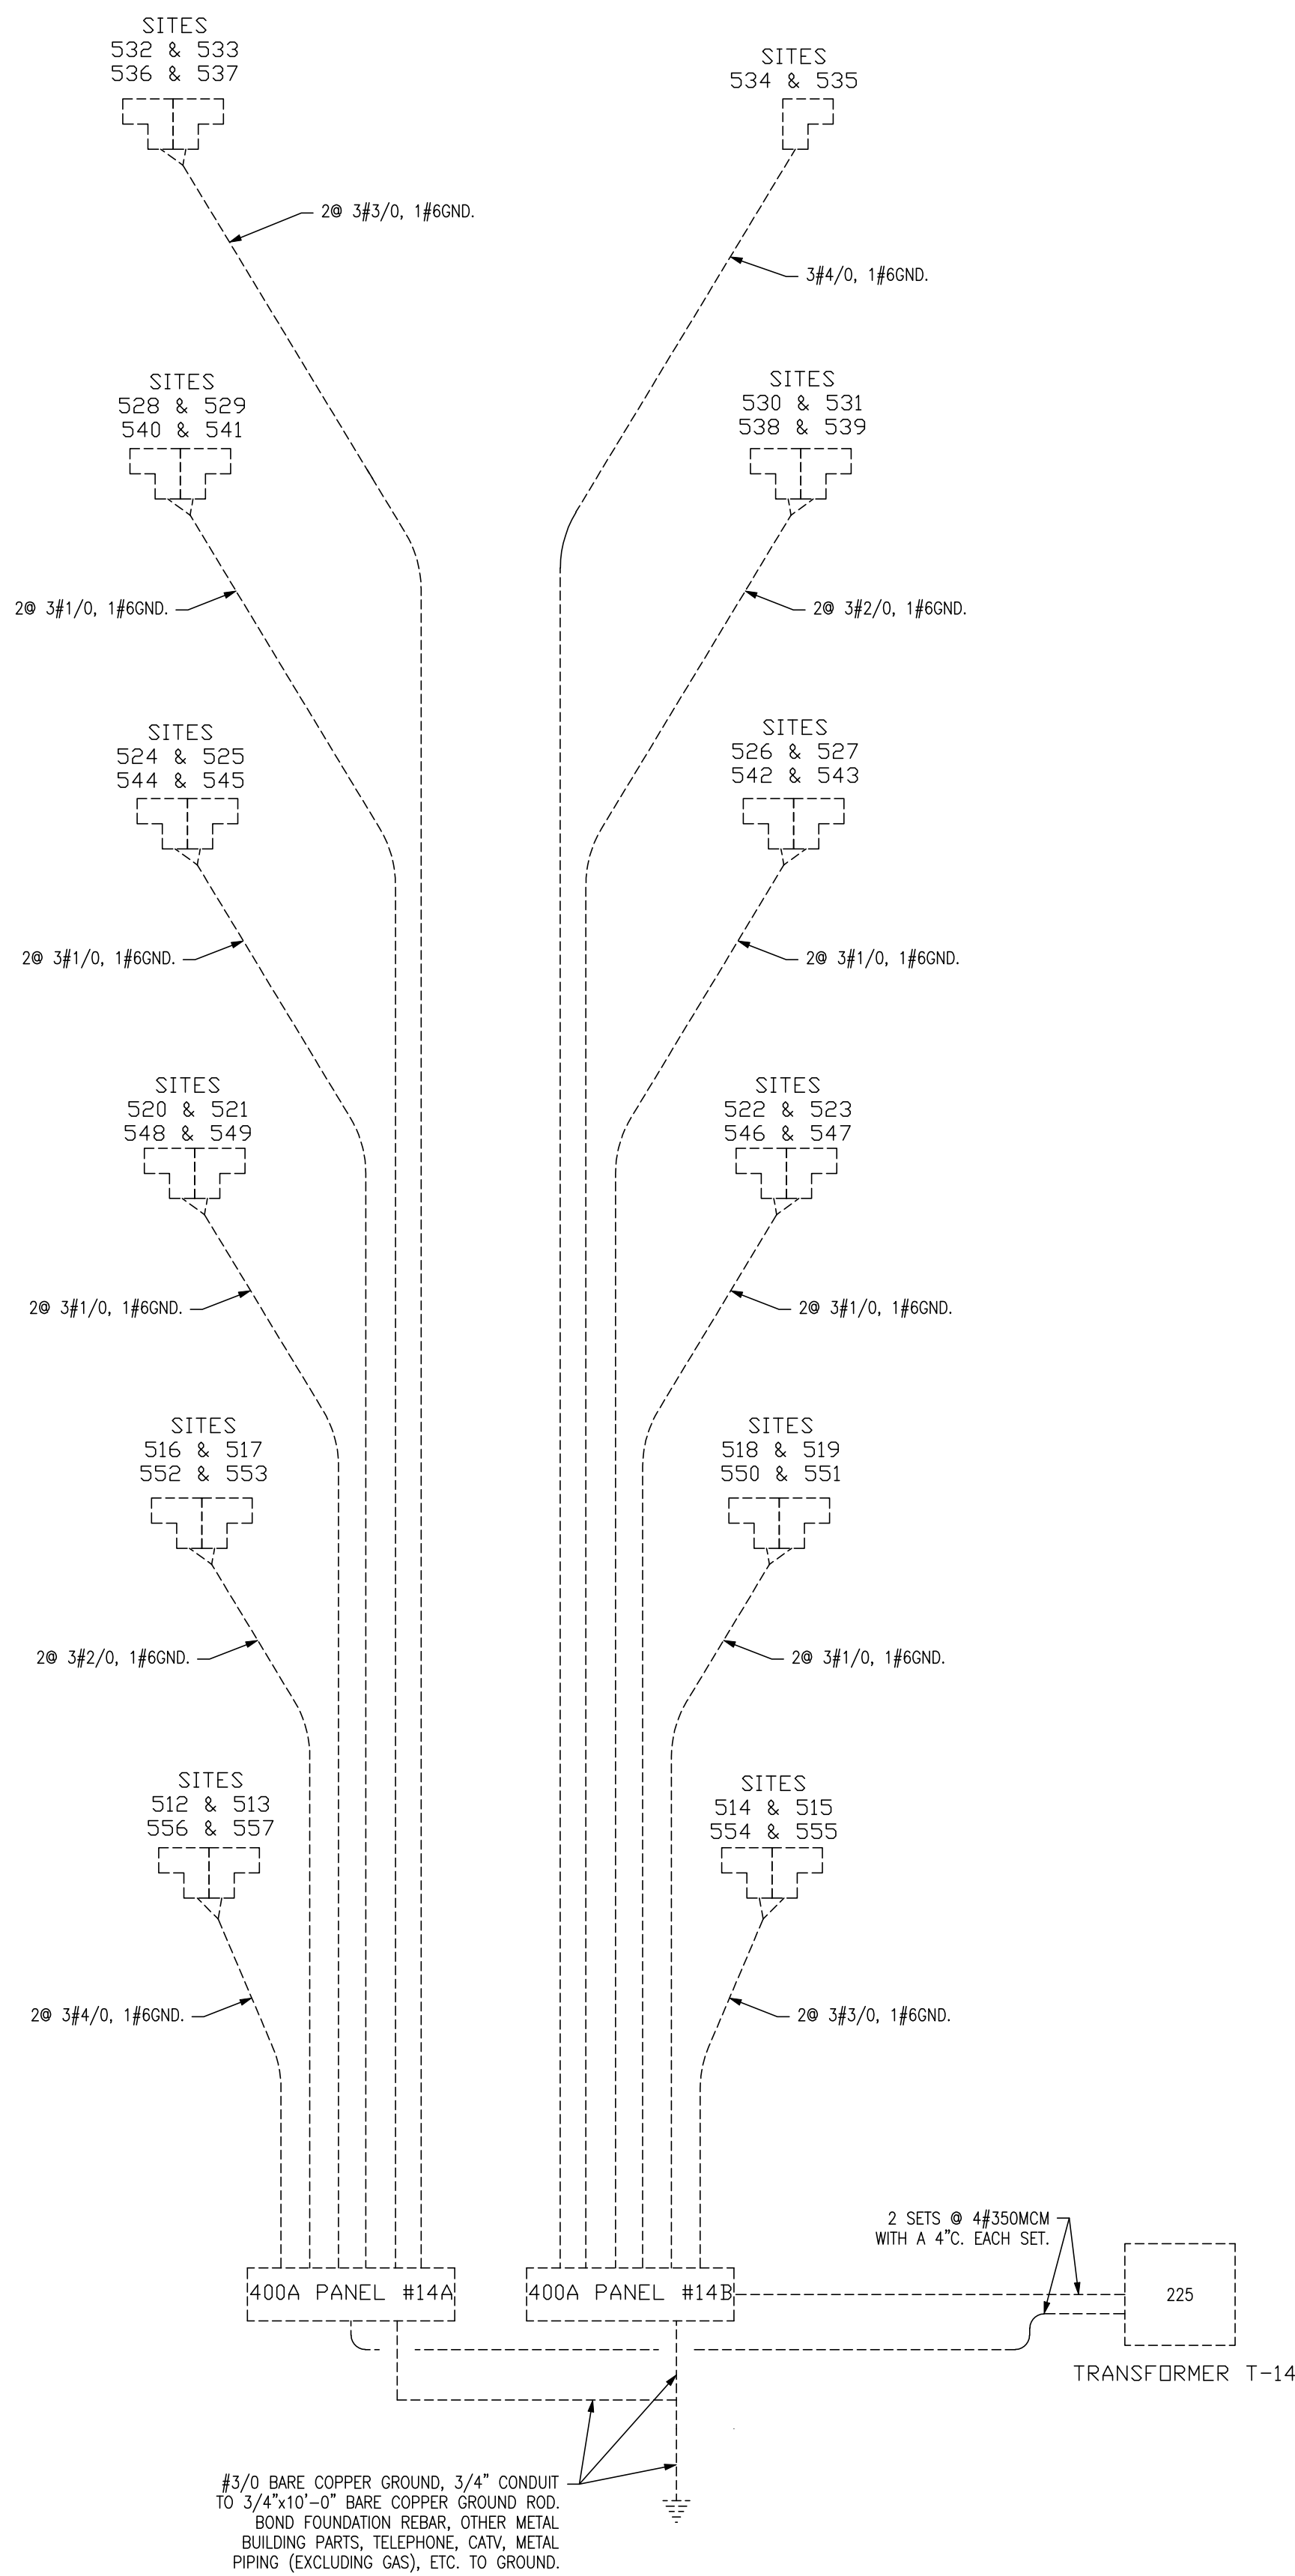


2 ELECTRIC RISER DIAGRAM
E7 SCALE: NO SCALE

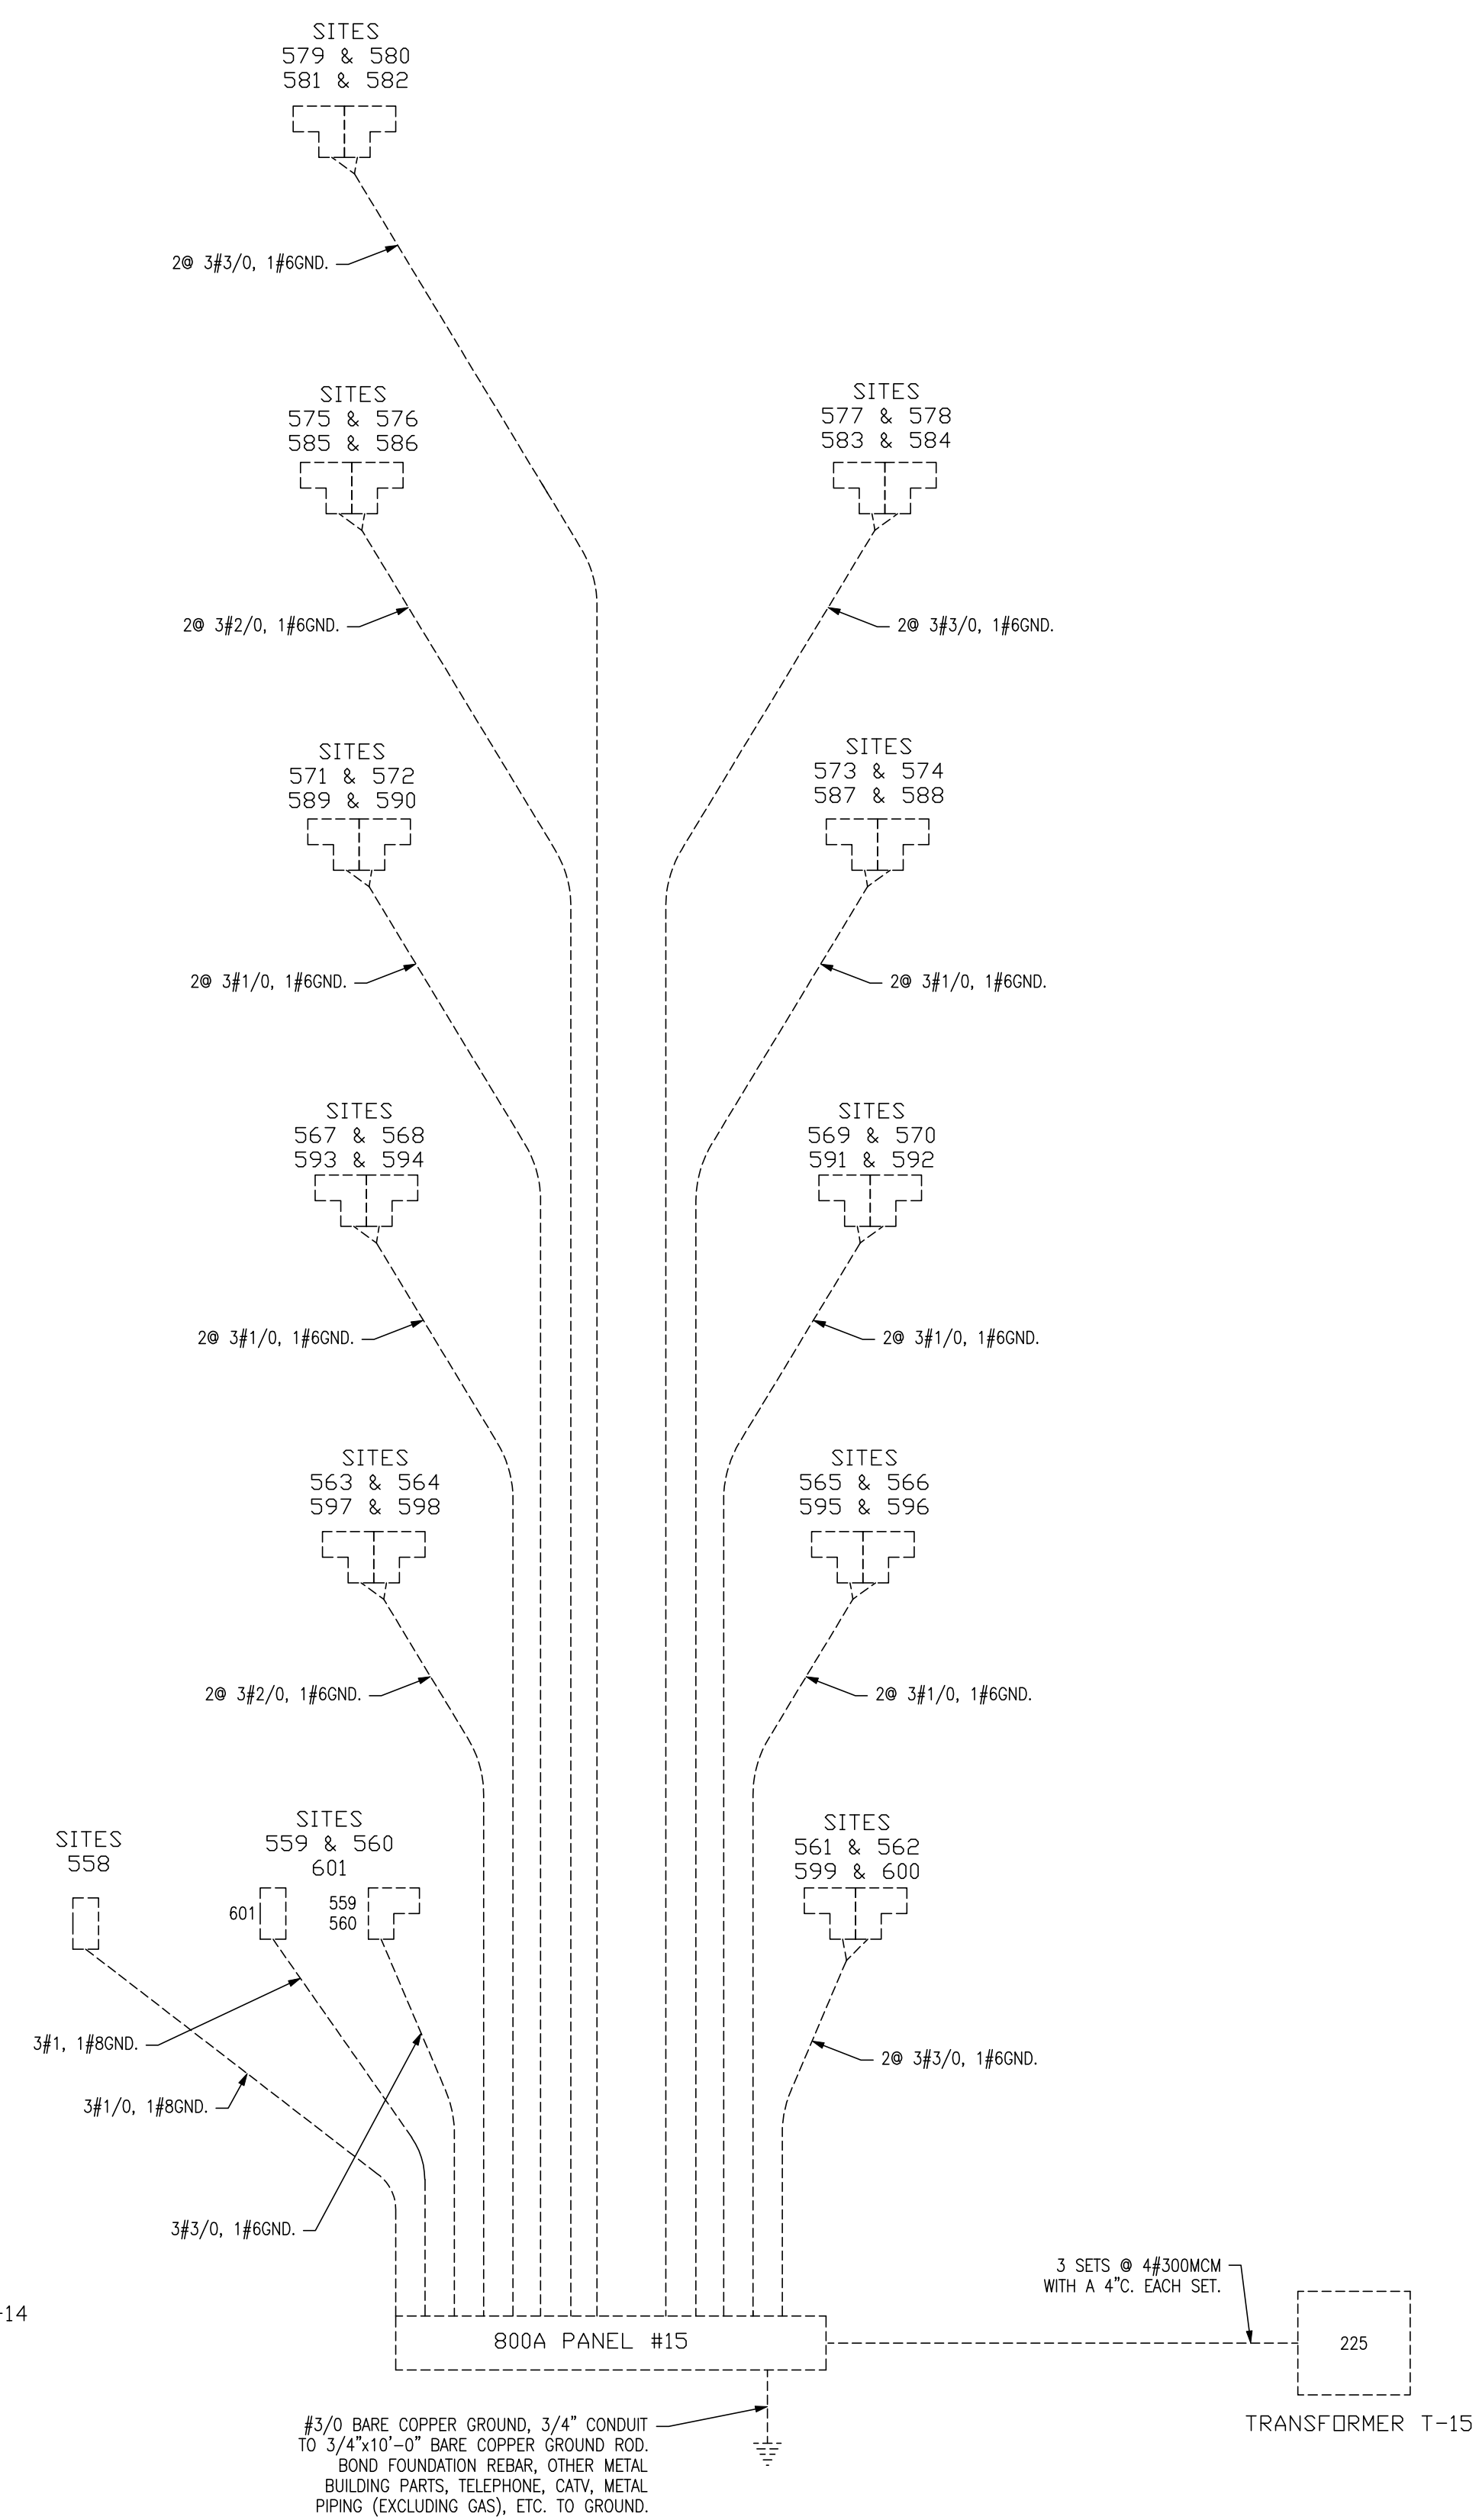

3 ELECTRIC RISER DIAGRAM
E7 SCALE: NO SCALE

STATE OF MISSOURI
MIKE KEHOE,
GOVERNOR

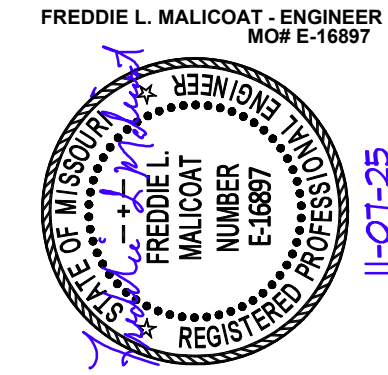

**MALICOAT - WINSLOW
ENGINEERS, INC.**
MISSOURI STATE CERTIFICATE OF AUTHORITY #000421
4840 RANGELINE STREET, #101 TEL 573-875-1300
COLUMBIA, MISSOURI 65202
FREDDIE MALICOAT, P.E.

OFFICE OF ADMINISTRATION
DIVISION OF FACILITIES
MANAGEMENT,
DESIGN AND CONSTRUCTION

MISSOURI
STATE FAIRGROUNDS

NEW CAMPGROUND
CONSTRUCTION PLANS

MISSOURI
STATE FAIRGROUNDS
2503 W 16th STREET
SEDALIA, MO

PROJECT # F2307-01
SITE # 1501
ASSET # 3511501153

REVISION: _____
DATE: _____
REVISION: _____
DATE: _____
REVISION: _____
DATE: _____
ISSUE DATE: _____

CAD DWG FILE: E-PLN-07
DRAWN BY: JDB
CHECKED BY: FM
DESIGNED BY: FM

SHEET TITLE:
**ELECTRIC RISER
DIAGRAMS**


SHEET NUMBER:

E7


39 OF 43
11/11/2025

T:\job024\02404\024041.dwg, 11/7/2025 12:30:07 PM, JoshB


NOTE:
1. REFER TO PANEL SCHEDULES ON SHEETS E9-E11 FOR BREAKER SIZES.
2. REFER TO CAMPGROUND ELECTRIC SERVICES TABLE ON SHEET ME1 FOR RECOMMENDED MINIMUM WIRE SIZES AND LENGTHS.
3. WIRE SIZES ASSUME COPPER WIRE.
4. ALL TRANSFORMERS TO BE 15KV TO 208V, 3Ø TRANSFORMERS PER EVERY REQUIREMENTS
5. DASHED ITEMS DENOTES THEY ARE AN ALTERNATE. SEE PANEL SCHEDULES ON SHEETS E9-E11 AND SHEET C-003 FOR ALTERNATE SCHEDULE.

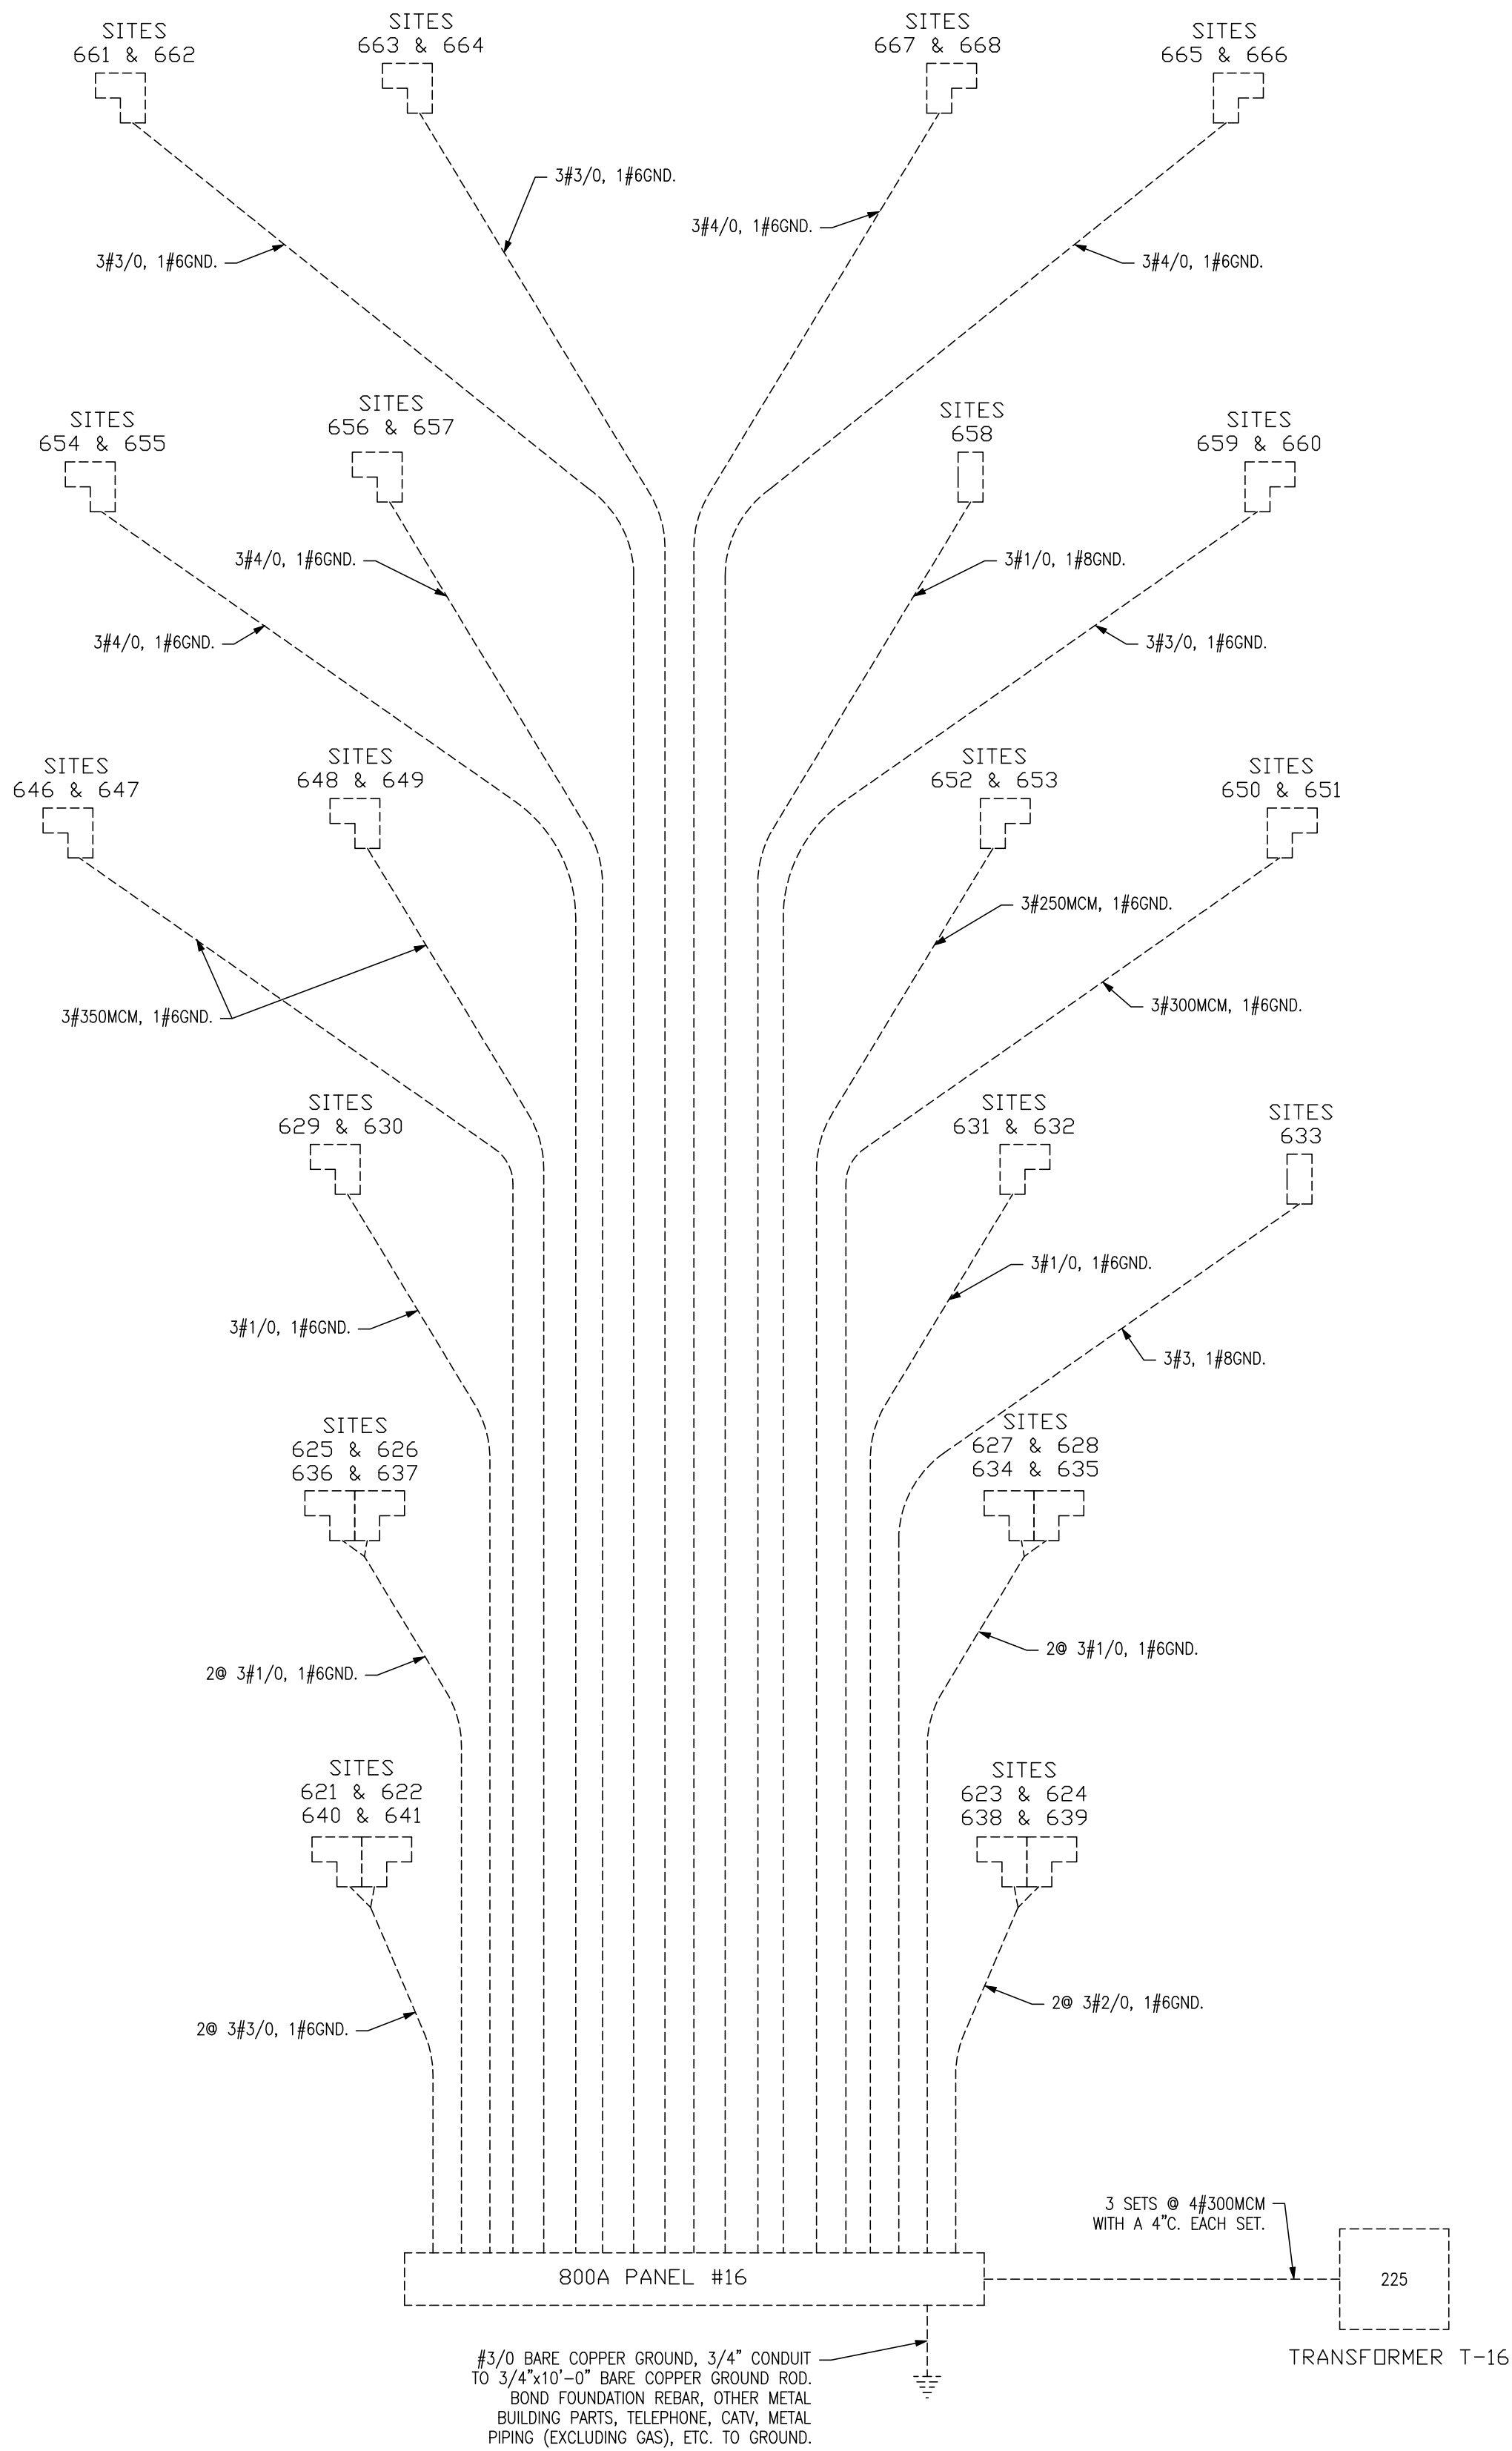

1 ELECTRIC RISER DIAGRAM
E8 SCALE: NO SCALE

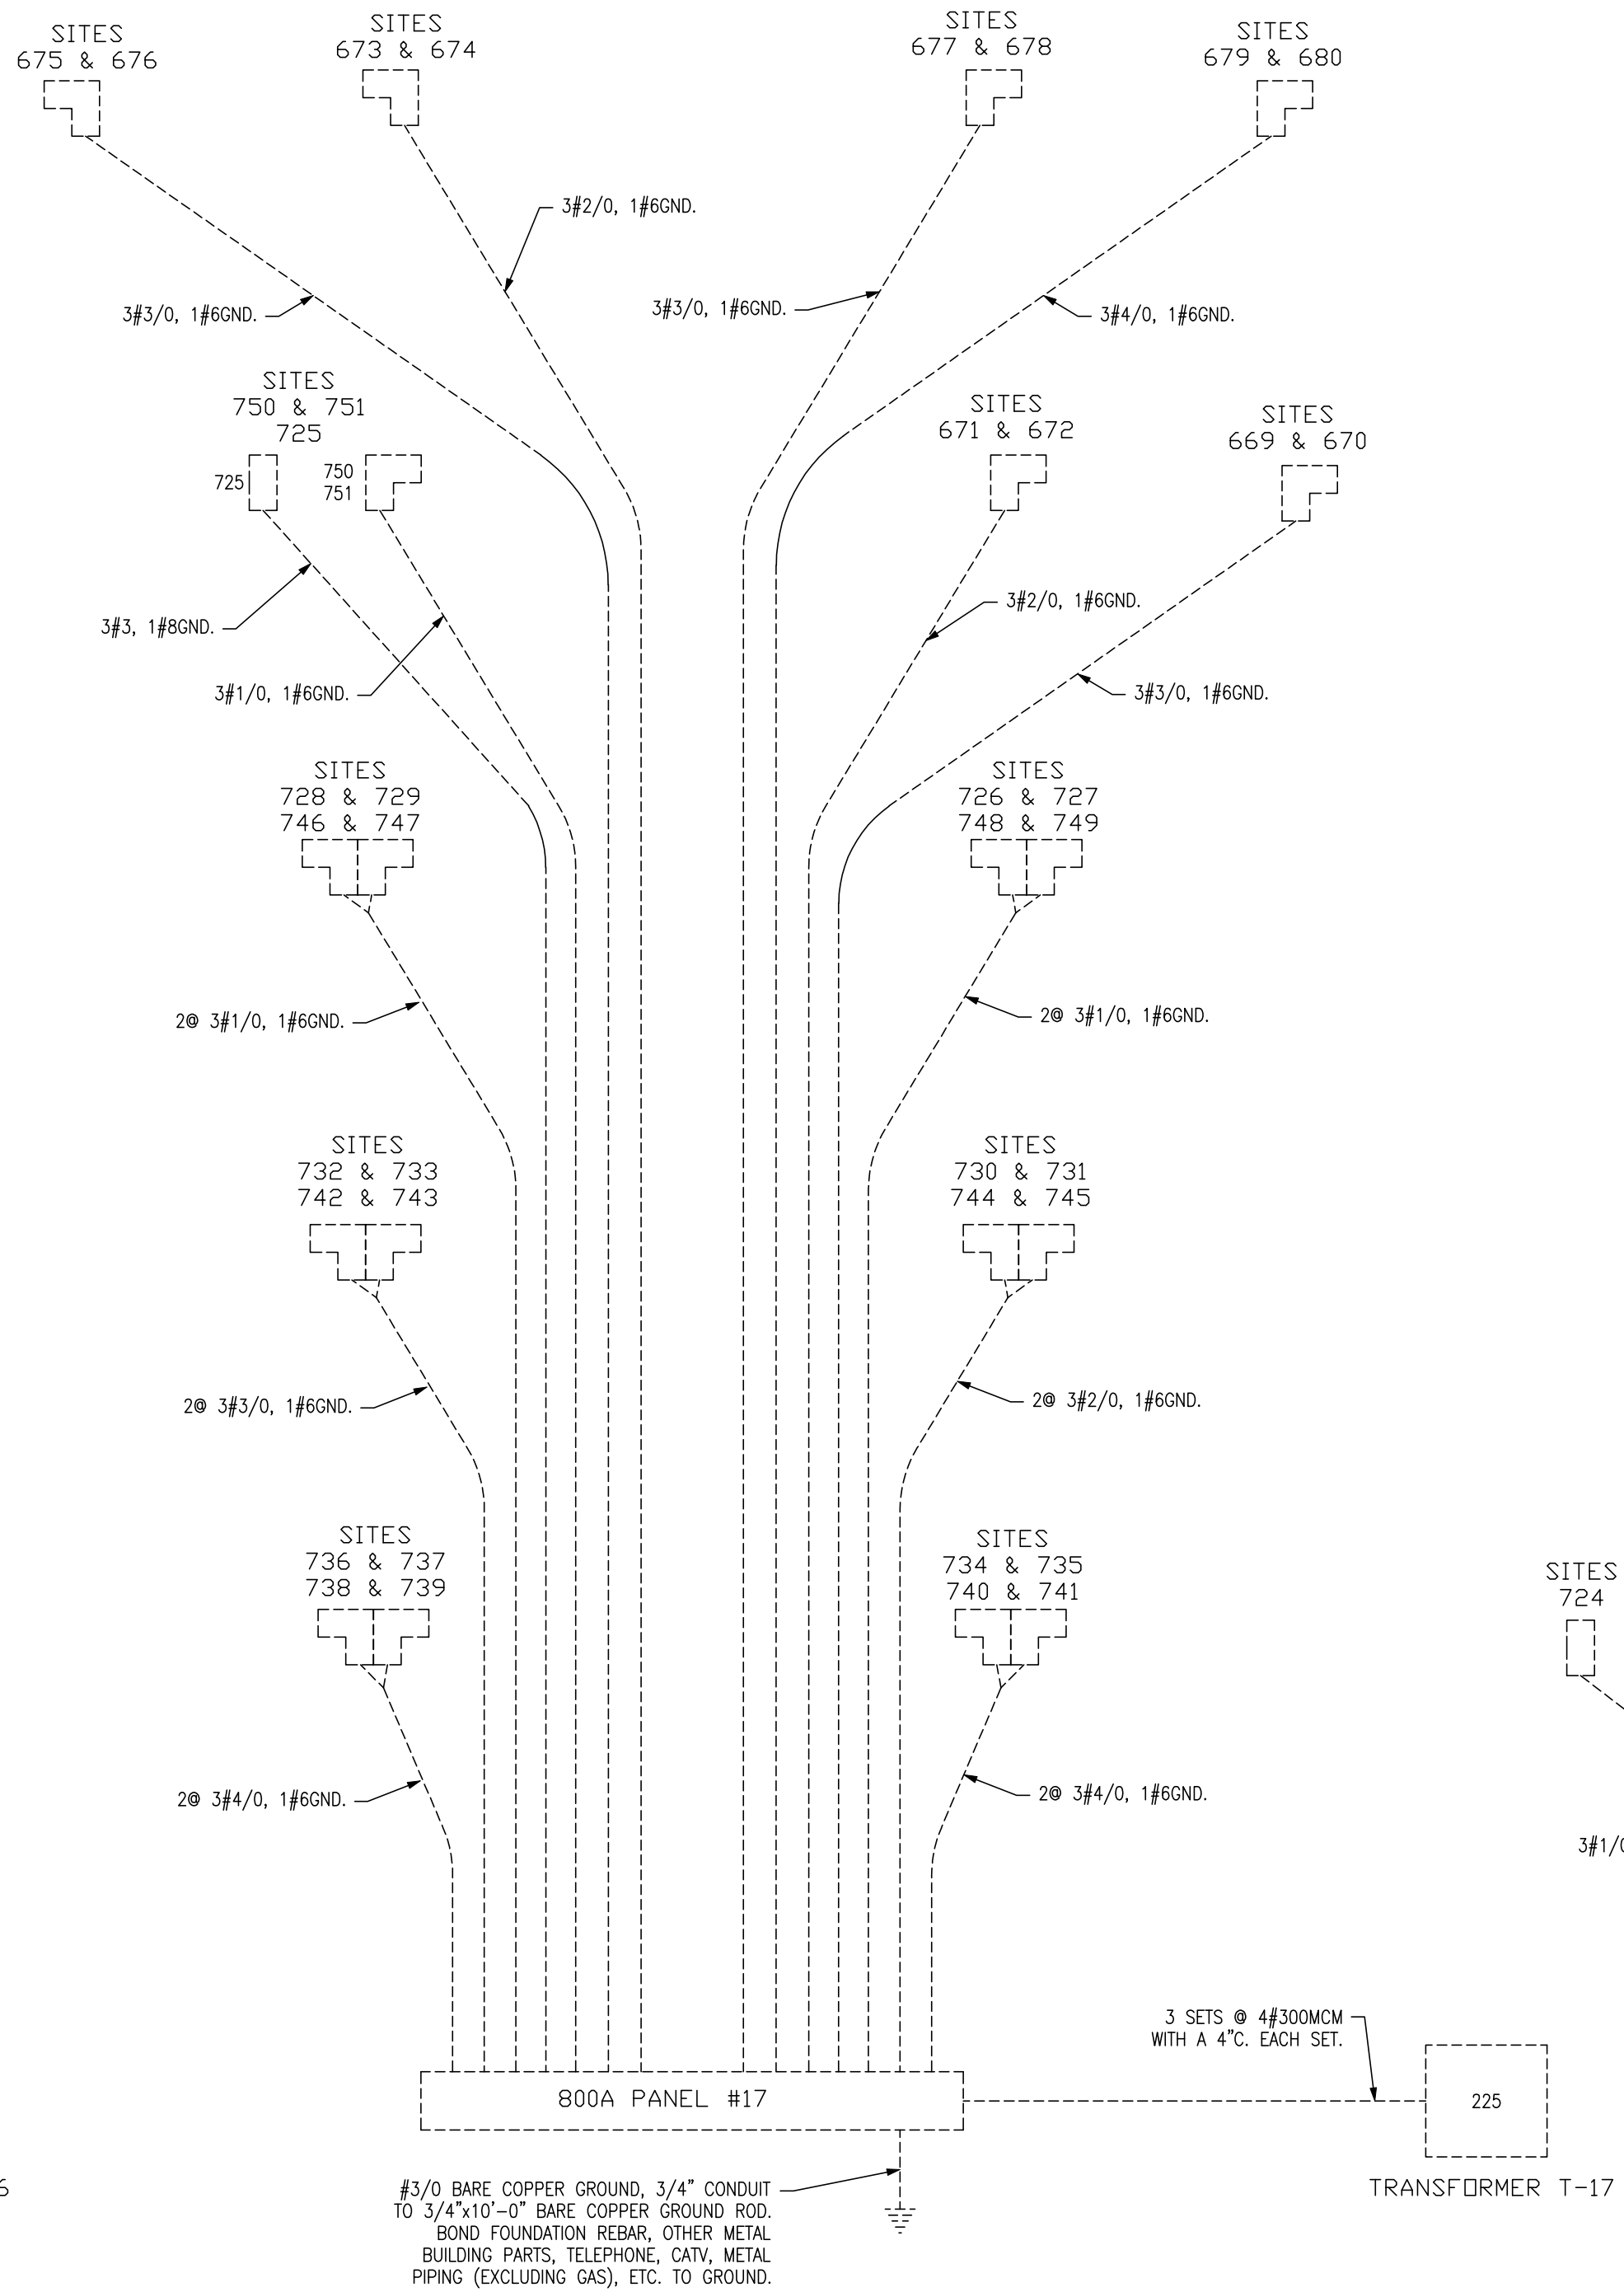


2 ELECTRIC RISER DIAGRAM
E8 SCALE: NO SCALE

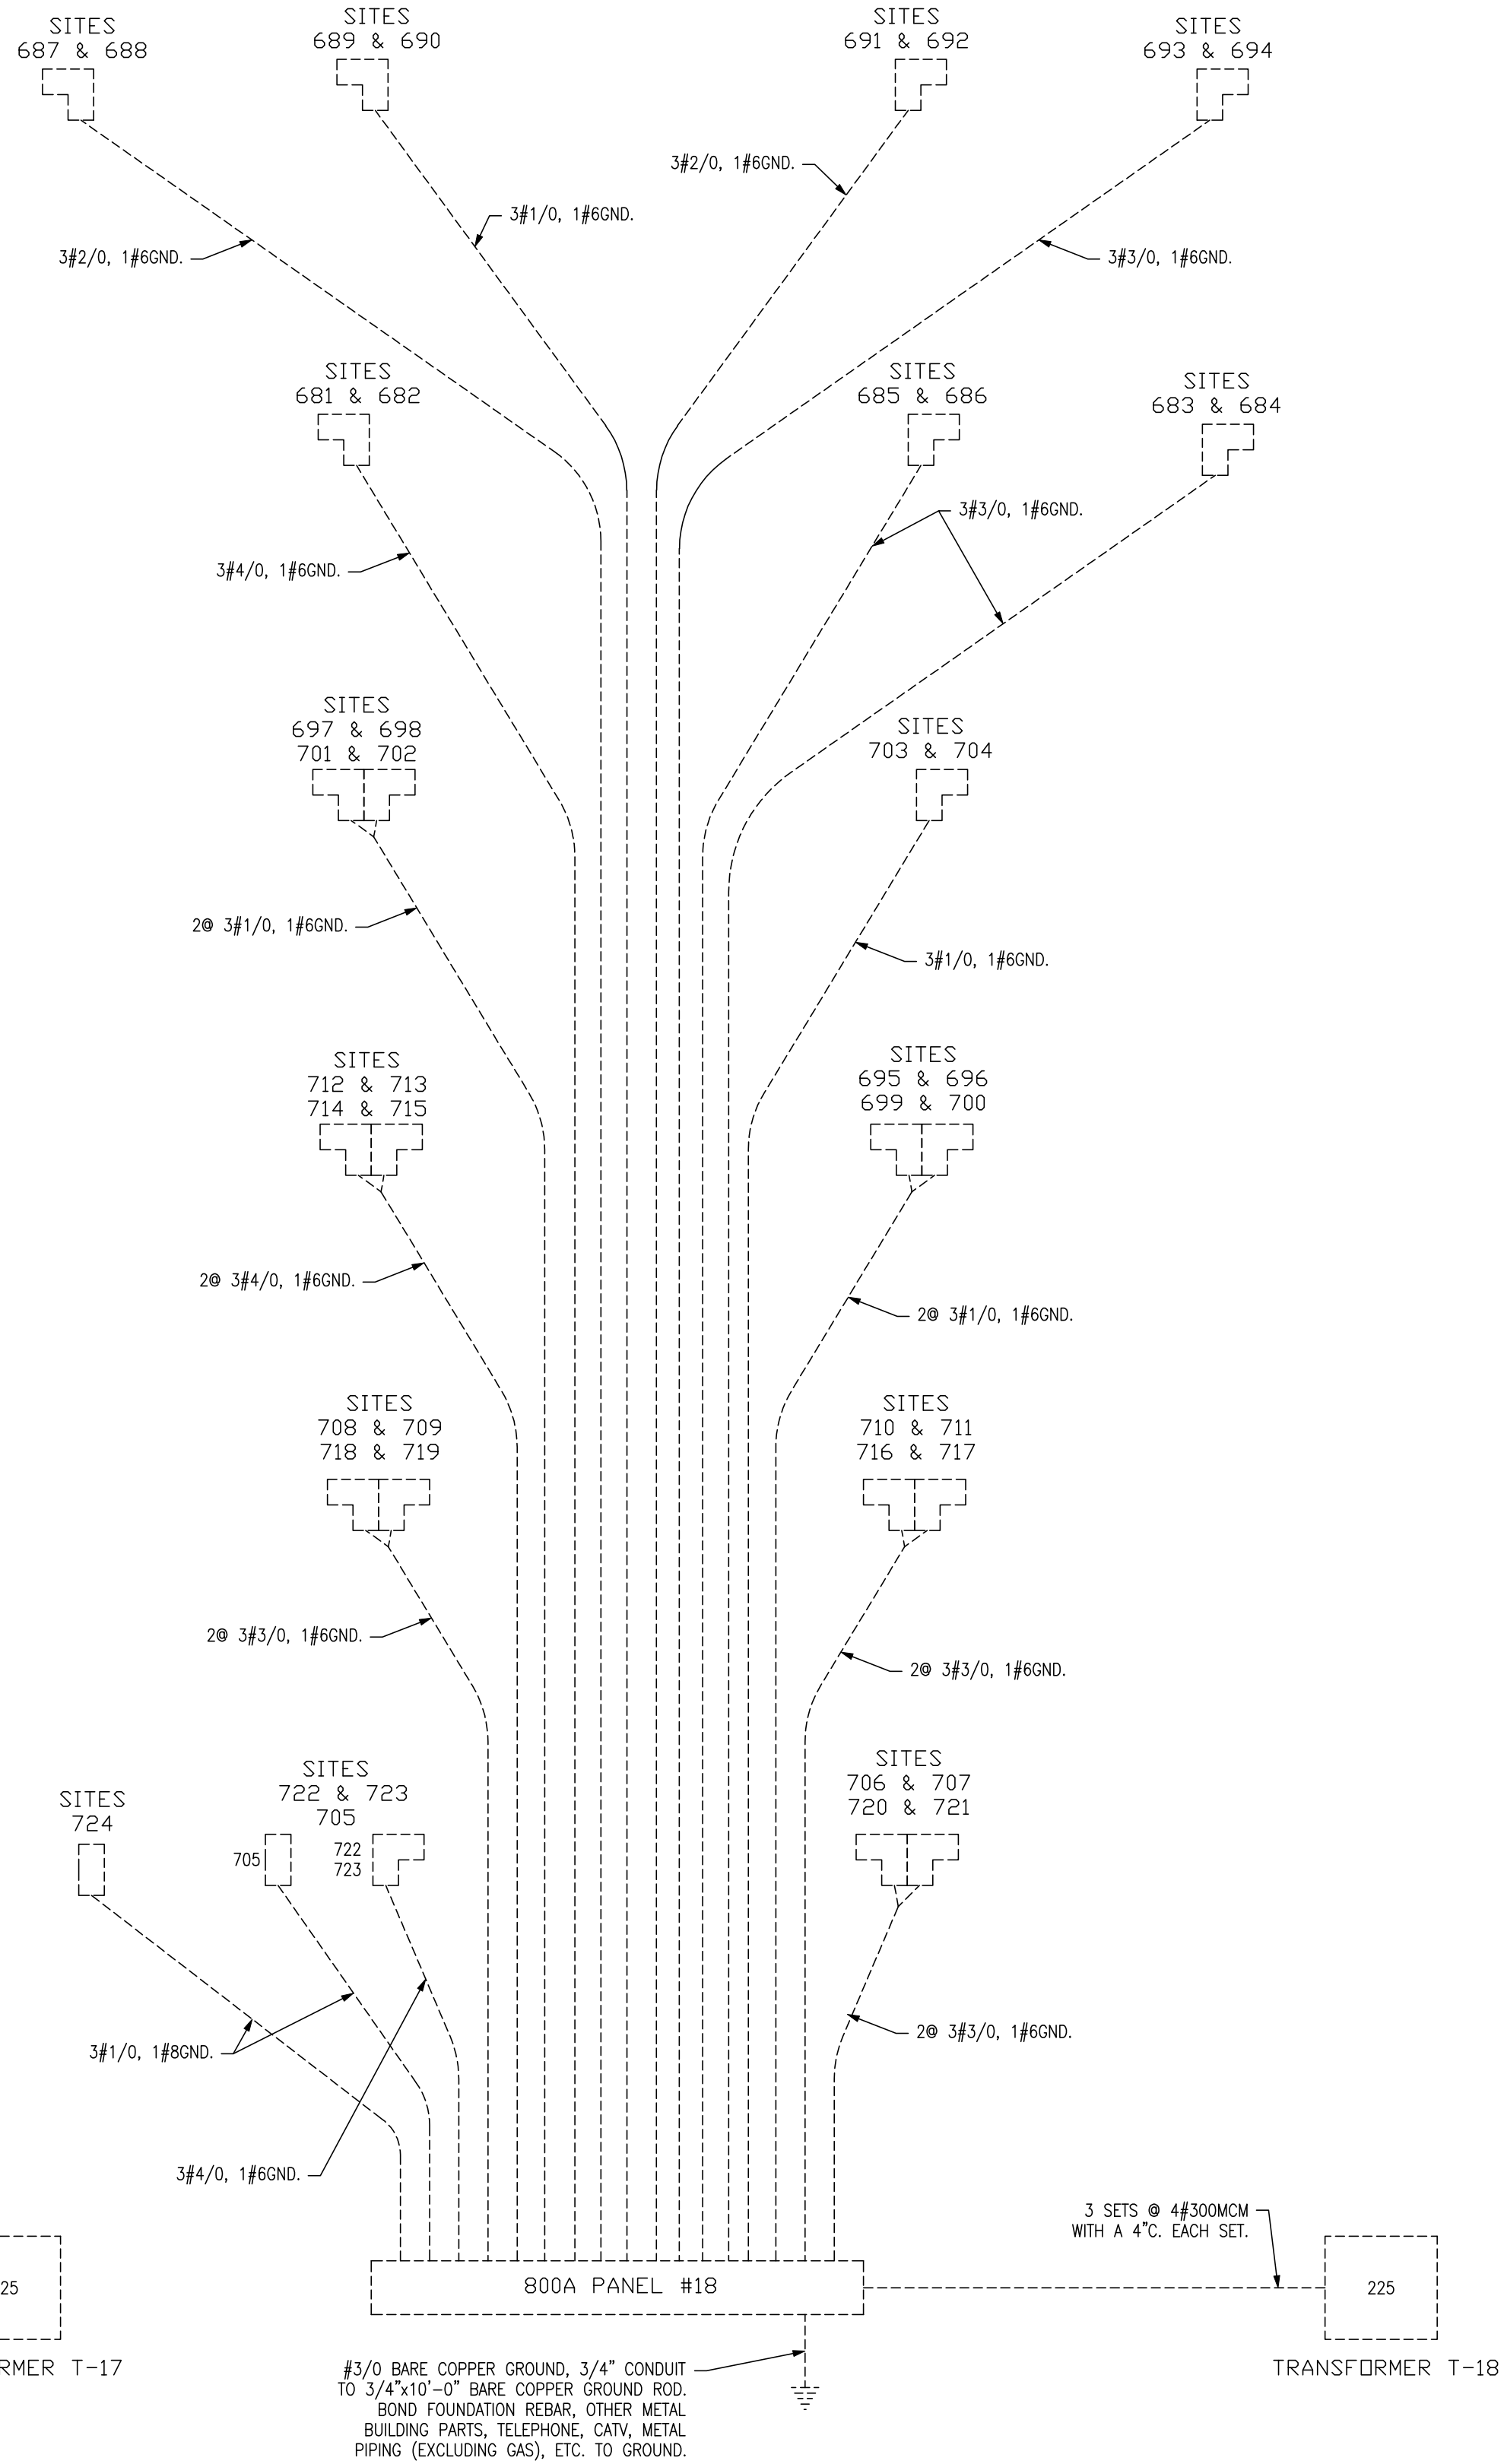

3 ELECTRIC RISER DIAGRAM
E8 SCALE: NO SCALE

STATE OF MISSOURI
MIKE KEHOE,
GOVERNOR

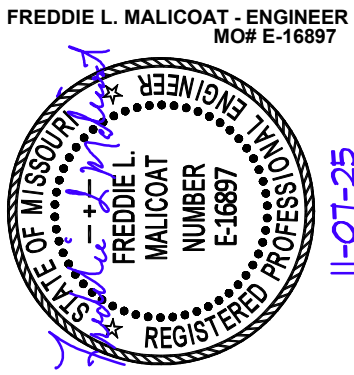

**MALICOAT - WINSLOW
ENGINEERS, INC.**
MISSOURI STATE CERTIFICATE OF AUTHORITY #000421
4840 RANGELINE STREET, #101
COLUMBIA, MISSOURI 65202
TEL 573-875-1300
FREDDIE MALICOAT, P.E.

OFFICE OF ADMINISTRATION
DIVISION OF FACILITIES
MANAGEMENT,
DESIGN AND CONSTRUCTION

MISSOURI
STATE FAIRGROUNDS

NEW CAMPGROUND
CONSTRUCTION PLANS

MISSOURI
STATE FAIRGROUNDS
2503 W 16th STREET
SEDALIA, MO

PROJECT # F2307-01
SITE # 1501
ASSET # 3511501153

REVISION: _____
DATE: _____
REVISION: _____
DATE: _____
REVISION: _____
DATE: _____
ISSUE DATE: _____

CAD DWG FILE: E-PLN-08
DRAWN BY: JDB
CHECKED BY: FM
DESIGNED BY: FM

SHEET TITLE:
**ELECTRIC RISER
DIAGRAMS**

SHEET NUMBER:

E8

40 OF 43
11/11/2025

P1	VOLTS	120/208	MAIN CAPACITY			800 A MCB	A WATTS	156000	
	PHASE	3	BUSS MATERIAL				B WATTS	156000	
	WIRE	4	MOUNTING				C WATTS	144000	
							TOTAL WATTS	456000	
BASE BID						SIMULTANEOUS LOAD		186960	
CIRC	LOCATION / DESCRIPTION		BRKR	WATTS	ø	WATTS	BRKR	LOCATION / DESCRIPTION	CIRC
1	SITE 1,2		150-2	12000	A	12000	150-2	SITE 3,4	2
3	-		-	12000	B	12000	-	-	4
5	SITE 5,6		150-2	12000	C	12000	150-2	SITE 7,8	6
7	-		-	12000	A	12000	-	-	8
9	SITE 9,10		150-2	12000	B	12000	150-2	SITE 11,12	10
11	-		-	12000	C	12000	-	-	12
13	SITE 13,14		150-2	12000	A	12000	150-2	SITE 15,16	14
15	-		-	12000	B	12000	-	-	16
17	SITE 17,18		150-2	12000	C	12000	150-2	SITE 19,20	18
19	-		-	12000	A	12000	-	-	20
21	SITE 21,22		150-2	12000	B	12000	150-2	SITE 23,24	22
23	-		-	12000	C	12000	-	-	24
25	SITE 25,26		150-2	12000	A	12000	150-2	SITE 27,28	26
27	-		-	12000	B	12000	-	-	28
29	SITE 29,30		150-2	12000	C	12000	150-2	SITE 31,32	30
31	-		-	12000	A	12000	-	-	32
33	SITE 374,375		150-2	12000	B	12000	150-2	SITE 376,377	34
35	-		-	12000	C	12000	-	-	36
37	SITE 378,379		150-2	12000	A	0	20-2	SPARE	38
39	-		-	12000	B	0	-	-	40
41	SPARE		20-1	0	C	0	20-1	SPARE	42

P5	VOLTS	120/208	MAIN CAPACITY			800 A MCB	A WATTS	192000	
	PHASE	3	BUSS MATERIAL				B WATTS	168000	
	WIRE	4	MOUNTING				C WATTS	168000	
								TOTAL WATTS	528000
BASE BID							SIMULTANEOUS LOAD	216480	
CIRC	LOCATION / DESCRIPTION		BRKR	WATTS	#	WATTS	BRKR	LOCATION / DESCRIPTION	CIRC
1	SITE 126,127		150-2	12000	A	12000	150-2	SITE 128,129	2
3	-		-	12000	B	12000	-	-	4
5	SITE 130,131		150-2	12000	C	12000	150-2	SITE 132,133	6
7	-		-	12000	A	12000	-	-	8
9	SITE 134,135		150-2	12000	B	12000	150-2	SITE 136,137	10
11	-		-	12000	C	12000	-	-	12
13	SITE 138,139		150-2	12000	A	12000	150-2	SITE 140,141	14
15	-		-	12000	B	12000	-	-	16
17	SITE 142,143		150-2	12000	C	12000	150-2	SITE 144,145	18
19	-		-	12000	A	12000	-	-	20
21	SITE 146,147		150-2	12000	B	12000	150-2	SITE 148,149	22
23	-		-	12000	C	12000	-	-	24
25	SITE 150,151		150-2	12000	A	12000	150-2	SITE 152,153	26
27	-		-	12000	B	12000	-	-	28
29	SITE 154,155		150-2	12000	C	12000	150-2	SITE 156,157	30
31	-		-	12000	A	12000	-	-	32
33	SITE 158,159		150-2	12000	B	12000	150-2	SITE 160,161	34
35	-		-	12000	C	12000	-	-	36
37	SITE 162,163		150-2	12000	A	12000	150-2	SITE 164,165	38
39	-		-	12000	B	12000	-	-	40
41	SITE 166,167		150-2	12000	C	12000	150-2	SITE 168,169	42
43	-		-	12000	A	12000	-	-	44
45	SPARE		20-2	0	B	0	20-2	SPARE	46
47	-		-	0	C	0	-	-	48
49	SPARE		20-2	0	A	0	20-2	SPARE	50
51	-		-	0	B	0	-	-	52
53	SPARE		20-1	0	C	0	20-1	SPARE	54

P2*	VOLTS	120/208	MAIN CAPACITY		600 A MCB	A WATTS	144000		
	PHASE	3	BUSS MATERIAL			B WATTS	120000		
	WIRE	4	MOUNTING			C WATTS	120000		
	TOTAL WATTS						384000		
SIMULTANEOUS LOAD						WATTS	161280		
CIRC	LOCATION / DESCRIPTION		BRKR	WATTS	ø	WATTS	BRKR	LOCATION / DESCRIPTION	CIRC
1	BASE BID - SITE 33,34		150-2	12000	A	12000	150-2	BASE BID - SITE 35,36	2
3	-		-	12000	B	12000	-	-	4
5	BASE BID - SITE 37,38		150-2	12000	C	12000	150-2	BASE BID - SITE 39,40	6
7	-		-	12000	A	12000	-	-	8
9	BASE BID - SITE 41,42		150-2	12000	B	12000	150-2	BASE BID - SITE 43,44	10
11	-		-	12000	C	12000	-	-	12
13	ALTERNATE #1 - SITE 45,46		150-2	12000	A	12000	150-2	ALTERNATE #1 - SITE 47,48	14
15	-		-	12000	B	12000	-	-	16
17	ALTERNATE #1 - SITE 49,50		150-2	12000	C	12000	150-2	ALTERNATE #1 - SITE 51,52	18
19	-		-	12000	A	12000	-	-	20
21	ALTERNATE #1 - SITE 53,54		150-2	12000	B	12000	150-2	ALTERNATE #1 - SITE 55,56	22
23	-		-	12000	C	12000	-	-	24
25	ALTERNATE #1 - SITE 57,58		150-2	12000	A	12000	150-2	ALTERNATE #1 - SITE 59,60	26
27	-		-	12000	B	12000	-	-	28
29	ALTERNATE #1 - SITE 61,62		150-2	12000	C	12000	150-2	ALTERNATE #1 - SITE 63,64	30
31	-		-	12000	A	12000	-	-	32
33	SPARE		20-2	0	B	0	20-2	SPARE	34
35	-		-	0	C	0	-	-	36
37	SPARE		20-2	0	A	0	20-2	SPARE	38
39	-		-	0	B	0	-	-	40
41	SPARE		20-1	0	C	0	20-1	SPARE	42

* IF ALTERNATE #1 IS NOT CHOSEN, ALTERNATE #1 BREAKERS ARE TO BE INCLUDED AS SPARE.

P6	VOLTS	120/208	MAIN CAPACITY			800 A MCB	A WATTS	192000	
	PHASE	3	BUSS MATERIAL				B WATTS	168000	
	WIRE	4	MOUNTING				C WATTS	168000	
								TOTAL WATTS	528000
							SIMULTANEOUS LOAD	216480	
BASE BID									
CIRC	LOCATION / DESCRIPTION		BRKR	WATTS	ø	WATTS	BRKR	LOCATION / DESCRIPTION	CIRC
1	SITE 170,171		150-2	12000	A	12000	150-2	SITE 172,173	2
3	-		-	12000	B	12000	-	-	4
5	SITE 174,175		150-2	12000	C	12000	150-2	SITE 176,177	6
7	-		-	12000	A	12000	-	-	8
9	SITE 178,179		150-2	12000	B	12000	150-2	SITE 180,181	10
11	-		-	12000	C	12000	-	-	12
13	SITE 182,183		150-2	12000	A	12000	150-2	SITE 184,185	14
15	-		-	12000	B	12000	-	-	16
17	SITE 186,187		150-2	12000	C	12000	150-2	SITE 188,189	18
19	-		-	12000	A	12000	-	-	20
21	SITE 190,191		150-2	12000	B	12000	150-2	SITE 192,193	22
23	-		-	12000	C	12000	-	-	24
25	SITE 194,195		150-2	12000	A	12000	150-2	SITE 196,197	26
27	-		-	12000	B	12000	-	-	28
29	SITE 198,199		150-2	12000	C	12000	150-2	SITE 200,201	30
31	-		-	12000	A	12000	-	-	32
33	SITE 202,203		150-2	12000	B	12000	150-2	SITE 204,205	34
35	-		-	12000	C	12000	-	-	36
37	SITE 206,207		150-2	12000	A	12000	150-2	SITE 208,209	38
39	-		-	12000	B	12000	-	-	40
41	SITE 210,211		150-2	12000	C	12000	150-2	SITE 212,213	42
43	-		-	12000	A	12000	-	-	44
45	SPARE		20-2	0	B	0	20-2	SPARE	46
47	-		-	0	C	0	-	-	48
49	SPARE		20-2	0	A	0	20-2	SPARE	50
51	-		-	0	B	0	-	-	52
53	SPARE		20-1	0	C	0	20-1	SPARE	54

P3*	VOLTS	120/208	MAIN CAPACITY		1200 A MCB	A WATTS	150000	
	PHASE	3	BUSS MATERIAL			B WATTS	156000	
	WIRE	4	MOUNTING			C WATTS	138000	
							TOTAL WATTS	444000
						SIMULTANEOUS LOAD	258040	
ALTERNATE #1 & ALTERNATE #2								
CIRC	LOCATION / DESCRIPTION	BRKR	WATTS	ø	WATTS	BRKR	LOCATION / DESCRIPTION	CIRC
1	ALTERNATE #1 – SITE 65,66	150–2	12000	A	12000	150–2	ALTERNATE #1 – SITE 67,68	2
3	–	–	12000	B	12000	–	–	4
5	ALTERNATE #1 – SITE 69,70	150–2	12000	C	12000	150–2	ALTERNATE #1 – SITE 71,72	6
7	–	–	12000	A	12000	–	–	8
9	ALTERNATE #1 – SITE 73,74	150–2	12000	B	12000	150–2	ALTERNATE #1 – SITE 75,76	10
11	–	–	12000	C	12000	–	–	12
13	ALTERNATE #1 – SITE 77,78	150–2	12000	A	12000	150–2	ALTERNATE #1 – SITE 79,80	14
15	–	–	12000	B	12000	–	–	16
17	ALTERNATE #1 – SITE 81	80–2	6000	C	12000	150–2	ALTERNATE #2 – SITE 478,479	18
19	–	–	6000	A	12000	–	–	20
21	ALTERNATE #2 – SITE 480,481	150–2	12000	B	12000	150–2	ALTERNATE #2 – SITE 482,483	22
23	–	–	12000	C	12000	–	–	24
25	ALTERNATE #2 – SITE 484,485	150–2	12000	A	12000	150–2	ALTERNATE #2 – SITE 486,487	26
27	–	–	12000	B	12000	–	–	28
29	ALTERNATE #2 – SITE 488,489	150–2	12000	C	12000	150–2	ALTERNATE #2 – SITE 490,491	30
31	–	–	12000	A	12000	–	–	32
33	ALTERNATE #2 – SITE 492,493	150–2	12000	B	12000	150–2	ALTERNATE #2 – SITE 494,495	34
35	–	–	12000	C	12000	–	–	36
37	ALTERNATE #2 – SITE 496,497	150–2	12000	A	0	400–3	SPARE	38
39	–	–	12000	B	0	–	–	40
41	SPARE	20–2	0	C	0	–	–	42
43	–	–	0	A	0	20–2	SPARE	44
45	SPARE	20–2	0	B	0	–	–	46
47	–	–	0	C	0	20–2	SPARE	48
49	SPARE	20–2	0	A	0	–	–	50
51	–	–	0	B	0	20–1	SPARE	52
53	SPARE	20–1	0	C	0	20–1	SPARE	54

* IF ALTERNATE #1 IS CHOSEN, AND ALTERNATE #2 IS NOT CHOSEN, THE BREAKERS FOR ALTERNATE #2 ARE TO BE INCLUDED AS SPARE.

P7	VOLTS	120/208	MAIN CAPACITY			800 A MCB	A WATTS	186000	
	PHASE	3	BUSS MATERIAL				B WATTS	168000	
	WIRE	4	MOUNTING				C WATTS	174000	
	TOTAL WATTS							528000	
SIMULTANEOUS LOAD							216480		
BASE BID									
CIRC	LOCATION / DESCRIPTION		BRKR	WATTS	ø	WATTS	BRKR	LOCATION / DESCRIPTION	CIRC
1	SITE 214,215		150-2	12000	A	12000	150-2	SITE 216,217	2
3	-		-	12000	B	12000	-	-	4
5	SITE 218,219		150-2	12000	C	12000	150-2	SITE 220,221	6
7	-		-	12000	A	12000	-	-	8
9	SITE 222,223		150-2	12000	B	12000	150-2	SITE 224,225	10
11	-		-	12000	C	12000	-	-	12
13	SITE 226,227		150-2	12000	A	12000	150-2	SITE 228,229	14
15	-		-	12000	B	12000	-	-	16
17	SITE 230,231		150-2	12000	C	12000	150-2	SITE 232,233	18
19	-		-	12000	A	12000	-	-	20
21	SITE 234,235		150-2	12000	B	6000	80-2	SITE 236	22
23	-		-	12000	C	6000	-	-	24
25	SITE 237		80-2	6000	A	12000	150-2	SITE 238,239	26
27	-		-	6000	B	12000	-	-	28
29	SITE 240,241		150-2	12000	C	12000	150-2	SITE 242,243	30
31	-		-	12000	A	12000	-	-	32
33	SITE 244,245		150-2	12000	B	12000	150-2	SITE 246,247	34
35	-		-	12000	C	12000	-	-	36
37	SITE 248,249		150-2	12000	A	12000	150-2	SITE 250,251	38
39	-		-	12000	B	12000	-	-	40
41	SITE 252,253		150-2	12000	C	12000	150-2	SITE 254,255	42
43	-		-	12000	A	12000	-	-	44
45	SITE 256,257		150-2	12000	B	0	20-2	SPARE	46
47	-		-	12000	C	0	-	-	48
49	SPARE		20-2	0	A	0	20-2	SPARE	50
51	-		-	0	B	0	-	-	52
53	SPARE		20-1	0	C	0	20-1	SPARE	54

T:\job\24\2404\1\24041.dwg, 11/7/2025 12:30:03 PM, JosHB

P14A		VOLTS 120/208 PHASE 3 WIRE 4	MAIN CAPACITY BUSS MATERIAL MOUNTING	600 A MCB	A WATTS 96000 B WATTS 96000 C WATTS 96000	TOTAL WATTS 288000 SIMULTANEOUS LOAD 123840				
		ALTERNATE #2								
CIRC	LOCATION / DESCRIPTION		BRKR	WATTS	Ø	WATTS	BRKR	LOCATION / DESCRIPTION		CIRC
1	SITE 512,513		150-2	12000	A	12000	150-2	SITE 516,517		2
3	-		-	12000	B	12000	-	-		4
5	SITE 520,521		150-2	12000	C	12000	150-2	SITE 524,525		6
7	-		-	12000	A	12000	-	-		8
9	SITE 528,529		150-2	12000	B	12000	150-2	SITE 532,533		10
11	-		-	12000	C	12000	-	-		12
13	SITE 536,537		150-2	12000	A	12000	150-2	SITE 540,541		14
15	-		-	12000	B	12000	-	-		16
17	SITE 544,545		150-2	12000	C	12000	150-2	SITE 548,549		18
19	-		-	12000	A	12000	-	-		20
21	SITE 552,553		150-2	12000	B	12000	150-2	SITE 556,557		22
23	-		-	12000	C	12000	-	-		24
25	SPARE		20-2	0	A	0	20-2	SPARE		26
27	-		-	0	B	0	-	-		28
29	SPARE		20-2	0	C	0	20-2	SPARE		30
31	-		-	0	A	0	-	-		32
33	SPARE		20-2	0	B	0	20-2	SPARE		34
35	-		-	0	C	0	-	-		36
37	SPARE		20-2	0	A	0	20-2	SPARE		38
39	-		-	0	B	0	-	-		40
41	SPARE		20-1	0	C	0	20-1	SPARE		42

P17		VOLTS 120/208 PHASE 3 WIRE 4	MAIN CAPACITY BUSS MATERIAL MOUNTING	800 A MCB	A WATTS 162000 B WATTS 162000 C WATTS 144000	TOTAL WATTS 468000 SIMULTANEOUS LOAD 191880				
ALTERNATE #4										
CIRC	LOCATION / DESCRIPTION		BRKR	WATTS	ø	WATTS	BRKR	LOCATION / DESCRIPTION		CIRC
1	SITE 669,670		150-2	12000	A	12000	150-2	SITE 671,672		2
3	-		-	12000	B	12000	-	-		4
5	SITE 673,674		150-2	12000	C	12000	150-2	SITE 675,676		6
7	-		-	12000	A	12000	-	-		8
9	SITE 677,678		150-2	12000	B	12000	150-2	SITE 679,680		10
11	-		-	12000	C	12000	-	-		12
13	SITE 725		80-2	6000	A	12000	150-2	SITE 726,727		14
15	-		-	6000	B	12000	-	-		16
17	SITE 728,729		150-2	12000	C	12000	150-2	SITE 730,731		18
19	-		-	12000	A	12000	-	-		20
21	SITE 732,733		150-2	12000	B	12000	150-2	SITE 734,735		22
23	-		-	12000	C	12000	-	-		24
25	SITE 736,737		150-2	12000	A	12000	150-2	SITE 738,739		26
27	-		-	12000	B	12000	-	-		28
29	SITE 740,741		150-2	12000	C	12000	150-2	SITE 742,743		30
31	-		-	12000	A	12000	-	-		32
33	SITE 744,745		150-2	12000	B	12000	150-2	SITE 746,747		34
35	-		-	12000	C	12000	-	-		36
37	SITE 748,749		150-2	12000	A	12000	150-2	SITE 750,751		38
39	-		-	12000	B	12000	-	-		40
41	SPARE		20-2	0	C	0	20-2	SPARE		42
43	-		-	0	A	0	-	-		44
45	SPARE		20-2	0	B	0	20-2	SPARE		46
47	-		-	0	C	0	-	-		48
49	SPARE		20-2	0	A	0	20-2	SPARE		50
51	-		-	0	B	0	-	-		52
53	SPARE		20-1	0	C	0	20-1	SPARE		54

P14B		VOLTS 120/208 PHASE 3 WIRE 4	MAIN CAPACITY BUSS MATERIAL MOUNTING		600 A MCB	A WATTS 96000 B WATTS 84000 C WATTS 84000	TOTAL WATTS 264000 SIMULTANEOUS LOAD 123840			
		ALTERNATE #2								
CIRC	LOCATION / DESCRIPTION		BRKR	WATTS	ø	WATTS	BRKR	LOCATION / DESCRIPTION		CIRC
1	SITE 514,515		150-2	12000	A	12000	150-2	SITE 518,519		2
3	-		-	12000	B	12000	-	-		4
5	SITE 522,523		150-2	12000	C	12000	150-2	SITE 526,527		6
7	-		-	12000	A	12000	-	-		8
9	SITE 530,531		150-2	12000	B	12000	150-2	SITE 534,535		10
11	-		-	12000	C	12000	-	-		12
13	SITE 538,539		150-2	12000	A	12000	150-2	SITE 542,543		14
15	-		-	12000	B	12000	-	-		16
17	SITE 546,547		150-2	12000	C	12000	150-2	SITE 550,551		18
19	-		-	12000	A	12000	-	-		20
21	SITE 554,555		150-2	12000	B	0	20-2	SPARE		22
23	-		-	12000	C	0	-	-		24
25	SPARE		20-2	0	A	0	20-2	SPARE		26
27	-		-	0	B	0	-	-		28
29	SPARE		20-2	0	C	0	20-2	SPARE		30
31	-		-	0	A	0	-	-		32
33	SPARE		20-2	0	B	0	20-2	SPARE		34
35	-		-	0	C	0	-	-		36
37	SPARE		20-2	0	A	0	20-2	SPARE		38
39	-		-	0	B	0	-	-		40
41	SPARE		20-1	0	C	0	20-1	SPARE		42

P18		VOLTS 120/208 PHASE 3 WIRE 4	MAIN CAPACITY BUSS MATERIAL MOUNTING		800 A MCB	A WATTS 186000 B WATTS 168000 C WATTS 174000	TOTAL WATTS 528000 SIMULTANEOUS LOAD 216480		
		ALTERNATE #4							
CIRC	LOCATION / DESCRIPTION		BRKR	WATTS	ø	WATTS	BRKR	LOCATION / DESCRIPTION	CIRC
1	SITE 681,682		150-2	12000	A	12000	150-2	SITE 683,684	2
3	-		-	12000	B	12000	-	-	4
5	SITE 685,686		150-2	12000	C	12000	150-2	SITE 687,688	6
7	-		-	12000	A	12000	-	-	8
9	SITE 689,690		150-2	12000	B	12000	150-2	SITE 691,692	10
11	-		-	12000	C	12000	-	-	12
13	SITE 693,694		150-2	12000	A	12000	150-2	SITE 695,696	14
15	-		-	12000	B	12000	-	-	16
17	SITE 697,698		150-2	12000	C	12000	150-2	SITE 699,700	18
19	-		-	12000	A	12000	-	-	20
21	SITE 701,702		150-2	12000	B	12000	150-2	SITE 703,704	22
23	-		-	12000	C	12000	-	-	24
25	SITE 705		80-2	6000	A	12000	150-2	SITE 706,707	26
27	-		-	6000	B	12000	-	-	28
29	SITE 708,709		150-2	12000	C	12000	150-2	SITE 710,711	30
31	-		-	12000	A	12000	-	-	32
33	SITE 712,713		150-2	12000	B	12000	150-2	SITE 714,715	34
35	-		-	12000	C	12000	-	-	36
37	SITE 716,717		150-2	12000	A	12000	150-2	SITE 718,719	38
39	-		-	12000	B	12000	-	-	40
41	SITE 720,721		150-2	12000	C	12000	150-2	SITE 722,723	42
43	-		-	12000	A	12000	-	-	44
45	SITE 724		80-2	6000	B	0	20-2	SPARE	46
47	-		-	6000	C	0	-	-	48
49	SPARE		20-2	0	A	0	20-2	SPARE	50
51	-		-	0	B	0	-	-	52
53	SPARE		20-1	0	C	0	20-1	SPARE	54

P15		VOLTS 120/208 PHASE 3 WIRE 4	MAIN CAPACITY BUSS MATERIAL MOUNTING	800 A MCB	A WATTS 186000 B WATTS 168000 C WATTS 174000	TOTAL WATTS 528000 SIMULTANEOUS LOAD 216480			
		ALTERNATE #3							
CIRC	LOCATION / DESCRIPTION		BRKR	WATTS	ø	WATTS	BRKR	LOCATION / DESCRIPTION	CIRC
1	SITE 558		80-2	6000	A	12000	150-2	SITE 559,560	2
3	-		-	6000	B	12000	-	-	4
5	SITE 561,562		150-2	12000	C	12000	150-2	SITE 563,564	6
7	-		-	12000	A	12000	-	-	8
9	SITE 565,566		150-2	12000	B	12000	150-2	SITE 567,568	10
11	-		-	12000	C	12000	-	-	12
13	SITE 569,570		150-2	12000	A	12000	150-2	SITE 571,572	14
15	-		-	12000	B	12000	-	-	16
17	SITE 573,574		150-2	12000	C	12000	150-2	SITE 575,576	18
19	-		-	12000	A	12000	-	-	20
21	SITE 577,578		150-2	12000	B	12000	150-2	SITE 579,580	22
23	-		-	12000	C	12000	-	-	24
25	SITE 581,582		150-2	12000	A	12000	150-2	SITE 583,584	26
27	-		-	12000	B	12000	-	-	28
29	SITE 585,586		150-2	12000	C	12000	150-2	SITE 587,588	30
31	-		-	12000	A	12000	-	-	32
33	SITE 589,590		150-2	12000	B	12000	150-2	SITE 591,592	34
35	-		-	12000	C	12000	-	-	36
37	SITE 593,594		150-2	12000	A	12000	150-2	SITE 595,596	38
39	-		-	12000	B	12000	-	-	40
41	SITE 597,598		150-2	12000	C	12000	150-2	SITE 599,600	42
43	-		-	12000	A	12000	-	-	44
45	SITE 601		80-2	6000	B	0	20-2	SPARE	46
47	-		-	6000	C	0	-	-	48
49	SPARE		20-2	0	A	0	20-2	SPARE	50
51	-		-	0	B	0	-	-	52
53	SPARE		20-1	0	C	0	20-1	SPARE	54

P16		VOLTS 120/208 PHASE 3 WIRE 4	MAIN CAPACITY BUSS MATERIAL MOUNTING		800 A MCB	A WATTS 186000 B WATTS 168000 C WATTS 174000	TOTAL WATTS 528000 SIMULTANEOUS LOAD 216480		
ALTERNATE #3									
CIRC	LOCATION / DESCRIPTION		BRKR	WATTS	ø	WATTS	BRKR	LOCATION / DESCRIPTION	CIRC
1	SITE 621,622		150-2	12000	A	12000	150-2	SITE 623,624	2
3	-		-	12000	B	12000	-	-	4
5	SITE 625,626		150-2	12000	C	12000	150-2	SITE 627,628	6
7	-		-	12000	A	12000	-	-	8
9	SITE 629,630		150-2	12000	B	12000	150-2	SITE 631,632	10
11	-		-	12000	C	12000	-	-	12
13	SITE 633		80-2	6000	A	12000	150-2	SITE 634,635	14
15	-		-	6000	B	12000	-	-	16
17	SITE 636,637		150-2	12000	C	12000	150-2	SITE 638,639	18
19	-		-	12000	A	12000	-	-	20
21	SITE 640,641		150-2	12000	B	12000	150-2	SITE 646,647	22
23	-		-	12000	C	12000	-	-	24
25	SITE 648,649		150-2	12000	A	12000	150-2	SITE 650,651	26
27	-		-	12000	B	12000	-	-	28
29	SITE 652,653		150-2	12000	C	12000	150-2	SITE 654,655	30
31	-		-	12000	A	12000	-	-	32
33	SITE 656,657		150-2	12000	B	6000	80-2	SITE 658	34
35	-		-	12000	C	6000	-	-	36
37	SITE 659,660		150-2	12000	A	12000	150-2	SITE 661,662	38
39	-		-	12000	B	12000	-	-	40
41	SITE 663,664		150-2	12000	C	12000	150-2	SITE 665,666	42
43	-		-	12000	A	12000	-	-	44
45	SITE 667,668		150-2	12000	B	0	20-2	SPARE	46
47	-		-	12000	C	0	-	-	48
49	SPARE		20-2	0	A	0	20-2	SPARE	50
51	-		-	0	B	0	-	-	52
53	SPARE		20-1	0	C	0	20-1	SPARE	54