ADDENDUM NO. 1

TO: PLANS AND SPECIFICATIONS FOR STATE OF MISSOURI

Construct Solar Array Building 1270 Fort Leonard Wood, Missouri PROJECT NO.: T2229-01

Bid Opening Date: 1:30 PM, Thursday, June 29, 2023 (Not Changed)

Bidders are hereby informed that the construction Plans and/or Specifications are modified as follows:

SPECIFICATION CHANGES:

None.

DRAWING CHANGES:

1. <u>Sheet E-501</u>

Details 1 and 2 were revised due to a printing error. See attached revised sheet.

GENERAL COMMENTS:

- 1. The Pre-bid Meeting was held June 15, 2023 at 9:30 AM. The Pre-bid Meeting sign-in sheet is attached.
- Please contact Paul Girouard, Contract Specialist, at Paul.Girouard@oa.mo.gov or 573-751-4797 for questions about bidding procedures, MBE\WBE\SDVE Goals, and other submittal requirements.
- 3. The deadline for technical questions was June 21, 2023 at noon.
- 4. Changes to, or clarification of, the bid documents are only made as issued in the addenda.
- 5. All correspondence with respect to this project must include the State of Missouri project number as indicated above.
- 6. Current Plan holders list available online at <u>T2229-01 Construct Solar Array Building 1270 ::</u> Plan Holders :: State of Missouri Office of Administration (oafmdcplanroom.com)
- 7. Prospective Bidders contact American Document Solutions, 1400 Forum Blvd Suite 1C, Columbia MO 65201, 573-446-7768 to order official plans and specifications.
- 8. All bids shall be submitted on the bid form without additional terms and conditions, modifications, or stipulations. Each space on the bid form shall be properly filled including an amount for the alternate. Failure to do so will result in rejection of the bid.
- 9. MBE/WBE/SDVE participation requirements can be found in DIVISION 00. The MBE/WBE/SDVE participation goals are 10%/10%/3%, respectively. Only certified firms as of the bid opening date can be used to satisfy the MBE/WBE/SDVE participation goals for this project. If a bidder is unable to meet a participation goal, a Good Faith Effort Determination Form must be completed. Failure to complete this process will result in rejection of the bid.

ATTACHMENTS:

- 1. Pre-bid Meeting Sign-In Sheet
- 2. Revised Sheet E-501


June 22, 2023


END OF ADDENDUM NO. 1

	Sign-In Sheet
Project: Install Solar Array, Multiple Buildings. Fort Leonard Wood,	MO
Project: T2224-01, T2228-01, T2231-01 Meeting PL2	6.d

Date:	6-	15-	2023
-------	----	-----	------

Name	Company	Phone	Email
Jake Jungmann	CDL Electric	\$620-238-0097	Jake jungmann B CPL - electric, com
JOHN DKE-THOMAS	OKE-THOMAS ASEOC.	417-263-6262	
Chad Schwaster	Meyer Electric	573-821-2651	Chad @ mexerelectric, net
Tony Bliss	Snodgrass ContActing	573-433-136	
ottects	Snodyress Contracting	7193559110	Strets@Snodgrass Contraction, CO
BRETT STUKLER	MENER ELECTRIC	573-261-0030	
Kyle Ross	JR+CB., Inc.	816-708-7540	Kyle. Ross@ JPCOUSA.com
Calebkretzinger	Canills Construction In		bids@cabillsconstruction.com
NFCK MORRIS	BRILLIANT CHARGE	816-739-7688	nick@balliont charge, com
Richie Townlain	Prost/ Pro Joint Venture	573-635-0211	Estimating @ Prostbuilders. com
Shane Ansilm	MACRC	573 263. 5890	sanselmalarorentesinion or
DAVID BINGHAM	OHM RESTORATION	417-241-3500) david a ohmestoration com
Sacob Weisman	OHM Restoration	480-234-6276	Tacob @ chyrestoration.com
Michael Schwader	OA/FMPC	573-536-7105	michael. Schvader QoA. Mo.gov
Michael Soufly	MORE	573-638-9655	michkel.c. Sude 788. ntg parmy, mil
KEN PAShiA	MOARNG	573-329-9000	
Rob Schmitt	CSE	316-309-0044	Robert 7721 @ aul. com

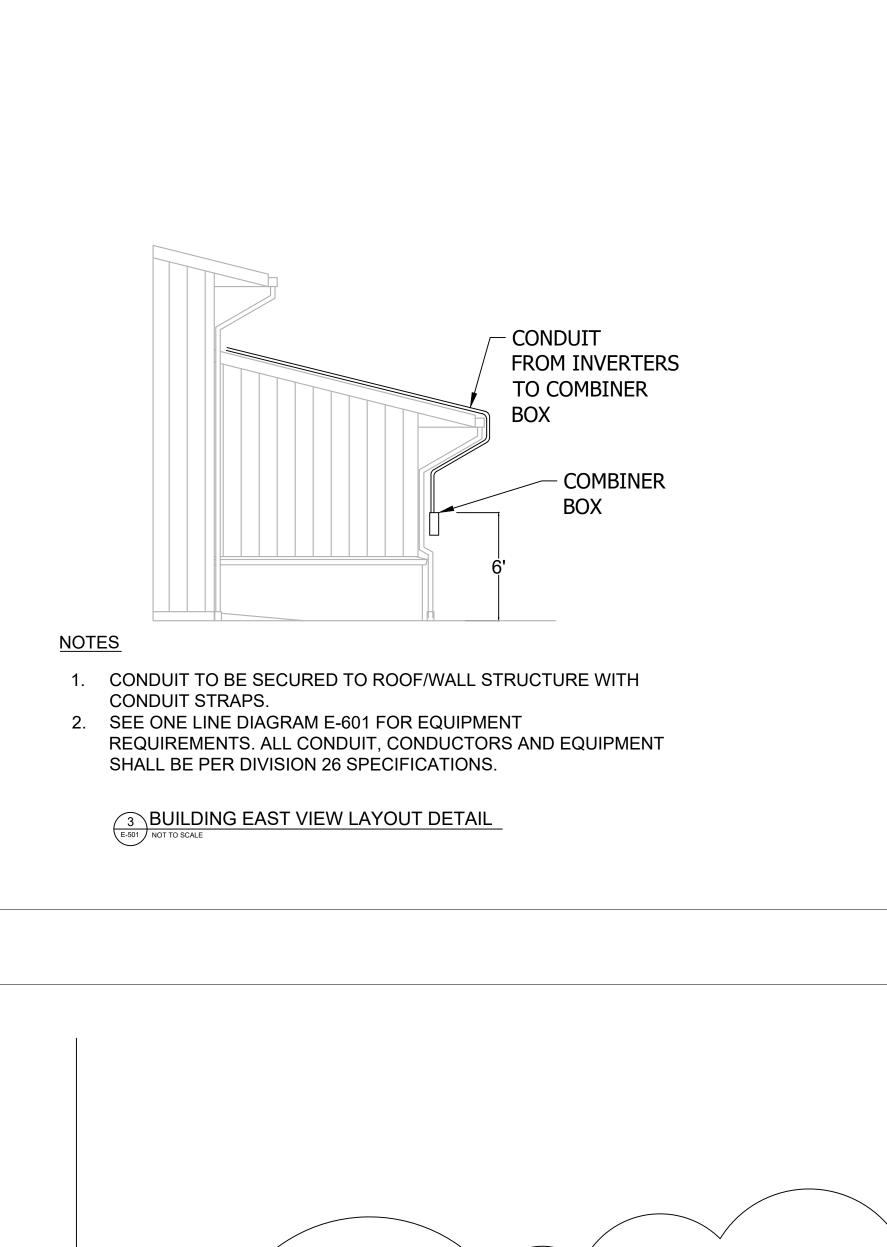


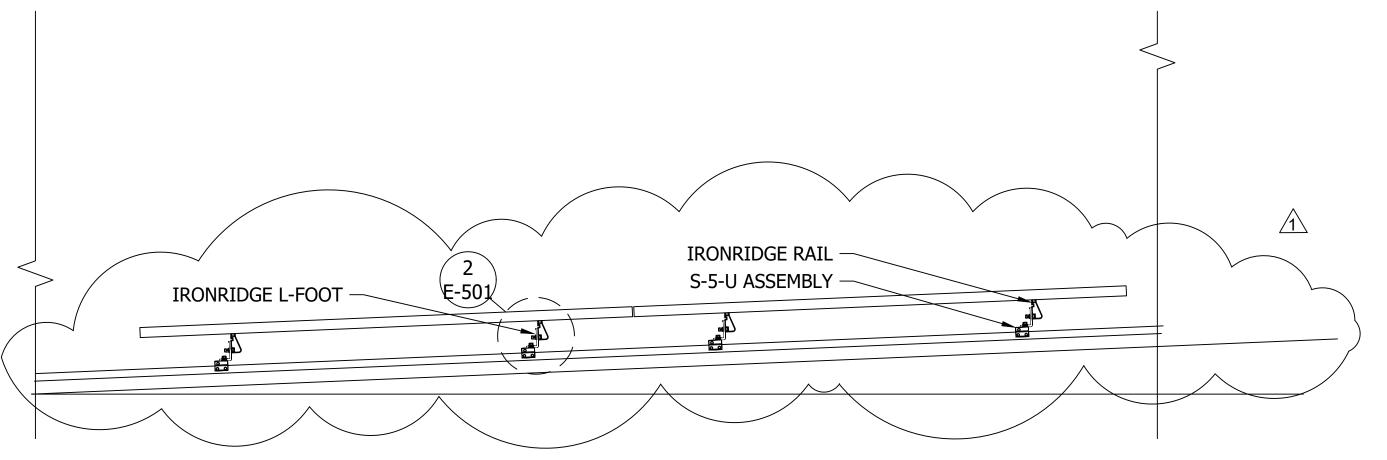


<u>NOTE</u>S

1. SOLAR MODULES SUPPORTS SHALL BE IRONRIDGE RAIL SERIES ROOF MOUNTS OR APPROVED EQUAL BY PROSOLAR, SNAPRACK OR UNIRAC, WITH S5 METAL SEAM ROOF CLIPS.

1 SOLAR PANEL ROOF SUPPORT DETAIL

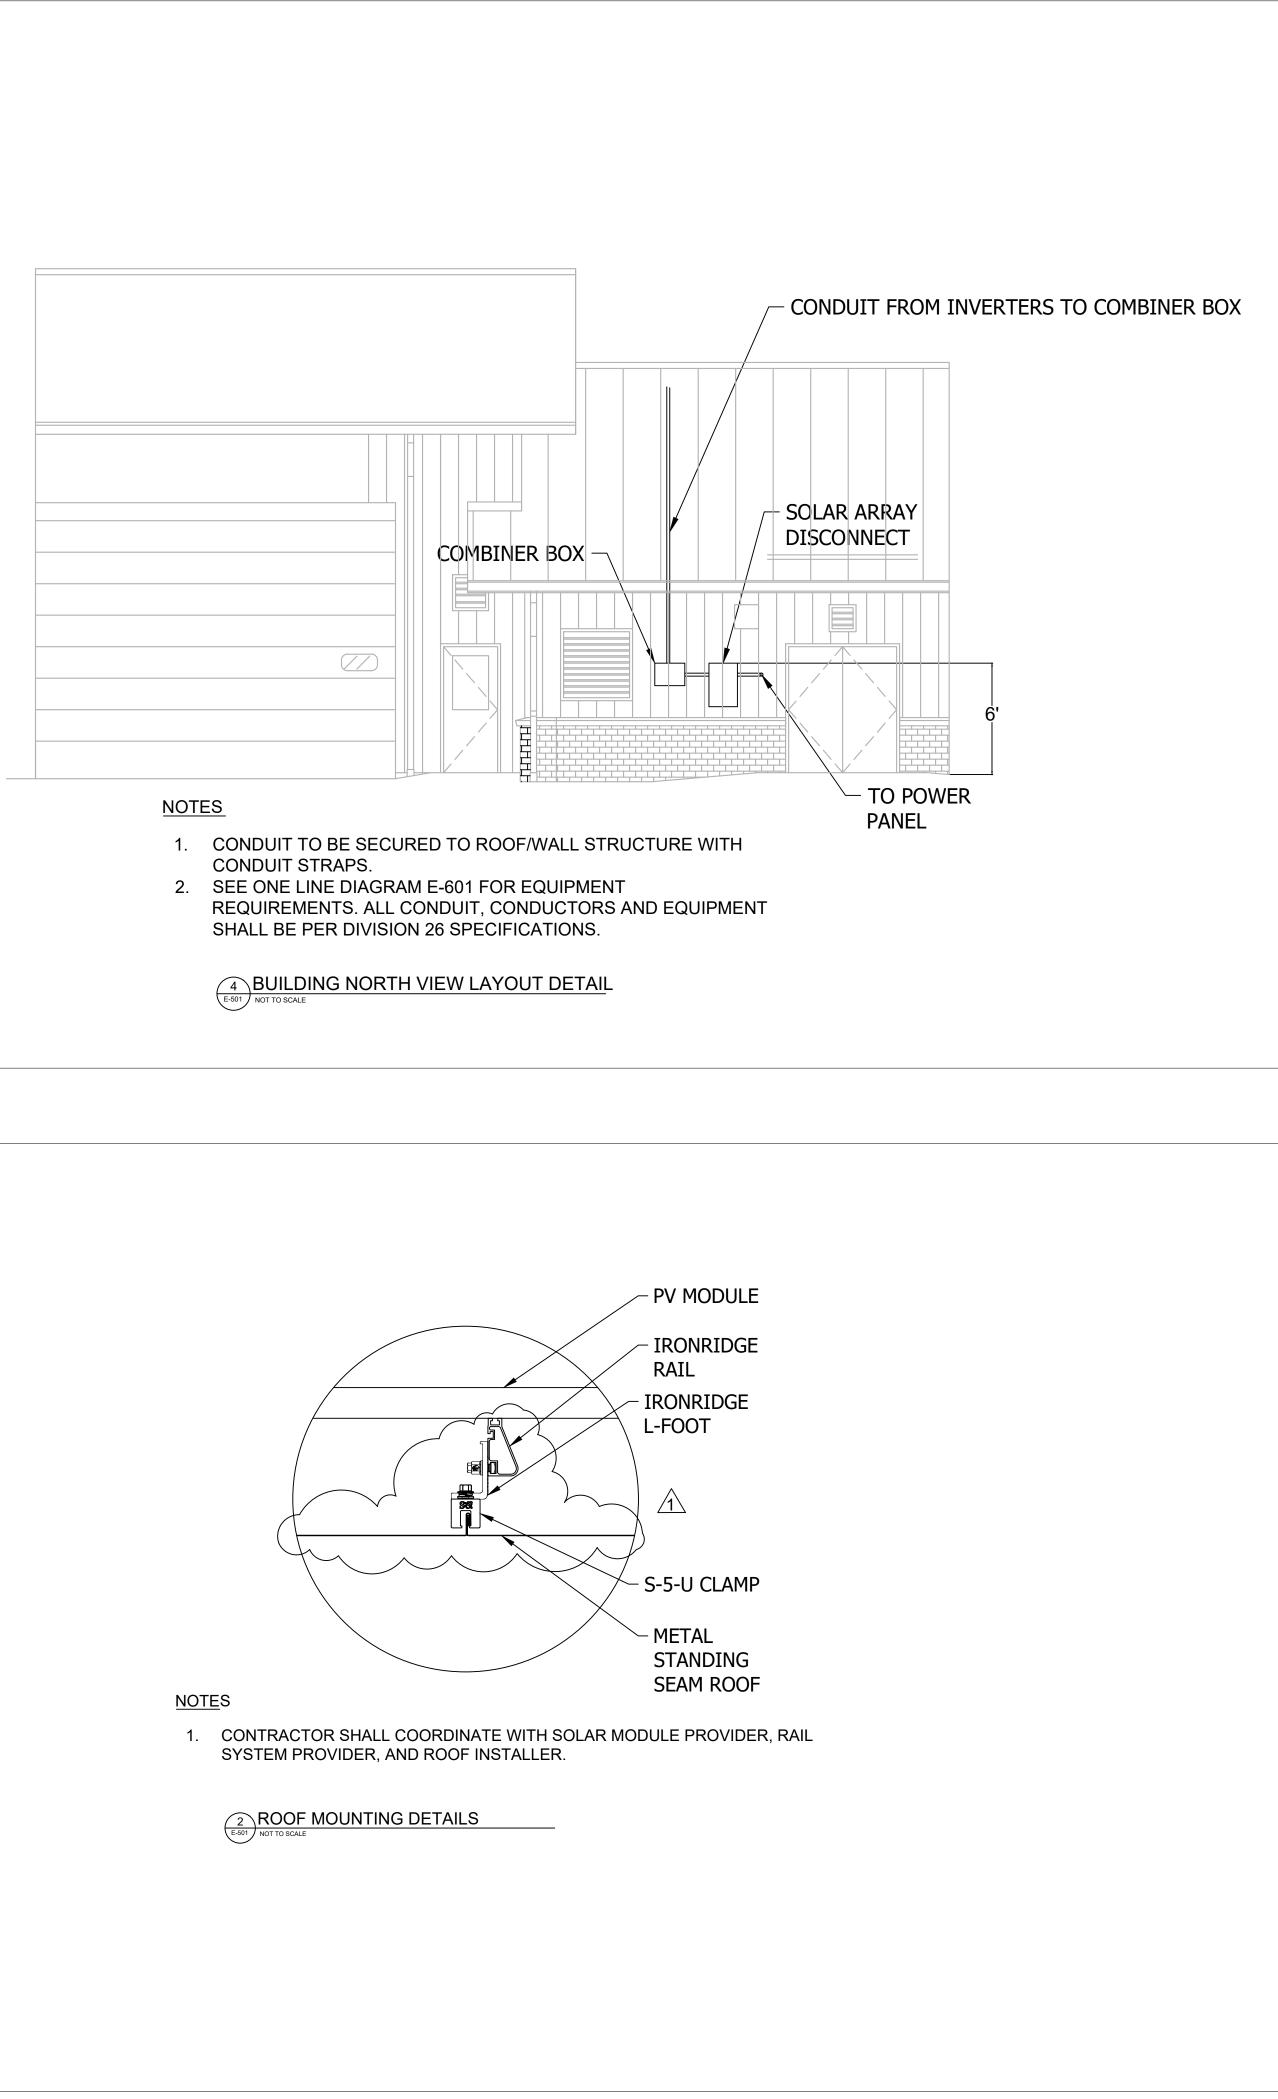

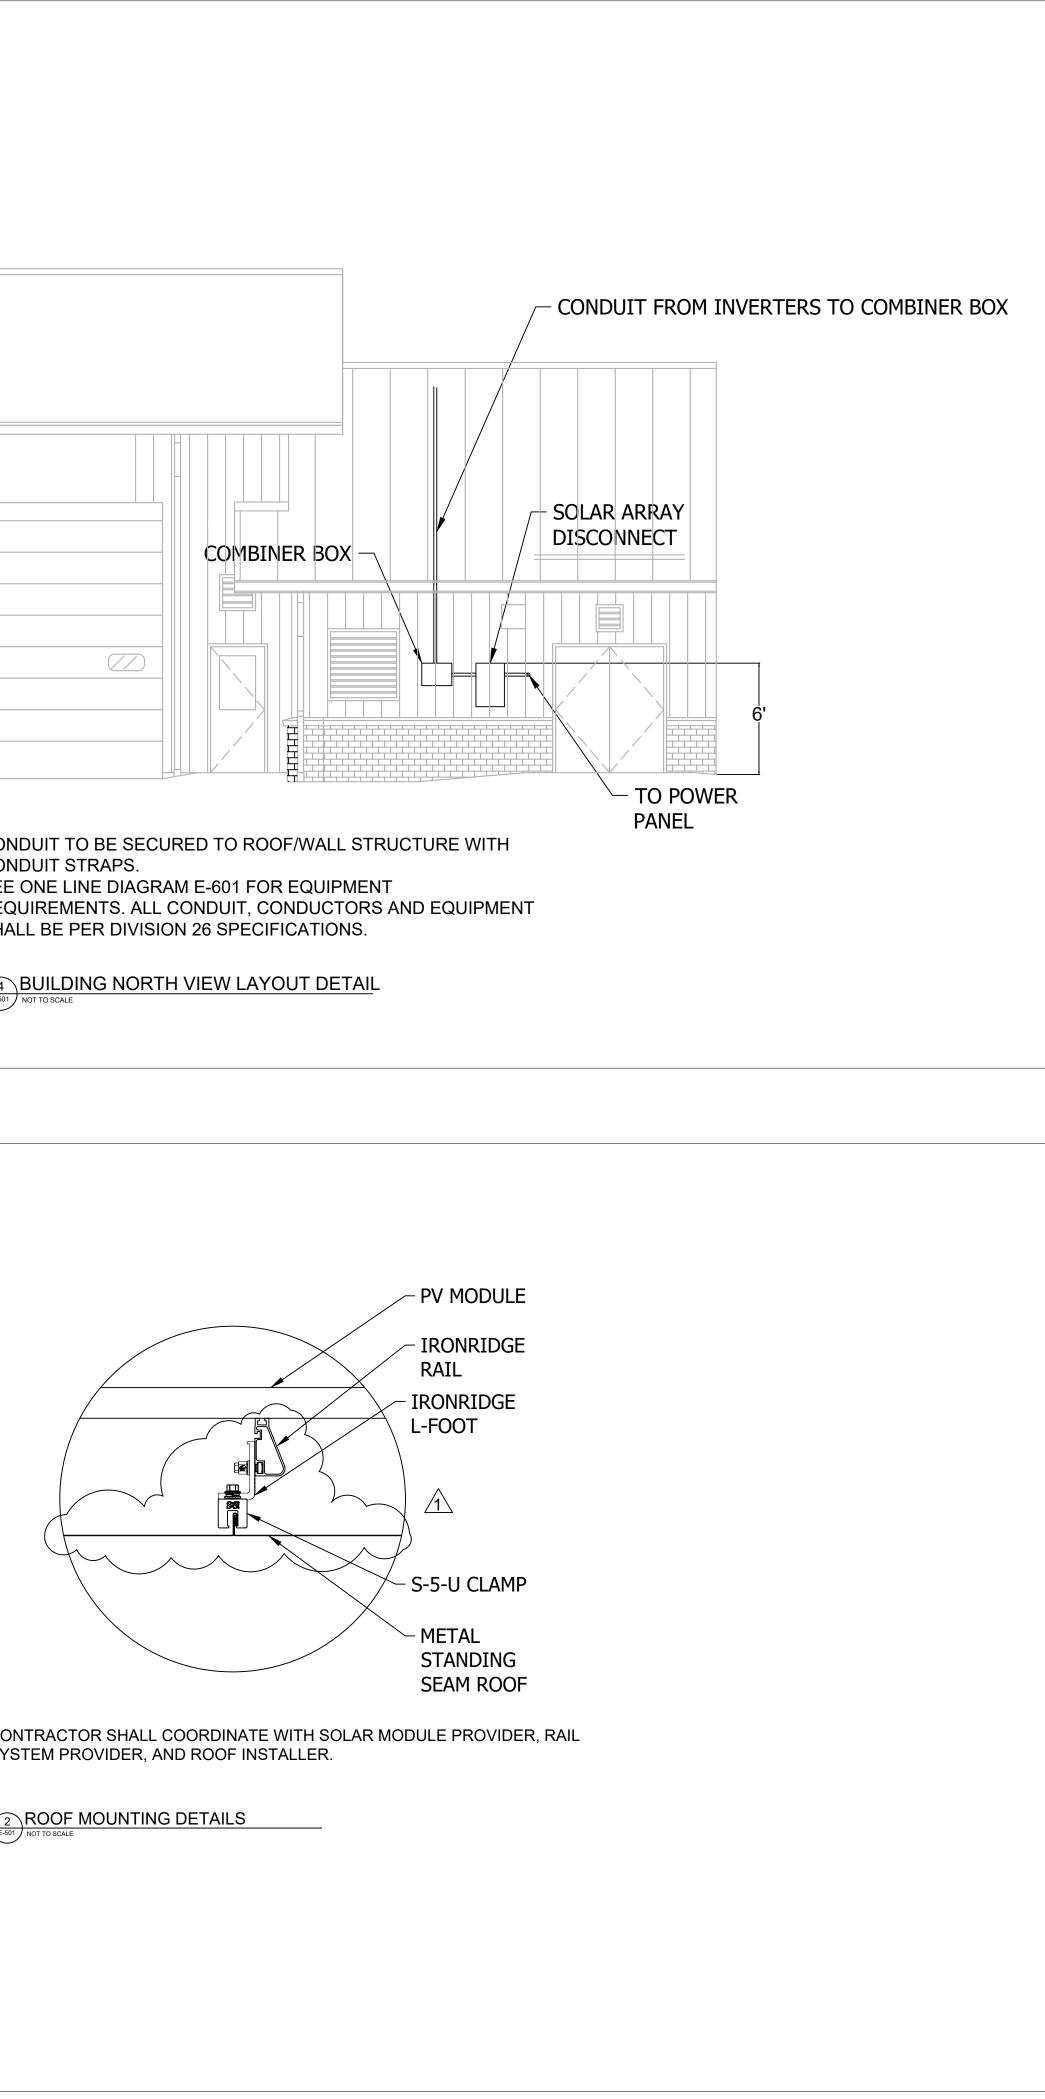

STATE OF MISSOURI MICHAEL L. PARSON, GOVERNOR
ROBERT FISCHMUT E-27183 PROFESSION 6/15/2023
CROSSED SWORDS ENGINEERING 1619 NE OAK TREE DR. LEE'S SUMMIT MO 64086 (816) 309-0099 Robert7721@aol.com MO STATE CERTIFICATE OF AUTHORITY#2016003099
OFFICE OF ADMINISTRATION DIVISION OF FACILITIES MANAGEMENT, DESIGN AND CONSTRUCTION MISSOURI NATIONAL GUARD OFFICE OF THE ADJUTANT GENERAL FACILITIES MANAGEMENT OFFICE
READINESS CENTER BUILDING 1270FT. LEONARD WOOD, MO 65473PROJECT #T2229-01SITE # 6306 ASSET # 8136306006
REVISION: <u>1</u> DATE: <u>6/15/2023</u> REVISION: <u>1</u> DATE: REVISION: <u>1</u> DATE: <u>1</u> ISSUE DATE: 2/10/2023 CAD DWG FILE: <u>E-501.DWG</u>
DRAWN BY: RFS CHECKED BY: RFS DESIGNED BY: RFS SHEET TITLE: ELECTRICAL DETAILS
SHEET NUMBER: E-501 4 OF 5 SHEETS

FEBRUARY 10, 2023